

BID DOCUMENTS

HENRICO COUNTY ANIMAL SHELTER
RENOVATION

HENRICO COUNTY
HENRICO, VIRGINIA

MOSELEYARCHITECTS



3200 NORFOLK STREET, RICHMOND, VA 23230
PHONE (804) 794-7555 FAX (804) 355-5690
MOSELEYARCHITECTS.COM

TIMMONS GROUP

1001 BOULDERS PARKWAY, SUITE 300

CIVIL ENGINEERING

RICHMOND, VA 23225

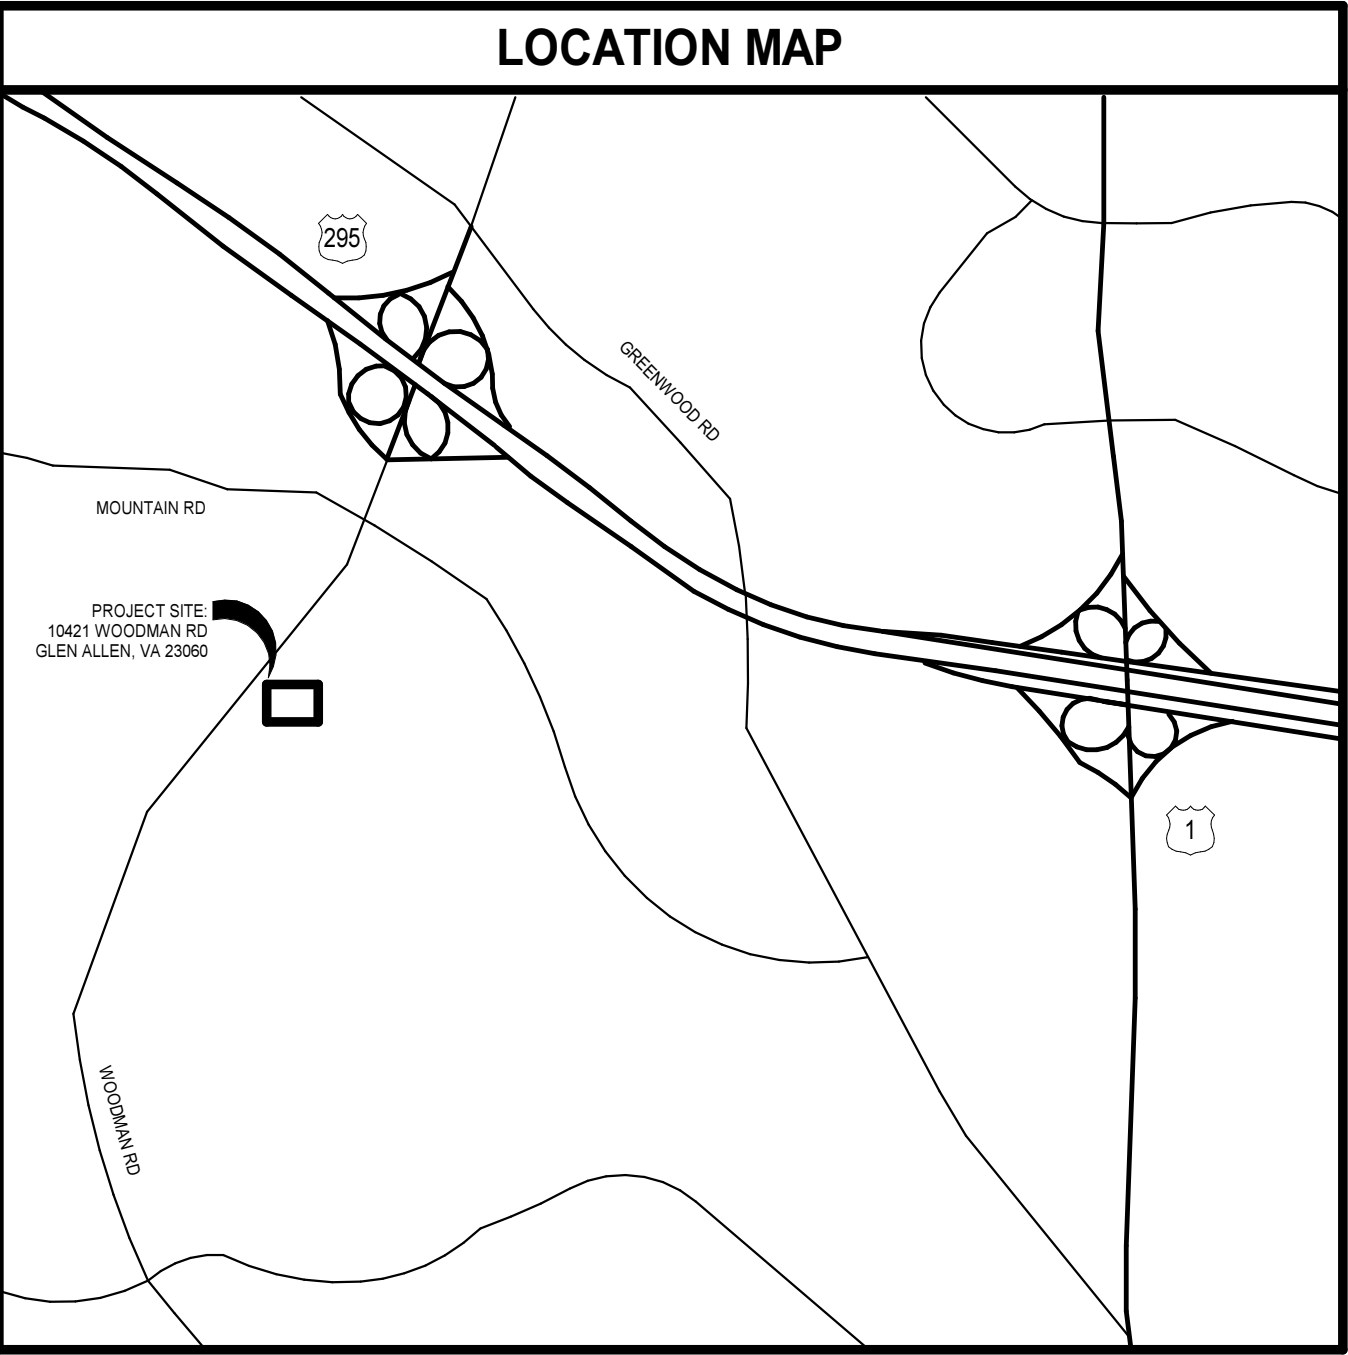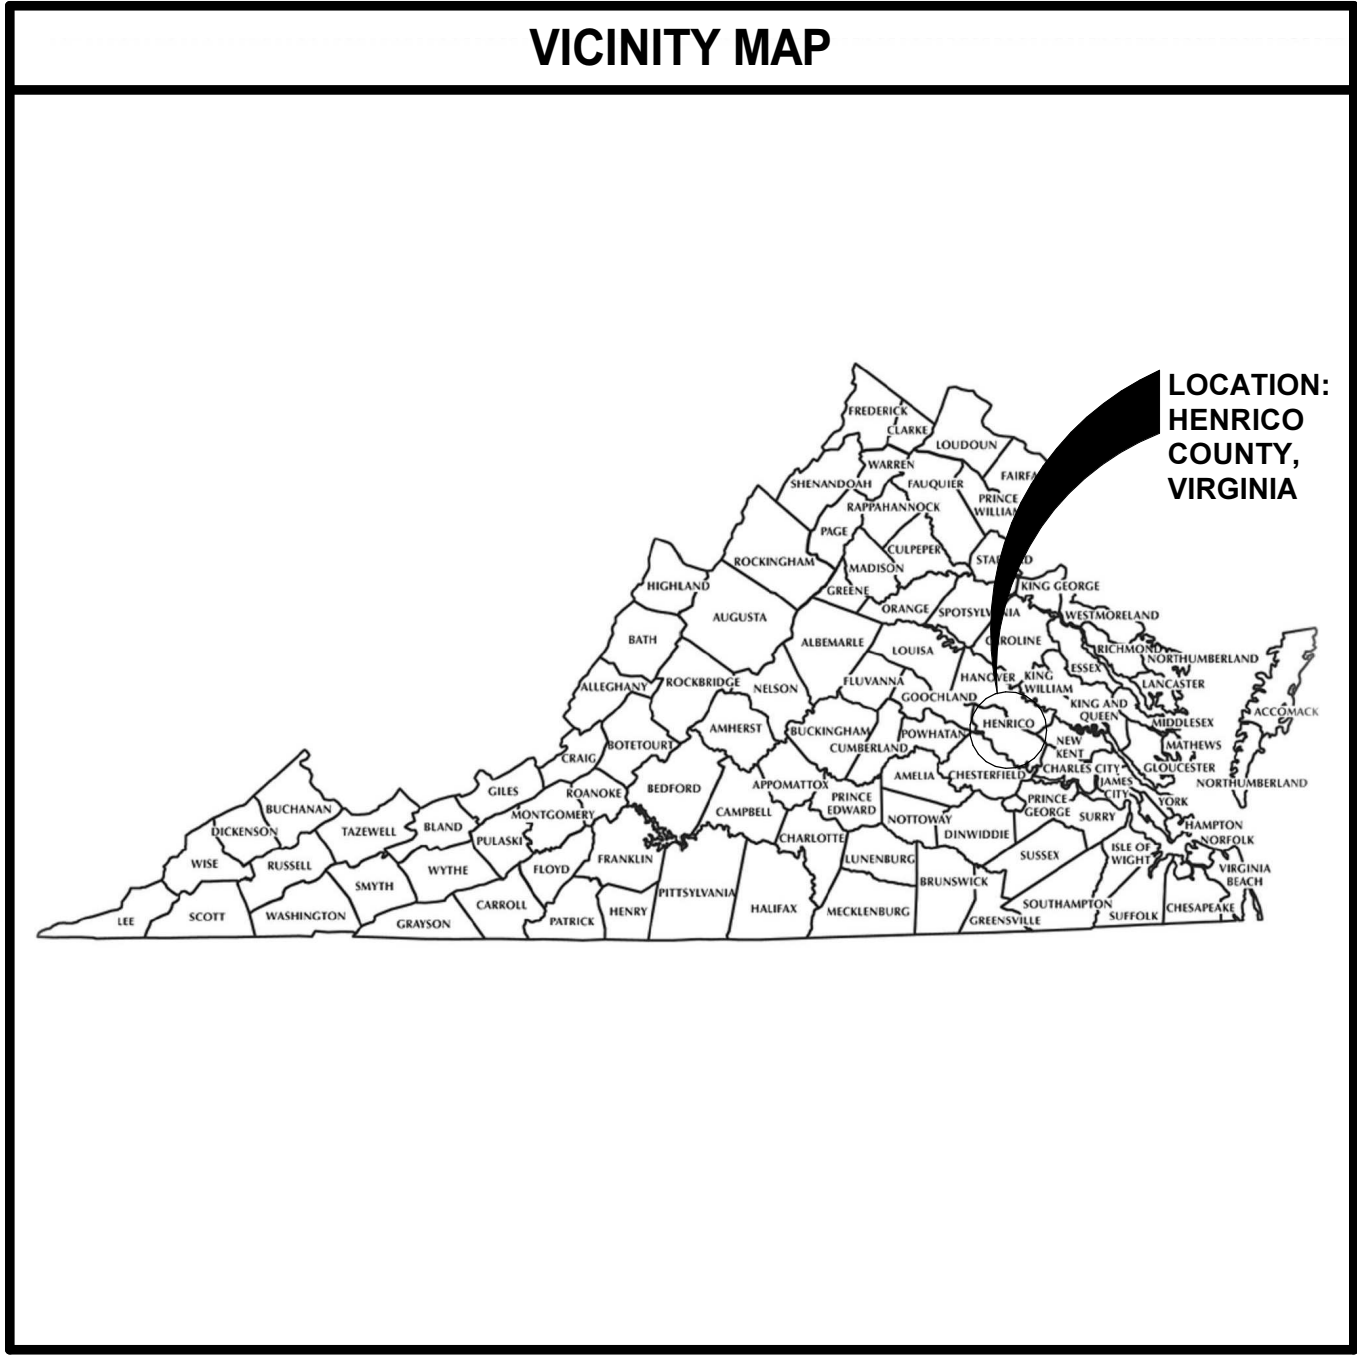

DRAWING INDEX			
GENERAL		FIRE PROTECTION	
G0.1	COVER	FP0.1	LEGENDS, ABBREVIATIONS AND GENERAL NOTES
LIFE SAFETY		FP1.1	FIRST FLOOR PLAN - DEMOLITION - FIRE PROTECTION
LS1.1	LIFE SAFETY INFORMATION	FP2.1	FIRST FLOOR PLAN - FIRE PROTECTION
ARCHITECTURAL		MECHANICAL	
A0.1	GENERAL ARCHITECTURAL INFORMATION	M0.1	LEGENDS, ABBREVIATIONS AND GENERAL NOTES
A2.2	WALL/PARTITION TYPES, WALL JOINTS AND TERMINATIONS	M0.2	SCHEDULES
A1.0.1	PHASING PLAN	M1.1	FIRST FLOOR PLAN - DEMOLITION
A1.2.1	DEMOLITION PLAN - FIRST FLOOR	M2.1	FIRST FLOOR PLAN
A2.1.1	FLOOR PLAN	M5.1	DETAILS
A3.0.1	FINISH SCHEDULE AND FINISH PLAN	M5.2	DETAILS
A3.1.1	DOOR AND FRAME SCHEDULE	M7.1	CONTROLS
A3.2.1	DOOR AND FRAME DETAILS	ELECTRICAL	
A7.1.1	ENLARGED PLANS	E0.1	LEGENDS, ABBREVIATIONS AND GENERAL NOTES
A8.1	CASEWORK AND ELEVATIONS	E1.2	FLOOR PLANS - ELEC DEMOLITION
A9.1.1	REFLECTED CEILING PLAN - FIRST FLOOR	E2.1.1	FLOOR PLAN - LIGHTING
STRUCTURAL		E2.1.2	FLOOR PLAN - POWER
S0.0.1	GENERAL STRUCTURAL INFORMATION	E2.1.3	FLOOR PLANS - COMMUNICATIONS
PLUMBING		E2.1.4	FLOOR PLANS - MECH POWER
P0.1	LEGENDS, ABBREVIATIONS AND GENERAL NOTES	E4.1	ELECTRICAL DETAILS
P1.0	FOUNDATION PLAN - DEMOLITION - PLUMBING	E4.2	ELECTRICAL DETAILS
P1.1	FIRST FLOOR PLAN - DEMOLITION - SANITARY	E5.1	POWER ONE-LINE DIAGRAM
P1.2	FIRST FLOOR PLAN - DEMOLITION - DOMESTIC	E5.2	PANELBOARD SCHEDULES
P1.3	MEZZANINE PLANS - DEMOLITION		
P2.0	FOUNDATION PLAN - PLUMBING		
P2.1	FIRST FLOOR PLAN - SANITARY		
P2.2	FIRST FLOOR PLAN - DOMESTIC		
P2.3	MEZZANINE PLANS		
P6.1	DETAILS		
P6.1	SCHEDULES		

THE CONTRACT DOCUMENTS ARE COMPLEMENTARY, AND WHAT IS REQUIRED BY ONE SHALL BE AS BINDING AS IF REQUIRED BY ALL.
IN CASE OF A CONFLICT, DISAGREEMENT, OR AMBIGUITY, PROVIDE THE BETTER QUALITY. IN CASE OF A CONFLICT, DISAGREEMENT, OR AMBIGUITY, PROVIDE THE GREATER QUANTITY OF WORK.

MOSELEYARCHITECTS

3200 NORFOLK STREET, RICHMOND, VA 23230
PHONE (804) 794-7555 FAX (804) 355-5690
MOSELEYARCHITECTS.COM

HENRICO COUNTY ANIMAL SHELTER RENOVATION

10421 WOODMAN ROAD, GLEN ALLEN, VA 23060

HENRICO COUNTY

PROJECT NO: 615225
DATE: AUGUST 18, 2025

REVISIONS

DATE DESCRIPTION

COVER

G0.1

EXISTING BUILDING DATA

PRIMARY OCCUPANCY CLASSIFICATION & USE GROUP:		Business: B	
CONSTRUCTION TYPE:		V-B	
FULLY SPRINKLERED TYPE:		YES	NFPA 13
MIXED OCCUPANCY:		NO	
NON-SEPARATED MIXED USE:		NO	DESIGN OCCUPANCY CLASSIFICATION: Business: B
SEPARATED MIXED USE:		NO	

OCCUPANCY SCHEDULE

SPACE NUMBER	SPACE NAME	USE CLASSIFICATION	USED TO DETERMINE OCCUPANCY FACTOR ONLY	FLOOR AREA PER OCCUPANT	AREA SF	GROSS	NET	TABULAR	OCCUPANCY LOAD ACTUAL	DESIGN
101	FOYER	B	BUSINESS AREAS	150 SF	102	•	1	2	•	2
102	ENTRY	B	BUSINESS AREAS	150 SF	411	•	3	8	•	8
103	CAT ADOPTIONS	B	BUSINESS AREAS	150 SF	266	•	2	5	•	5
104	INTERVIEW	B	BUSINESS AREAS	150 SF	78	•	1	2	•	2
105	RECEPTION	B	BUSINESS AREAS	150 SF	182	•	2			2
106	ADULT DOG RUNS	B	BUSINESS AREAS	150 SF	2131	•	15			15
107	TOILET	B	TOILETS	0 SF	61	•				0
108	TOILET	B	TOILETS	0 SF	60	•				0
109	FOOD PREP/STORAGE	B	BUSINESS AREAS	150 SF	243	•	2	3	•	3
110	PUPPY RUNS	B	BUSINESS AREAS	150 SF	344	•	3	4	•	4
111	QUARANTINE	B	BUSINESS AREAS	150 SF	344	•	3			3
112	WARDENS	B	BUSINESS AREAS	150 SF	163	•	2	4	•	4
113	CAT ISOLATION	B	BUSINESS AREAS	150 SF	147	•	1	2	•	2
114	LAUNDRY	B	BUSINESS AREAS	150 SF	131	•	1	2	•	2
115	ISOLATION	B	BUSINESS AREAS	150 SF	337	•	3			3
116	CREMATORY	B	BUSINESS AREAS	150 SF	387	•	3	4	•	4
117	FERAL CATS	B	BUSINESS AREAS	150 SF	137	•	1	2	•	2
118	X-RAY	B	BUSINESS AREAS	150 SF	125	•	1	2	•	2
119	SALLYPORT	B	BUSINESS AREAS	150 SF	684	•	5			5
120	DATA CLOSET	B	ACCESSORY STORAGE & MECHANICAL EQUIPMENT ROOM	300 SF	54	•	1			1
120B	CORRIDOR	B	CIRCULATION	0 SF	61	•				0
121	VET	B	BUSINESS AREAS	150 SF	229	•	2			2
122	JANITOR CLOSET	B	ACCESSORY STORAGE & MECHANICAL EQUIPMENT ROOM	300 SF	97	•	1			1
123	LOCKER RM	B	LOCKER ROOM	50 SF	82	•	2			2
124	TOILET	B	TOILETS	0 SF	62	•				0
125	TOILET	B	TOILETS	0 SF	61	•				0
126	LOCKER RM	B	LOCKER ROOM	50 SF	81	•	2			2
127	BREAK ROOM	B	BUSINESS AREAS	150 SF	231	•	2	8	•	8
128	WORKSTATIONS	B	BUSINESS AREAS	150 SF	247	•	2			2
129	OFFICE	B	BUSINESS AREAS	150 SF	97	•	1	3		3
130	OFFICE	B	BUSINESS AREAS	150 SF	97	•	1	3		3
131	OFFICE	B	BUSINESS AREAS	150 SF	98	•	1	3		3
132	CORRIDOR	B	CIRCULATION	0 SF	205	•				0
133	CORRIDOR	B	CIRCULATION	0 SF	396	•				0
134	CORRIDOR	B	CIRCULATION	0 SF	87	•				0
135	CORRIDOR	B	CIRCULATION	0 SF	98	•				0
136	ELECTRICAL	B	ACCESSORY STORAGE & MECHANICAL EQUIPMENT ROOM	300 SF	59	•	1			1
137	OUTDOOR MECHANICAL	B	ACCESSORY STORAGE & MECHANICAL EQUIPMENT ROOM	300 SF	310	•	2			2
138	DOG WASHROOM	B	BUSINESS AREAS	150 SF	53	•	1			1
139	SURGICAL SUITE	B	BUSINESS AREAS	150 SF	84	•	1			1
										100

OCCUPANCIES DELINEATED WITH * HAVE OCCUPANCY LOAD MODIFICATIONS BASED ON RECORD DRAWINGS DATED MARCH 10, 2006.



N
LIFE SAFETY FLOOR PLAN
1/8" = 1'-0"

LIFE SAFETY SYMBOL LEGEND

APPLIES TO LS SERIES OF DRAWINGS ONLY

DESIGNATOR MATRIX					SYMBOLS	
	WALL	BARRIER	PARTITION	RATED BEARING OR NON-BEARING WALL		
4 HR FIRE					1205	ROOM NUMBER
3 HR FIRE					798 1280	DIRECTION OF EGRESS EGRESS LOAD CAPACITY NUMBER OF OCCUPANTS
2 HR FIRE	*****				798 1280	DIRECTION OF EGRESS EGRESS LOAD CAPACITY NUMBER OF OCCUPANTS
1 HR FIRE		▶▶▶▶▶			174'-9" TD	EXIT ACCESS TRAVEL DISTANCE
1/4 HR FIRE					74'-9" CPOT	COMMON PATH OF TRAVEL
SMOKE					◆	FIRE EXTINGUISHER CABINET
SMOKE-TIGHT					●	FIRE EXTINGUISHER BRACKET
INCIDENTAL					▨	EXTENT OF FLOOR / CEILING AND/OR ROOF / CEILING ASSEMBLY
					■	EXTENT OF LEVEL 2 ALTERATIONS

NOTES:

- WALL DESIGNATIONS ON THE LS SERIES OF DRAWINGS ARE FOR GRAPHICAL PURPOSES ONLY AND MAY NOT REPRESENT THE ACTUAL WALL/PARTITION CONSTRUCTION.
- REFER TO THE CONTRACT DOCUMENTS, INCLUDING THE LIFE SAFETY SYMBOLS LEGEND AND A0, A1 AND, A2 SERIES OF DRAWINGS, FOR ACTUAL WALL/PARTITION TYPES AND CONSTRUCTION REQUIREMENTS.
- RATING OF BEARING OR NON-BEARING WALLS ARE PER TABLE 601 AND SECTION 602.1 AND DO NOT REQUIRE PROTECTED OPENINGS.

FIRE RATED ASSEMBLIES

REPRESENTED BY Xn

THE ASSEMBLIES REFERENCED ARE BASIS OF DESIGN. EQUIVALENT COMPATIBLE TESTED ASSEMBLIES WILL BE ACCEPTABLE IF APPROVED BY THE LAHJ

MARK	FIRE RATING	APPLIES TO	REFERENCE	REMARKS
X1	1 HR	PARTITION TYPE P6-1	1-HOUR UL DESIGN U419	
X2	1 HR	STAIR CEILING - HORIZONTAL SHAFT WALL SYSTEM	1-HOUR UL DESIGN U415	USE 2 1/2" CH STUDS
X3	1 HR	BEARING AND NON-BEARING MASONRY WALLS	VCC TABLE 721.1(2)	
X4	1 HR	PARTITION TYPE P7-1	1-HOUR UL DESIGN U415	

BUILDING DATA

APPLICABLE CODES, STANDARDS, AND/OR REFERENCES:

VIRGINIA CONSTRUCTION CODE (VCC) 2021
VIRGINIA EXISTING BUILDING CODE (VEBC) 2021
2017 - ICC A117.1 ACCESSIBLE AND USABLE BUILDINGS AND FACILITIES

LEVEL OF ALTERATIONS

LEVEL 1
LEVEL 2 (1,140 SF) - REFER TO FLOOR PLAN

FLOOR AREA

MAIN FLOOR 10,139 SF (INCLUDING SALLYPORT AND CREMATORY)
MECHANICAL EQUIPMENT LEVEL 503 SF

FIRE RESISTANCE RATING OF EXISTING BUILDING ELEMENTS

CONSTRUCTION TYPE		VB	
BUILDING ELEMENT	CODE REFERENCE	REQUIRED RATING	
PRIMARY STRUCTURAL FRAME	Table 601	0 HRS	
EXTERIOR BEARING WALLS	Table 601	0 HRS	
INTERIOR BEARING WALLS	Table 601	0 HRS	
EXTERIOR NONBEARING WALLS AND PARTITIONS	Table 602	0 HRS	
INTERIOR NONBEARING WALLS AND PARTITIONS	Table 601	0 HRS	
FLOOR CONSTRUCTION & SECONDARY MEMBERS	Table 601	0 HRS	
ROOF CONSTRUCTION & SECONDARY MEMBERS	Table 601	0 HRS	
SHAFT ENCLOSURES (Less than 4 stories)	713.4	1 HR	
EXIT ENCLOSURES (Less than 4 stories)	1023.2	1 HR	
FIRE PARTITIONS	708.3	1 HR	
SMOKE BARRIERS	709.3	1 HR	
SMOKE PARTITIONS	710.3	0 HRS	
CORRIDORS	Table 1020.2	0 HRS	

VCC TABLE 721.1(2)

RATED FIRE-RESISTANCE PERIODS FOR VARIOUS WALLS AND PARTITIONS

MATERIAL	ITEM NUMBER	CONSTRUCTION	4 HR	3 HR	2 HR	1 HR
3. CONCRETE MASONRY UNITS	3-1.1	EXPANDED SLAG OR PUMICE	4.7	4.0	3.2	2.1
	3-1.2	EXPANDED CLAY, SHALE OR SLATE	5.1	4.4	3.6	2.6
	3-1.3	LIMESTONE, CINDERS OR AIR COOLED SLAG	5.9	5.0	4.0	2.7
	3-1.4	CALCAREOUS OR SILICEOUS GRAVEL	6.2	5.3	4.2	2.8

VCC TABLE 721.1(2)

12" = 1'-0"

J
I
H
G
F
E
D
C
B
A

TERMINATION GENERAL NOTES

A. AT FIRE-, SMOKE-, AND ACOUSTICALLY RATED WALLS: SEAL ALL NON-OBSTRUCTED HEAD-OF-WALL CONDITIONS IN ACCORDANCE WITH JOINT SYSTEM MANUFACTURER'S RECOMMENDATIONS BASED ON CONDITION ENCOUNTERED (E.G., CMU-TO-DECK (PARALLEL OR PERPENDICULAR TO FLUTES), OR CFSF-TO-DECK (PARALLEL OR PERPENDICULAR TO FLUTES) TO MAINTAIN ASSEMBLY RATING CONSISTENT WITH WALL/PARTITION REQUIREMENTS. BRACE WALL AS INDICATED OR REQUIRED.

B. AT ALL OTHER WALLS INDICATED TO EXTEND TO UNDERSIDE OF FLOOR/ROOF DECK/CAP: SEAL ALL NON-OBSTRUCTED HEAD-OF-WALL CONDITIONS IN ACCORDANCE WITH JOINT SYSTEM MANUFACTURER'S RECOMMENDATIONS BASED ON CONDITION ENCOUNTERED (E.G., CMU-TO-DECK (PARALLEL OR PERPENDICULAR TO FLUTES), OR CFSF-TO-DECK (PARALLEL OR PERPENDICULAR TO FLUTES), BRACE WALL AS INDICATED OR REQUIRED.

C. AT ALL WALLS PREVENTED FROM TERMINATING AT THE UNDERSIDE OF FLOOR/ROOF DECK BY OBSTRUCTIONS, COMPLY WITH THE FOLLOWING:

- AT FIRE-, SMOKE-, AND ACOUSTICALLY-RATED WALLS: ENCASE OBSTRUCTION(S) TO MAINTAIN ASSEMBLY RATING CONSISTENT WITH WALL/PARTITION REQUIREMENTS.
- AT SECURITY WALLS: TERMINATE IN ACCORDANCE WITH SECURITY PARTITION REQUIREMENTS.
- AT OTHER WALLS: ENCASE OBSTRUCTION(S) ON ONE SIDE.
- SEAL ENCASEMENT TO WALL AND SEAL ENCASEMENT TO DECK IN ACCORDANCE WITH JOINT SYSTEM MANUFACTURER'S RECOMMENDATIONS AND TO MAINTAIN ASSEMBLY RATING CONSISTENT WITH WALL/PARTITION REQUIREMENTS.

TERMINATIONS

REFER TO GENERAL NOTE 'C'

C OF OBSTRUCTION

BOTTOM OF DECK

CFSF-S W/ GYP BD IN LAYERS AS REQUIRED TO MAINTAIN ASSEMBLY RATING CONSISTENT WITH WALL/PARTITION REQUIREMENTS

BRACE WALL AS INDICATED, OR WHERE NOT INDICATED, AS APPROVED

ENCASEMENT REFER TO GENERAL NOTE 'C'

DO NOT SECURE ENCASEMENT TO WALL

SEALANT SYSTEM: REFER TO GENERAL NOTE 'C'

MAY VARY

MAY VARY

HEAD-OF-WALL TERMINATION @ OBSTRUCTION

OBSTRUCTION MAY VARY (BEAM, JOIST, GIRDER, CHANNEL, DUCTWORK, PIPING)

REFER TO APPLICABLE GENERAL NOTE 'A' OR 'B'

BOTTOM OF DECK OR CAP

BRACE WALL AS INDICATED, OR WHERE NOT INDICATED, AS APPROVED

WALL/PARTITION MAY VARY

HEAD-OF-WALL TERMINATION @ NON-OBSTRUCTION

WALL JOINTS

RATED/
NON-
RATED
CFSF/
PANELS

RATED PANEL WALL

PANEL JOINT OR RATED JOINT SYSTEM AT RATED PANEL CONSTRUCTION

CONTINUE RATED CONSTRUCTION BETWEEN INTERSECTION

NON-RATED PANEL WALL

PANEL JOINT OR RATED JOINT SYSTEM AT RATED PANEL CONSTRUCTION

NOTE: RATED WALL SHADED FOR CLARITY THIS DETAIL

CMU

CFSF/
PANELS

SHEATHING WHERE INDICATED

PANEL WALL

PANEL JOINT OR RATED JOINT SYSTEM AT RATED PANEL CONSTRUCTION WHERE OCCURS

SUBSTRATE JOINT WHERE OCCURS

FACE OF BACKUP

WALL TYPE VARIES

PANEL JOINT OR RATED JOINT SYSTEM AT RATED PANEL CONSTRUCTION WHERE OCCURS

CMU/
CFSF

SUPPORTING CONSTRUCTION WILL VARY, PROVIDE WALL JOINT WHERE THE SUPPORTING CONSTRUCTION CHANGES WITHIN THE PLANE OF THE PANEL FINISH

PANEL JOINT OR RATED JOINT SYSTEM AT RATED PANEL CONSTRUCTION

PANEL

RATED/
NON-
RATED
CMU

RATED CMU

NON-RATED CMU

RATED JOINT ASSEMBLY TO MATCH RATING OF WALL, BOTH SIDES

NON-RATED EXTERIOR CMU WYTHE

RATED CMU

NON-RATED CMU

INTERIOR PANEL FURRING, WHERE OCCURS

PANEL JOINT OR RATED JOINT SYSTEM AT RATED PANEL CONSTRUCTION

NOTE: RATED WALLS SHADED FOR CLARITY THIS DETAIL

WALL/PARTITION TYPE GENERAL NOTES

A. PLAN DIMENSIONS ARE TO FACE OF WALL OR PARTITION. WHERE APPLIED FINISHES OCCUR-SUCH AS CERAMIC TILE-DIMENSIONS ARE TO FACE OF APPLIED FINISH. FOR WAINSCOTS, FLOOR PLAN DIMENSIONS ARE TO FACE OF WAINSCOT MATERIAL. APPLIED FINISHES ARE NOT ALLOWED TO REDUCE CLEAR DIMENSIONS. "APPLIED FINISHES" IN THIS CASE DO NOT INCLUDE TRIM, BASE, AND ACOUSTIC WALL PANELS.

B. EXTEND WALL/PARTITION ASSEMBLY COMPONENTS FULL HEIGHT OF ASSEMBLY.

C. ALL INTERIOR MASONRY UNIT PARTITIONS: M6 UNLESS INDICATED OTHERWISE.

D. ALL INTERIOR CFSF PANEL PARTITIONS: P1 UNLESS INDICATED OTHERWISE.

E. REFER TO STRUCTURAL DRAWINGS AND RELATED SPECIFICATIONS FOR SOLID MASONRY, GROUTING, AND REINFORCEMENT REQUIREMENTS INCLUDING BUT MAY NOT BE LIMITED TO:

- MASONRY WALLS/PARTITIONS
- LINTELS
- LINTEL BEARING CONDITIONS
- BOND BEAMS
- SHELF BEARING CONDITIONS
- STRUCTURAL REINFORCING REQUIREMENTS
- CHANGES IN WYTHE

F. THE TERMS "WALL" AND "PARTITION" MAY BE USED INTERCHANGEABLY THROUGHOUT THE CONTRACT DOCUMENTS.

G. EXTEND ALL FIRE-, SMOKE-, INCIDENTAL USE-, AND ACOUSTICAL-RATED WALLS/PARTITIONS TO UNDERSIDE OF FLOOR DECK, ROOF DECK, STRUCTURAL ELEMENT ENCASEMENT OR SOLID CAP ABOVE.

- SEAL AND TERMINATE IN ACCORDANCE WITH JOINT SYSTEM TESTED ASSEMBLIES FOR RESPECTIVE TYPE OF WALLS/PARTITIONS.

H. PARTITIONS THAT DO NOT EXTEND TO UNDERSIDE OF DECK OR CAP ABOVE:

- EXTEND 4 INCHES MINIMUM ABOVE HIGHEST ADJACENT FINISH CEILING UNLESS INDICATED OTHERWISE.

I. DO NOT CONNECT TIES, ANCHORS, OR REINFORCING TO SINGLE CANTILEVERED FIRE WALL OR BETWEEN DOUBLE FIRE WALLS.

J. SEAL AROUND ALL PENETRATIONS.

K. COMPLY WITH TERMINATION, WALL JOINT, AND MISCELLANEOUS DETAILS FOR THOSE CONDITIONS WHERE APPLICABLE. COMPLY WITH REFERENCED STANDARDS WHERE DETAILS ARE NOT IDENTIFIED IN THE DRAWINGS.

L. WALL/PARTITION TYPES DO NOT ADDRESS WALL FINISHES. REFER TO FINISH SCHEDULE.

M. FINISHED SPACES: PROVIDE CHASES AROUND ALL EXPOSED VERTICAL COMPONENTS, INCLUDING BUT NOT LIMITED TO: DUCTWORK, PIPING, AND CONDUIT, UNLESS COMPONENTS ARE SPECIFICALLY INDICATED TO REMAIN EXPOSED. IF NOT OTHERWISE INDICATED, PROVIDE P2 CHASE CONSTRUCTION.

- HOLD CHASES TIGHT TO COMPONENTS ALLOWING FOR ACCESS, INSULATION, AND TOLERANCES.
- EXTEND CHASES FROM FLOOR TO 4 INCHES MINIMUM ABOVE FINISH CEILING OR IF NO CEILING IS INDICATED, EXTEND CHASES TO UNDERSIDE OF FLOOR DECK, ROOF DECK, OR SOLID CAP ABOVE AND TERMINATE ACCORDINGLY.

N. PROVIDE BACKER BOARD/UNIT OF SAME THICKNESS INDICATED IN LIEU OF GYPSUM BOARD PANEL AT PORTIONS OF WALLS/PARTITIONS TO RECEIVE TILE.

MASONRY UNIT WALL/PARTITION TYPES			
REPRESENTED BY X _m			
MARK	FIRE RATED ASSEMBLY (REFER TO LS 1.1 FOR LEGEND)	REMARKS	INFORMATION
M6	--	--	5 5/8" 6" CMU
M8	--	--	7 5/8" 8" CMU

PANEL WALL/PARTITION TYPES			
REPRESENTED BY X _m			
MARK	FIRE RATED ASSEMBLY (REFER TO LS 1.1 FOR LEGEND)	REMARKS	INFORMATION
P1	--	--	4 7/8" 5/8" GYPSUM BOARD 3/8" CFSF-NS 3" SOUND ATTENUATION BATTS
P2	--	--	4 1/4" 5/8" GYPSUM BOARD 3/8" CFSF-NS 3" SOUND ATTENUATION BATTS
P3	--	--	4 9/32" 5/8" LEAD LINED GYPSUM BOARD 3/8" CFSF-NS 3" SOUND ATTENUATION BATTS
P4	--	--	2 1/8" 2 LAYERS 5/8" GYPSUM BOARD 7/8" CFSF
P5	--	--	4" 5/8" GYPSUM BOARD 4" CFSF-NS
P6-1	X1	--	7 1/4" 5/8" GYPSUM BOARD 6" CFSF-NS SOUND ATTENUATION BATTS
P7-1	X4	--	4 5/8" 5/8" TYPE X GYP BD 4" CH STUD 1" SHAFTWALL LINER BD

MOSELEYARCHITECTS

5200 NORFOLK STREET, RICHMOND, VA 23230
PHONE (804) 784-7555 FAX (804) 355-5690
MOSELEYARCHITECTS.COM

COMMONWEALTH OF VIRGINIA
JOSEPH A. NATHAN BENNETT
Lic. No. 0401013563
8/18/2025
ARCHITECT

HENRICO COUNTY ANIMAL SHELTER RENOVATION

10421 WOODMAN ROAD, GLEN ALLEN, VA 23060
HENRICO COUNTY

PROJECT NO: 615225
DATE: AUGUST 18, 2025

REVISIONS

DATE DESCRIPTION

WALL/PARTITION TYPES, WALL JOINTS AND TERMINATIONS

A0.2

PHASING SCHEDULE							
PHASE/ACTIVITY	MONTH 1	MONTH 2	MONTH 3	MONTH 4	MONTH 5	MONTH 6	MONTH 7
PRECONSTRUCTION - SUBMITTALS							
PHASE 1 - VETERINARY SUITE AND SURGERY							
PHASE 2 - OFFICES AND WORK AREAS							
PHASE 3 - KENNELS							
PHASE 4 - REMAINING INSULATION/MECHANICAL WORK*							
*SCHEDULE ALLOWS FOR SUBMITTAL AND PROCUREMENT TIME FOR THE MECHANICAL AIR HANDLING UNIT (ERU-1). INSTALLATION OF ERU-1 ANTICIPATED FOR PHASE 4.							

PHASING LEGEND

PHASE 1

PHASE 2

PHASE 3


PHASE 4

GENERAL PHASING NOTES

1. THE PHASING PLAN IS GENERAL IN NATURE AND FOR REFERENCE ONLY TO PROVIDE A PRIORITIZED TIMELINE. IT DOES NOT REFLECT CONTRACTUAL DATES, ACTUAL SUMS OF TIME, OR PRECISE LOCATIONS OF CONSTRUCTION. CONTRACTOR TO PROVIDE DETAILED PHASING SCHEDULE TO OWNER/ARCHITECT FOR REVIEW.


2. MAINTAIN UTILITIES AND CONDITIONED AIR TO ALL OCCUPIED AREAS THROUGHOUT CONSTRUCTION. PROVIDE TEMPORARY MEASURES NECESSARY TO MAINTAIN EXISTING CONDITIONS.

3. GC SHALL MAINTAIN REQUIRED EXITS, FIRE PROTECTION DEVICES AND SANITARY SAFEGUARDS AT ALL TIMES. WHERE SUCH REQUIRED ELEMENTS OR DEVICES ARE BEING ALTERED OR REPAIRED, MAKE ADEQUATE SUBSTITUTE PROVISIONS.

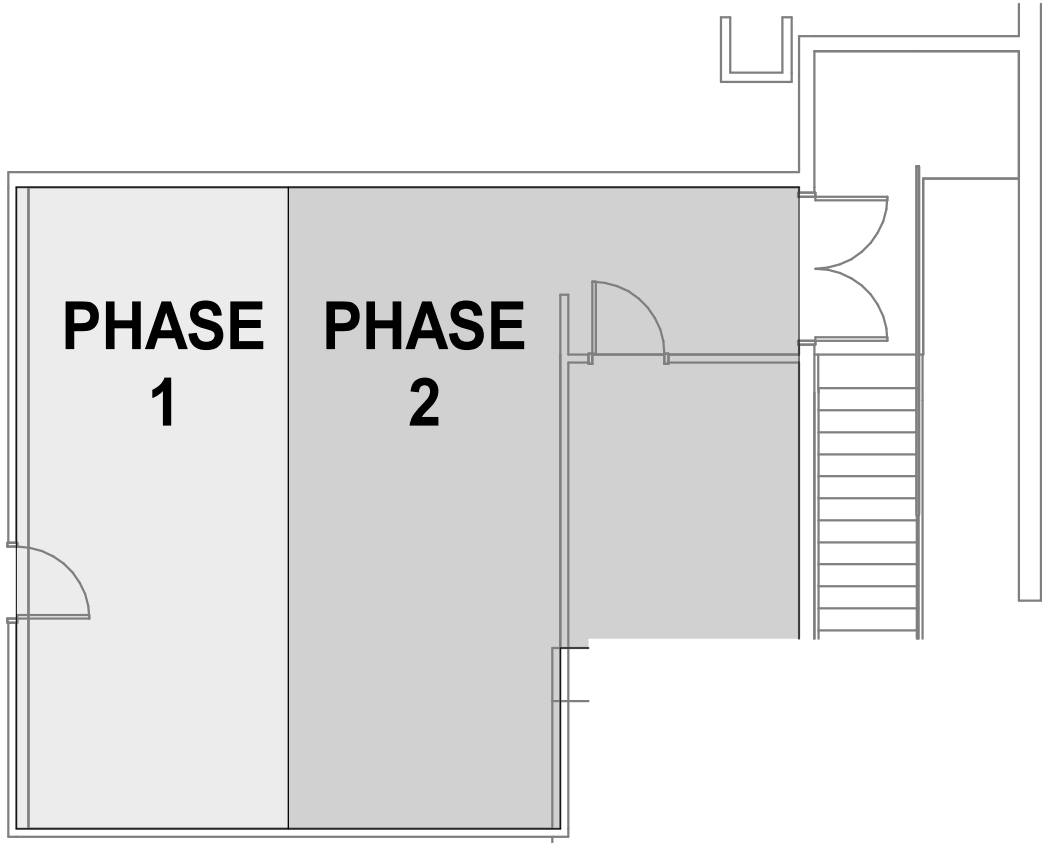

PHASING PLAN - MEZZANINE
1/8" = 1'-0"

MECHANICAL WORK IN MEZZANINE WILL OCCUR IN PHASES 1 AND 2.

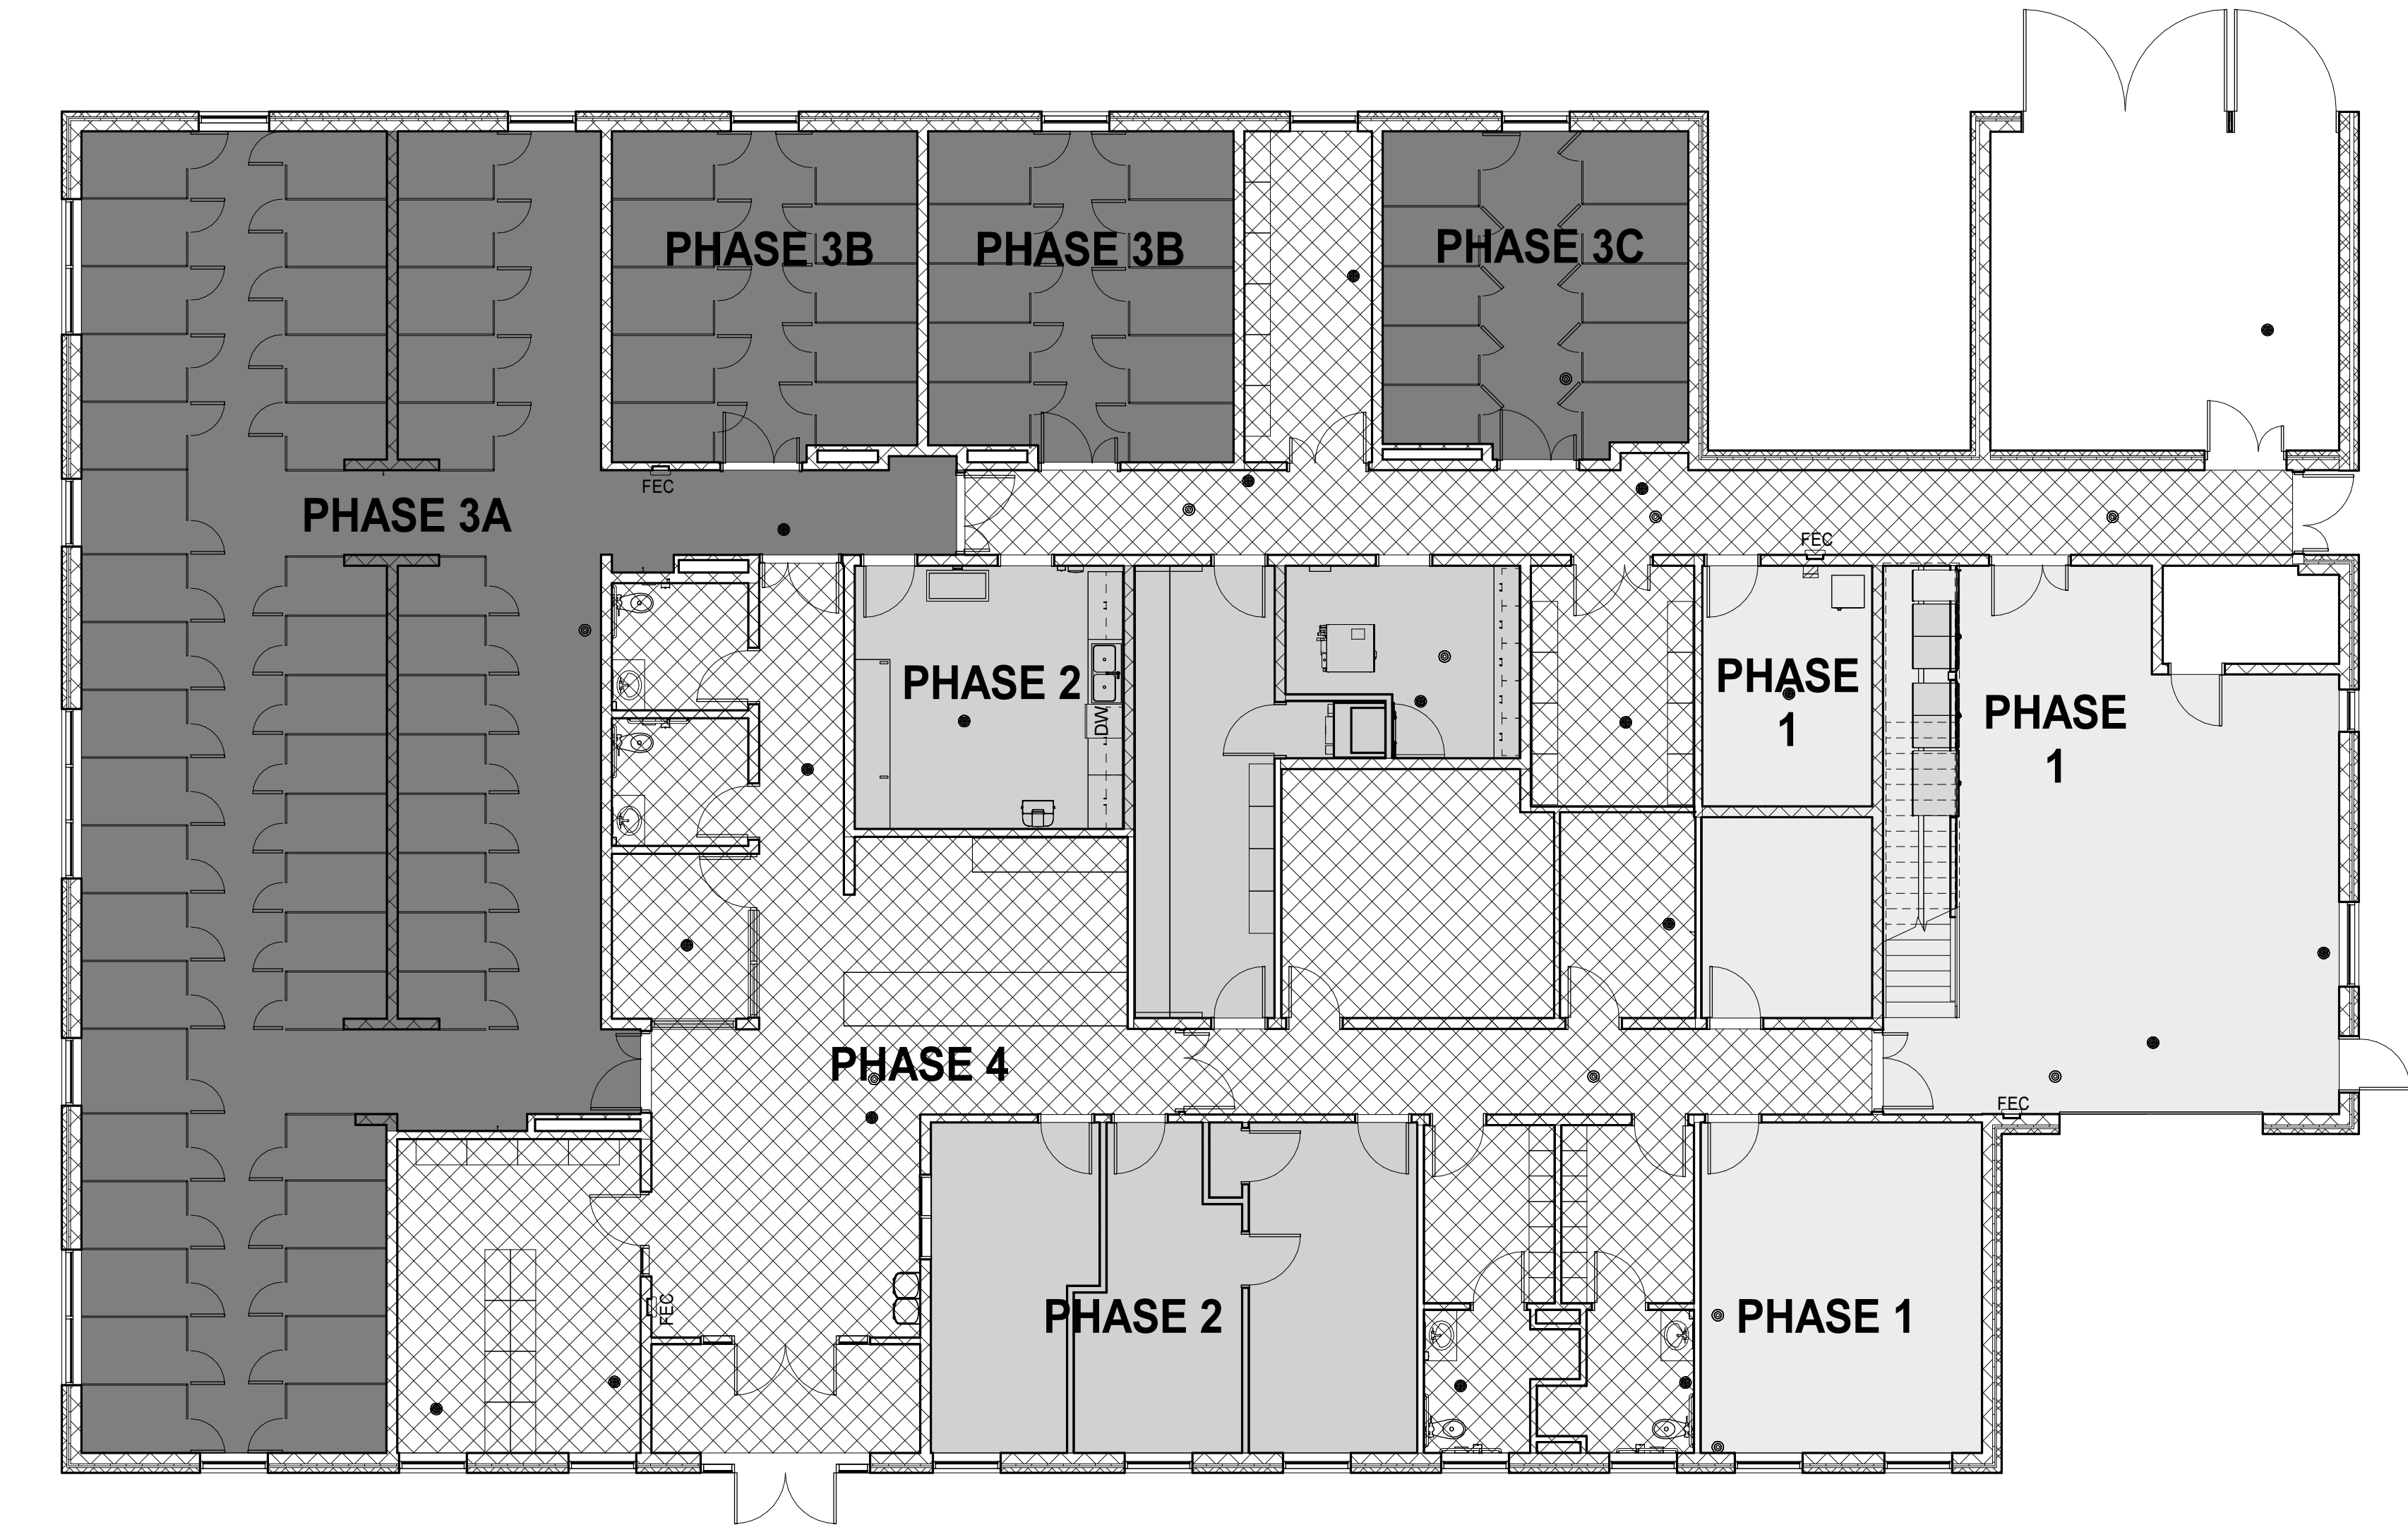


PHASING PLAN
1/8" = 1'-0"




PROJECT NO. 615225
DATE: AUGUST 18, 2025
REVISIONS
DATE DESCRIPTION


J
I
H
G
F
E
D
C
B
A

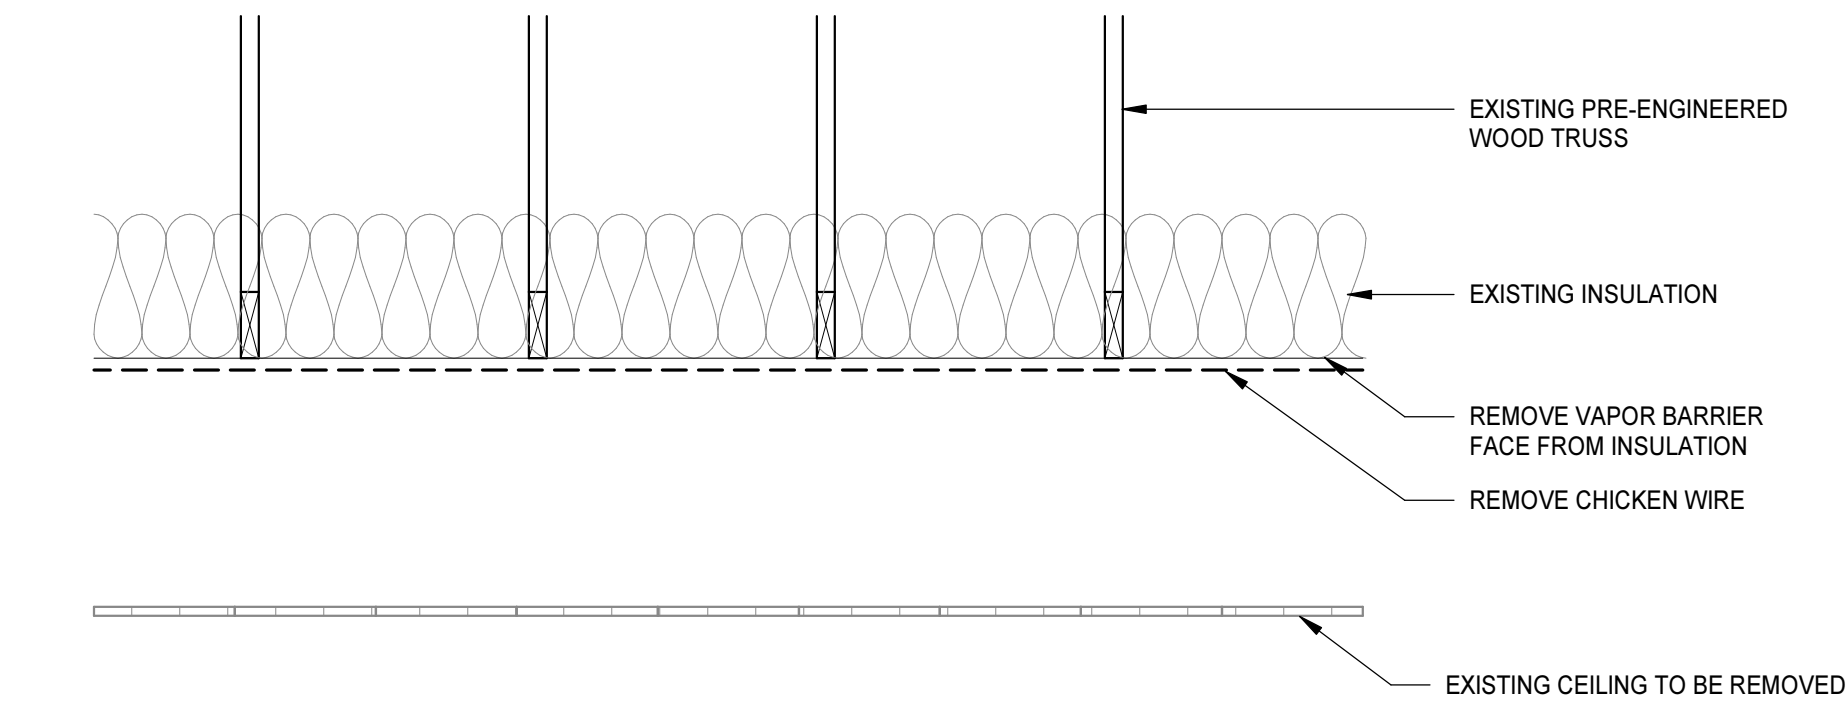


3 INSULATION DEMO DETAIL
A1.2.1 3/4" = 1'-0"

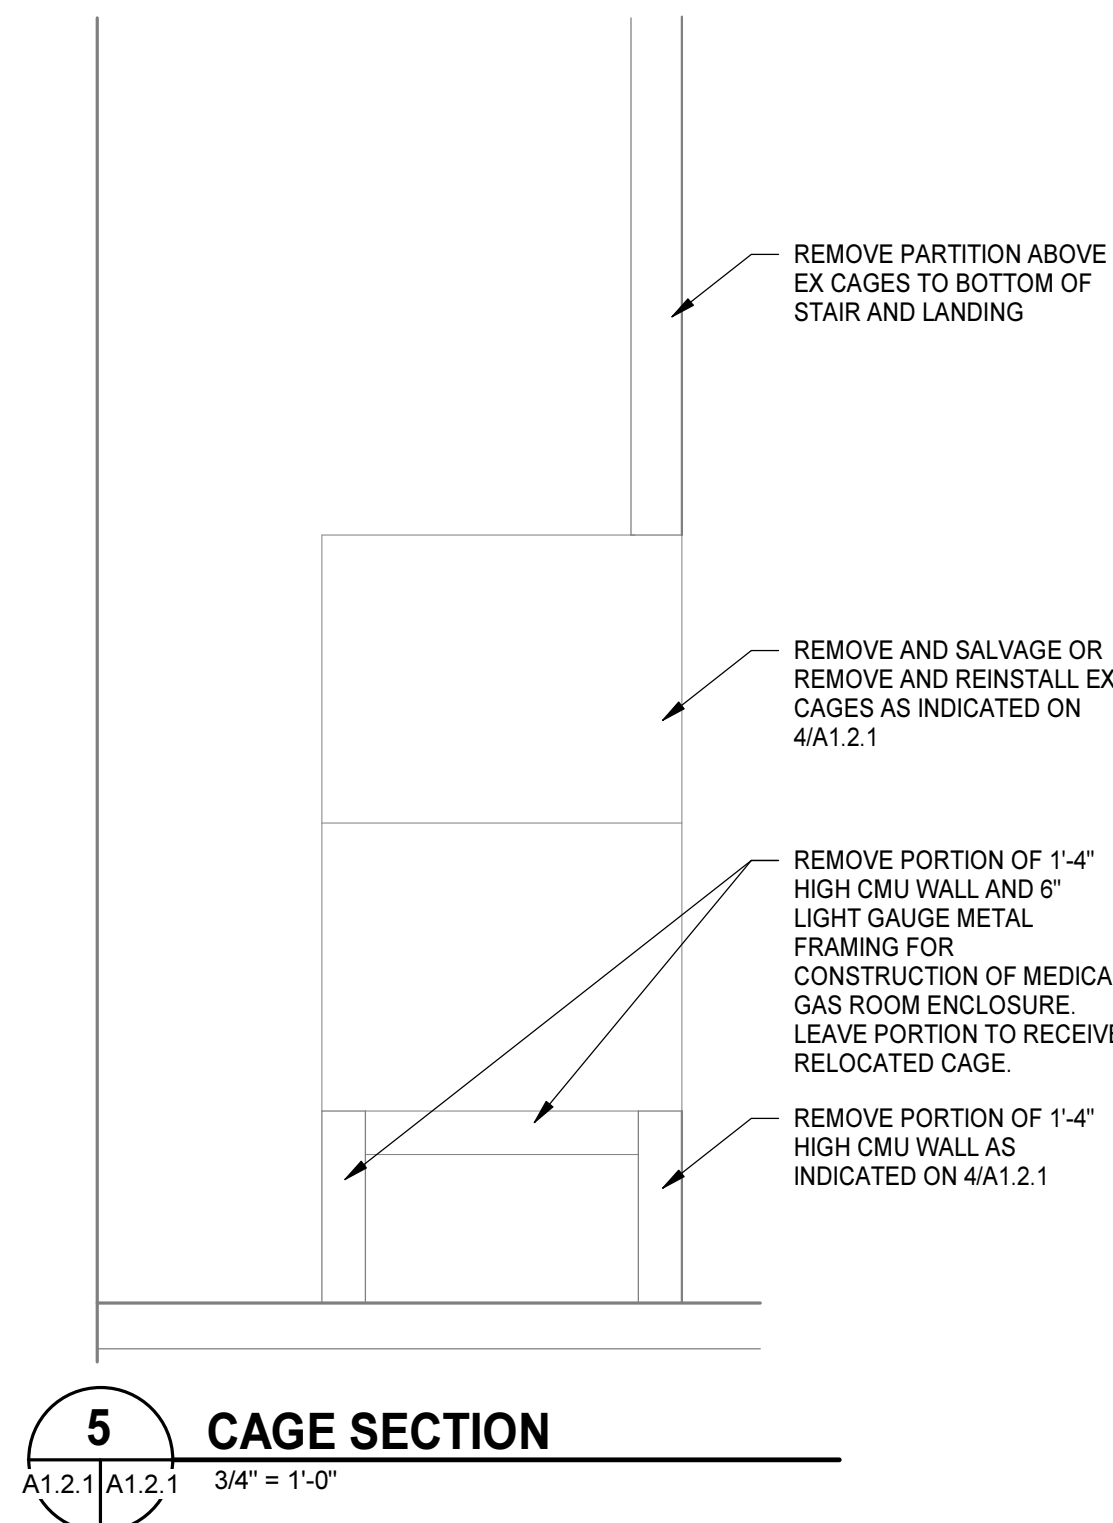



5 CAGE SECTION
A1.2.1 A1.2.1 3/4" = 1'-0"

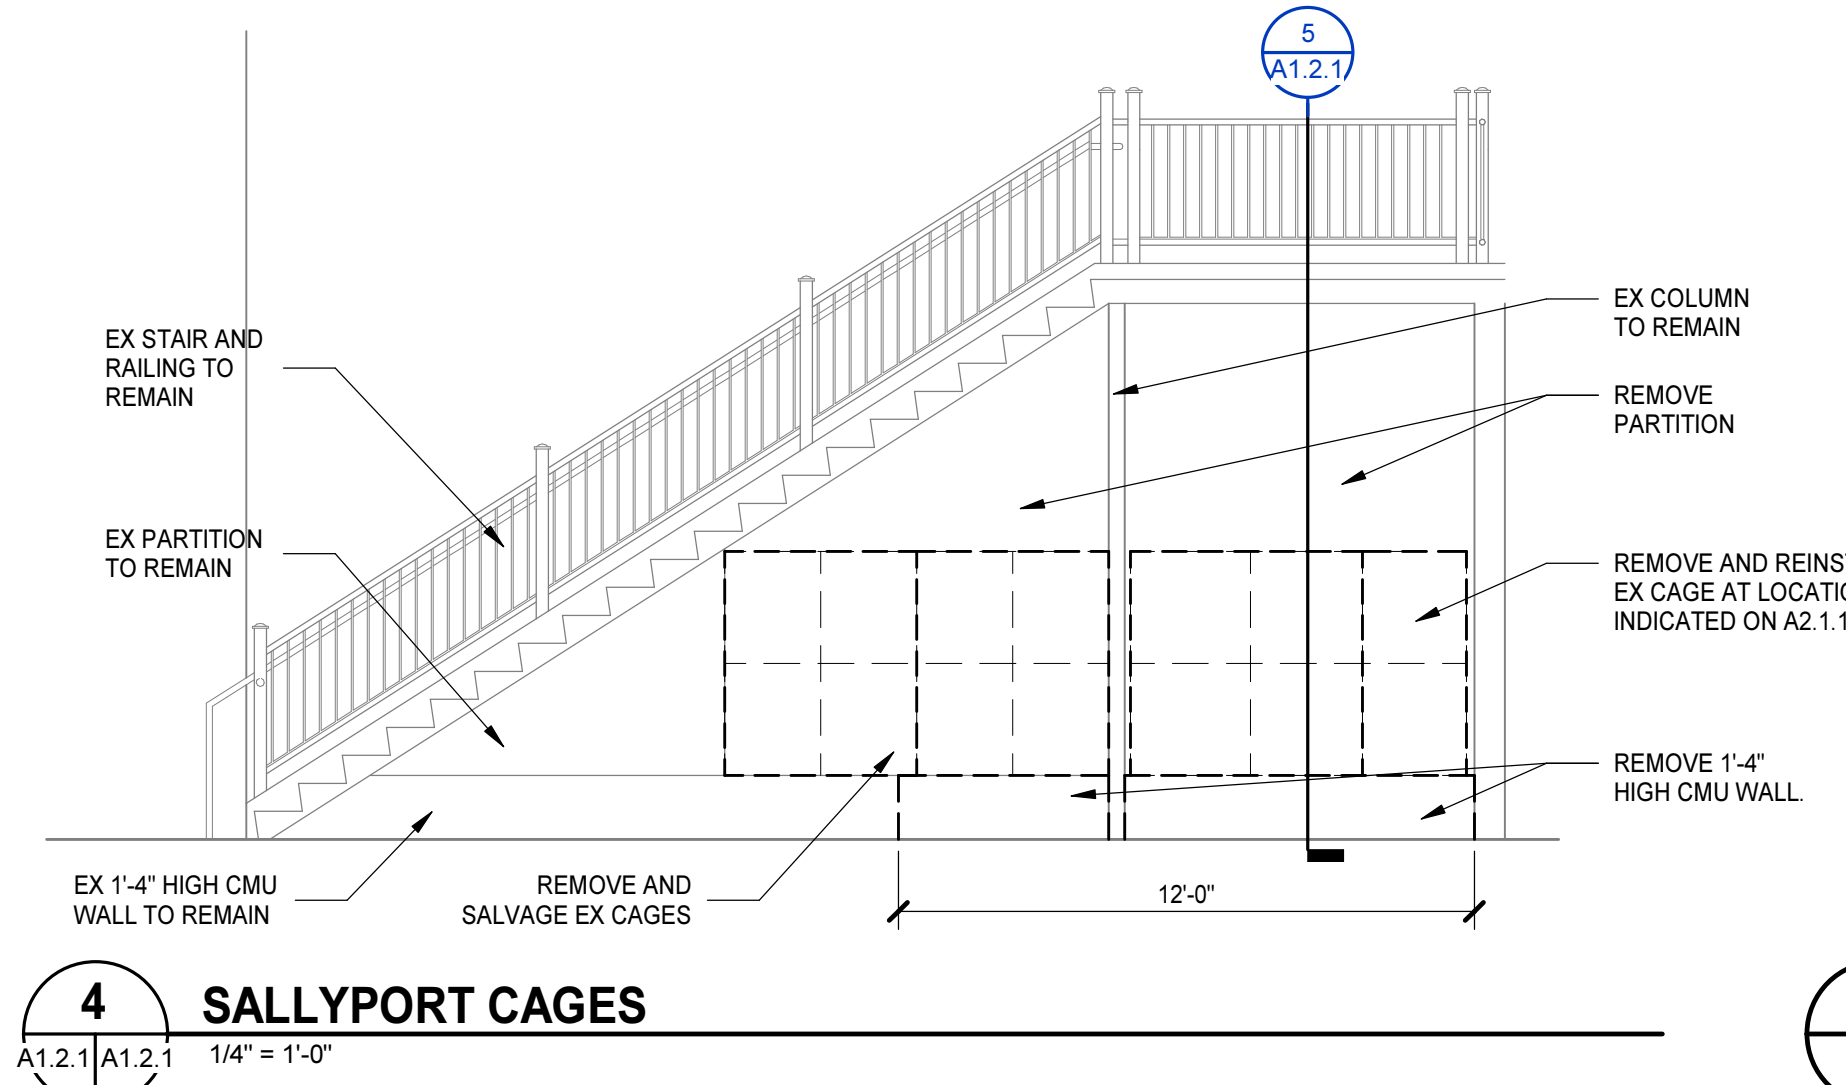


4 SALLYPORT CAGES
A1.2.1 A1.2.1 1/4" = 1'-0"

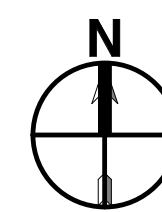

DEMOLITION REFLECTED CEILING PLAN
1/8" = 1'-0"

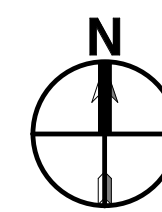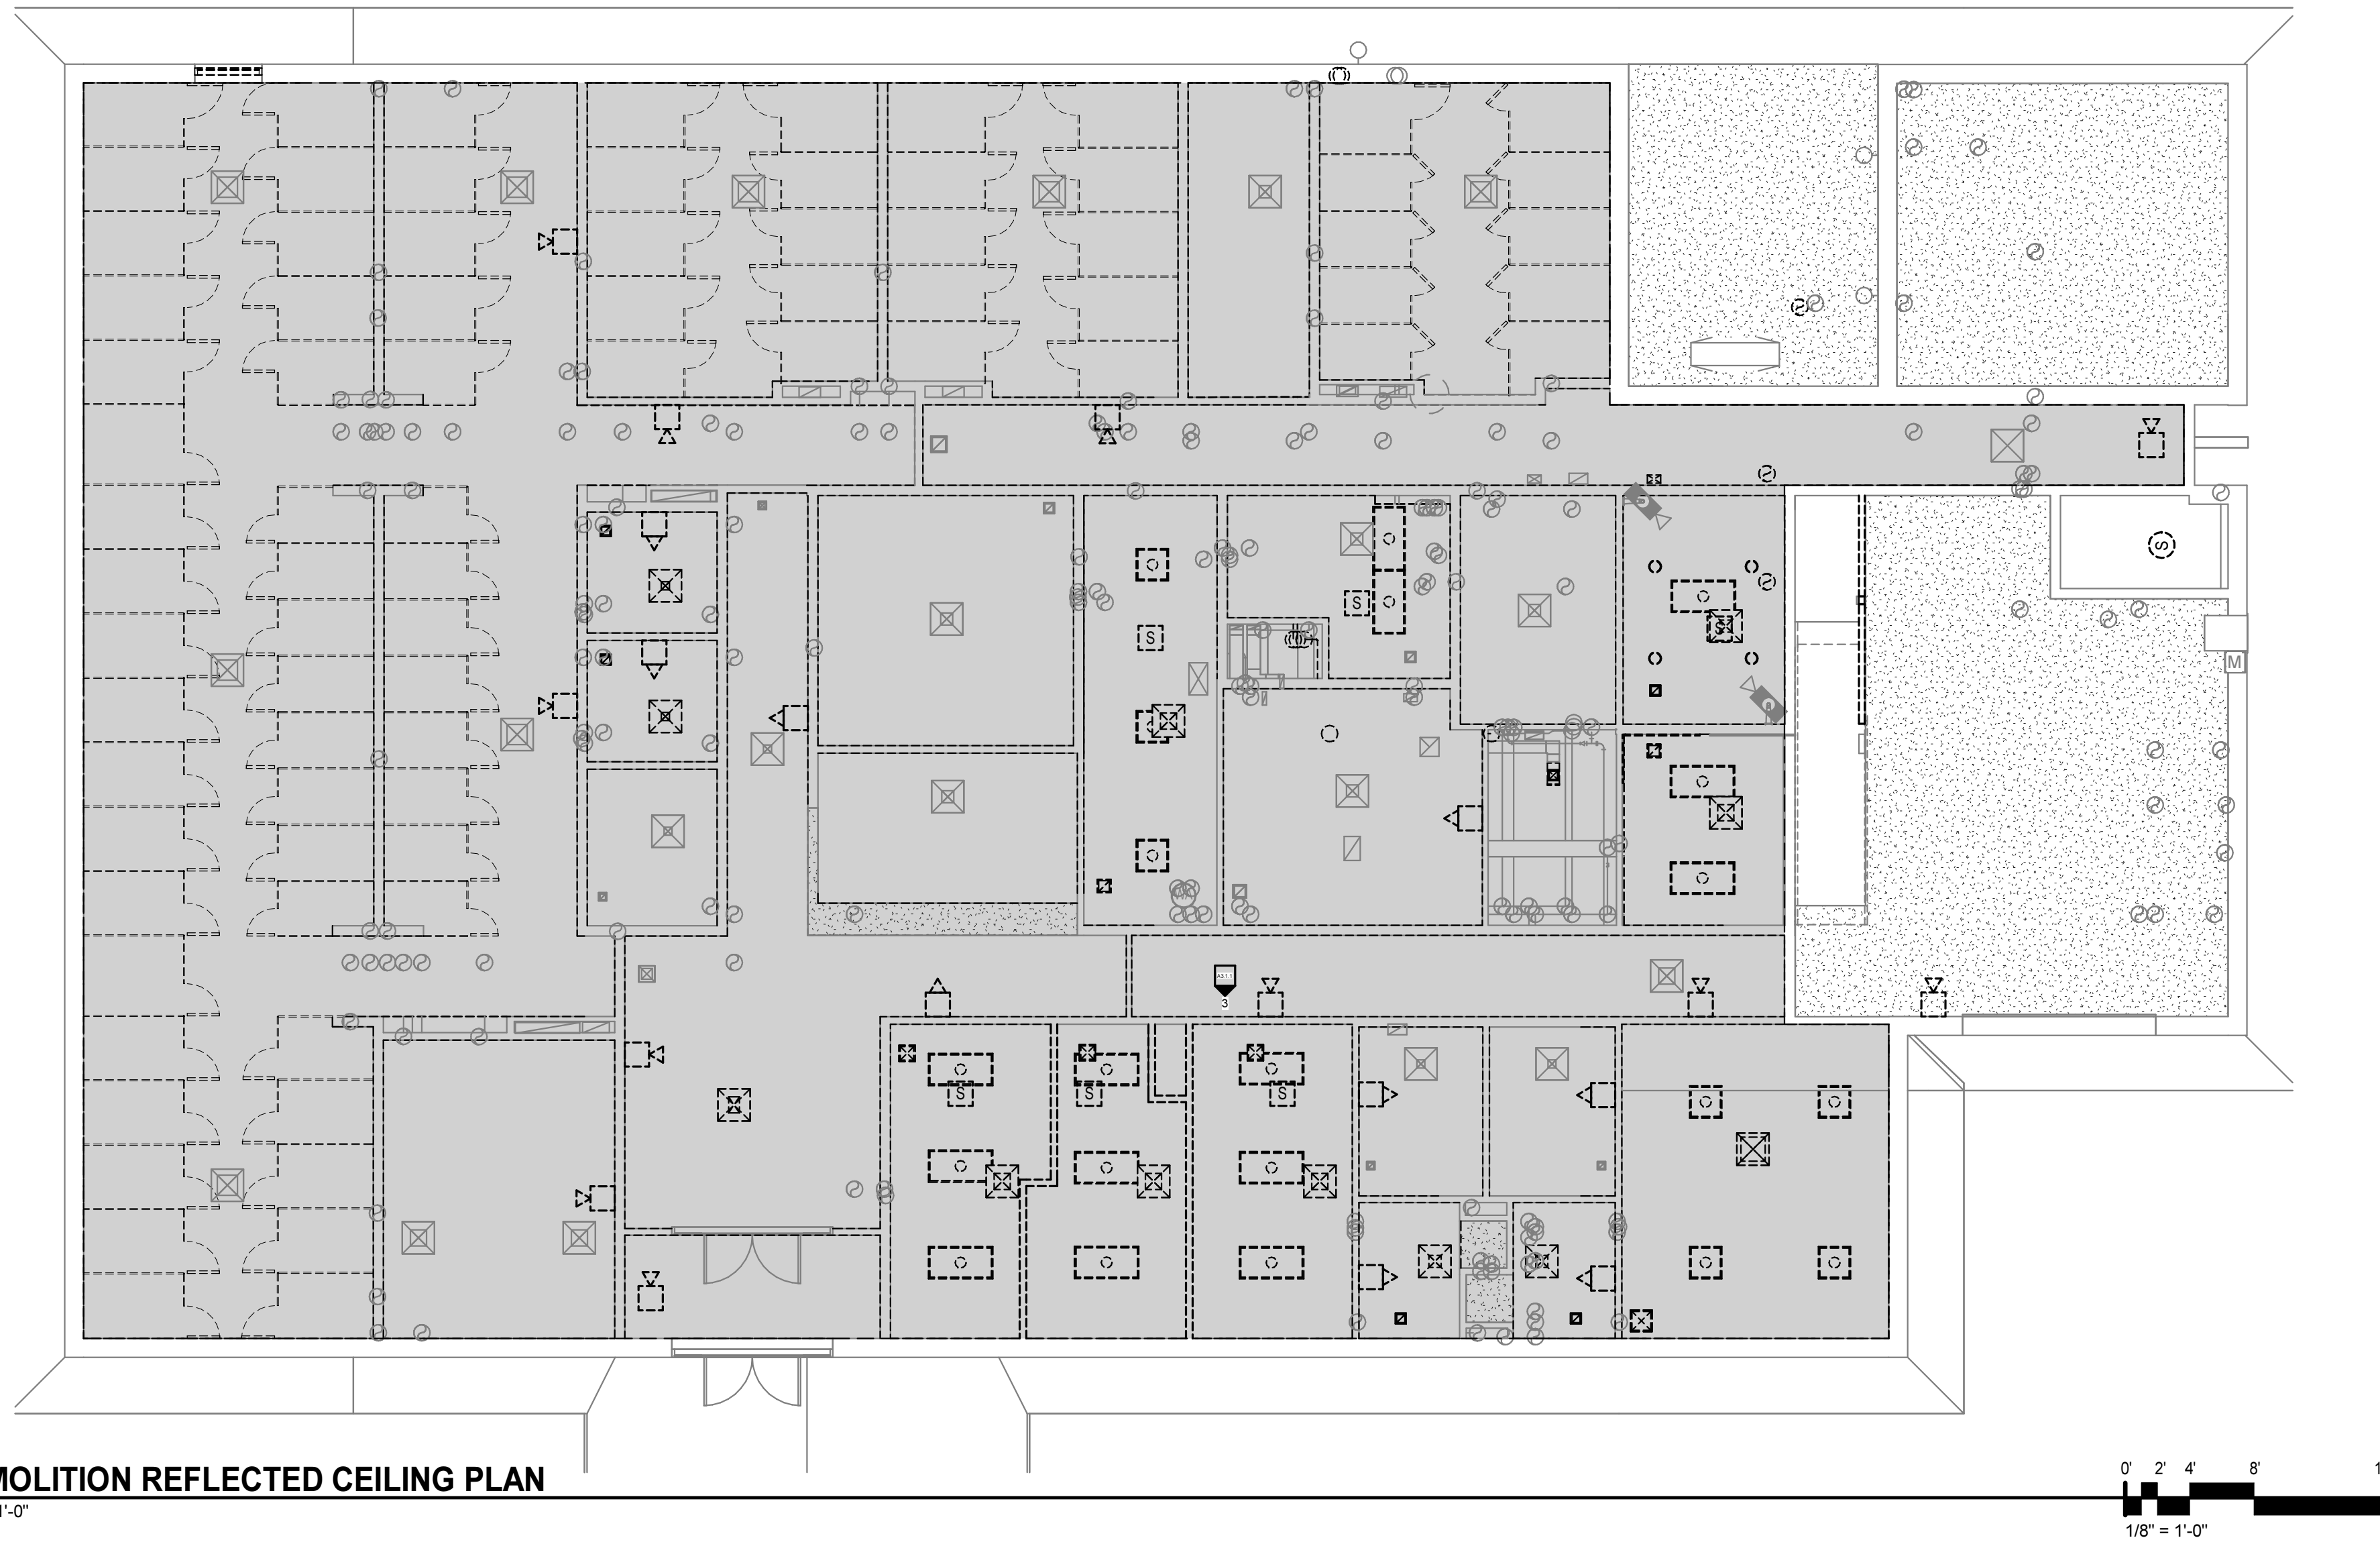

DEMOLITION FIRST FLOOR PLAN
1/8" = 1'-0"

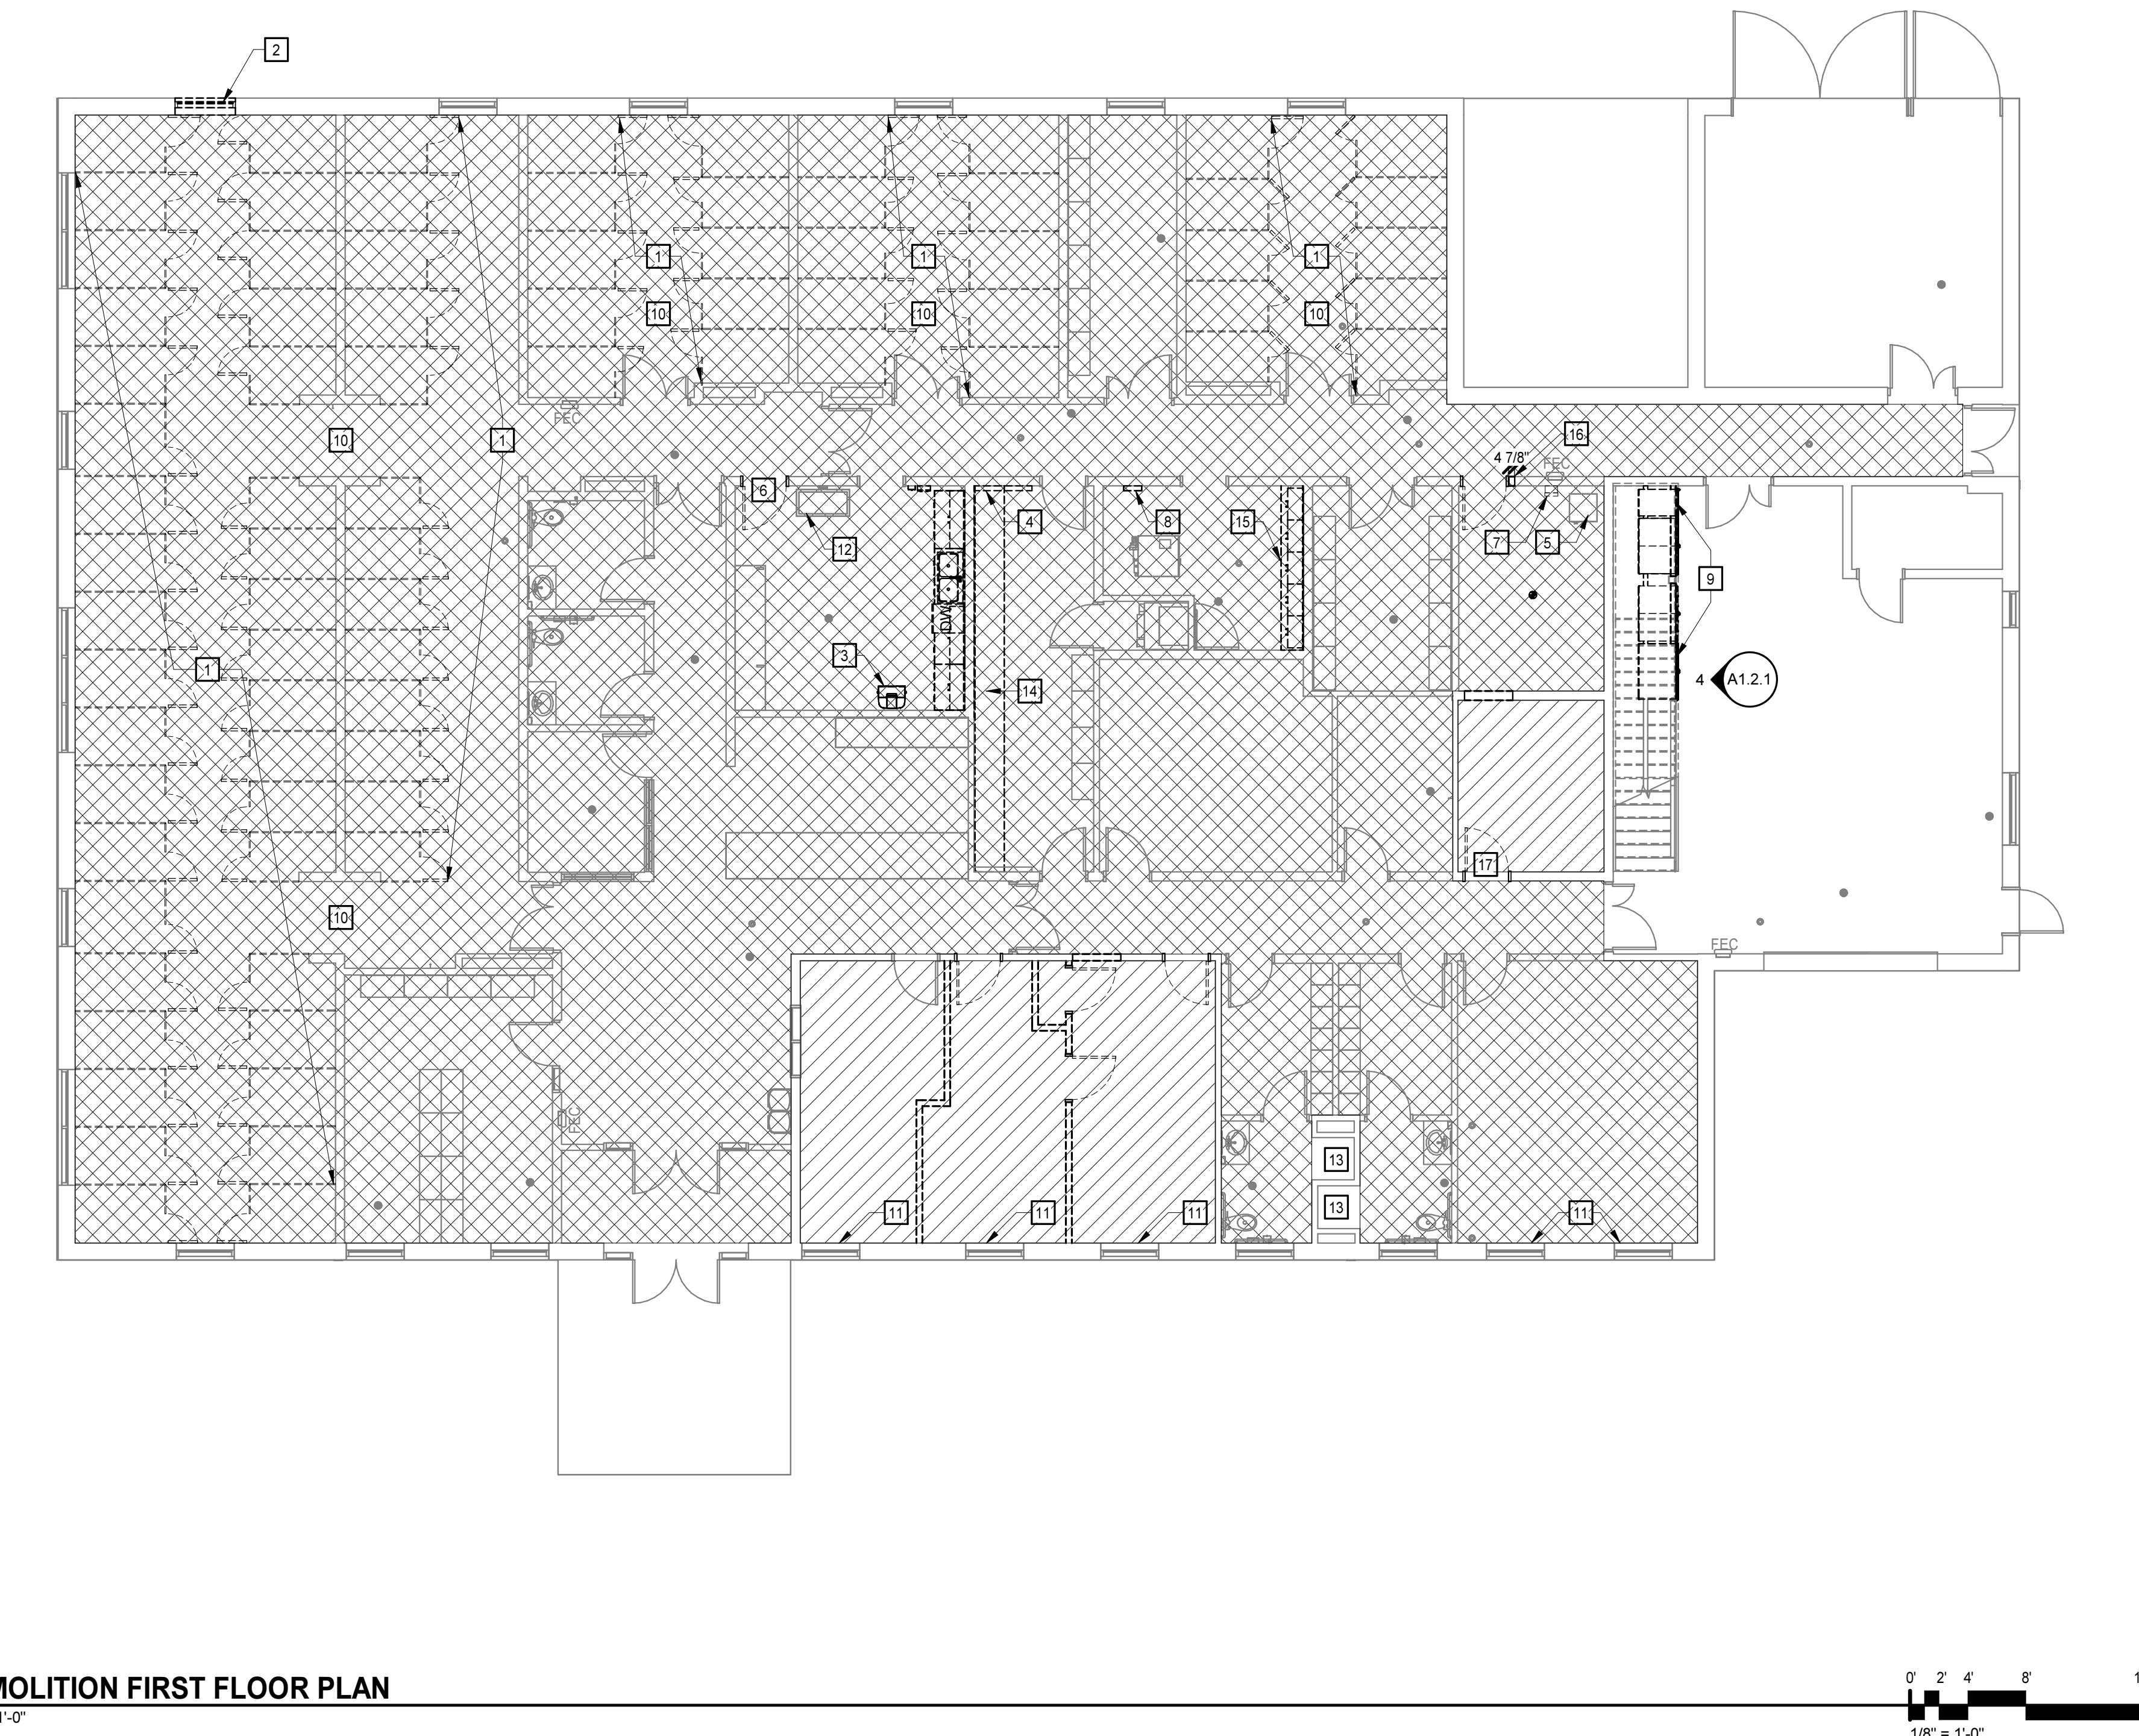

DEMOLITION PLAN LEGEND

APPLIES TO DRAWINGS A1.2.1 - A1.2.n

- EXISTING PARTITION/WALL/ITEM TO REMAIN
- REMOVE EXISTING PARTITION/WALL/ITEM
- REMOVE EXISTING WINDOW ASSEMBLY AND FRAMING, INCLUDING ANCHORS
- REMOVE EXISTING DOOR AND FRAME ASSEMBLY INCLUDING DOOR HARDWARE, ANCHORS, AND THRESHOLD (WHERE OCCURS).
- REMOVE EXISTING PLUMBING FIXTURE. REFER TO PLUMBING DEMOLITION PLAN FOR ADDITIONAL INFORMATION.
- REMOVE ALL EXISTING FINISH FLOORING, BASE, AND SUSPENDED CEILINGS IN AREA
- REMOVE VAPOR BARRIER FACE FROM UNDERSIDE OF ATTIC INSULATION
- REMOVE SUSPENDED CEILING IN AREA

DEMOLITION PLAN GENERAL NOTES



- REMOVE ALL CONSTRUCTION SHOWN DASHED OR OTHERWISE INDICATED TO BE REMOVED. REFER TO DEMOLITION KEYNOTES FOR ADDITIONAL INFORMATION.
- REPRESENTATION OF EXISTING ITEMS ARE TO BE CONSIDERED GENERAL IN NATURE AND ARE BASED UPON INFORMATION PROVIDED BY OWNER'S RECORD DRAWINGS AND BY NON-DESTRUCTIVE FIELD INVESTIGATIONS. DEMOLITION PLANS ARE NOT COMPREHENSIVE IN ALL DETAILS OF EXISTING CONSTRUCTION THAT SHALL BE REMOVED TO COMPLETE THE WORK OF THE CONTRACT.
- NOTIFY THE ARCHITECT OF ANY EXISTING CONDITIONS THAT PREVENT EXECUTION OF THE WORK INDICATED.
- COORDINATE IN THE FIELD WITH THE OWNER ALL EXISTING ITEMS TO BE SALVAGED PRIOR TO ACTUAL DEMOLITION WORK. SURFACE CLEAN AND STORE SALVAGED ITEMS AS DIRECTED BY THE OWNER. THE OWNER HAS THE FIRST RIGHT OF REFUSAL ON ALL ITEMS REMOVED FROM THE PROJECT.
- REFER TO OTHER DISCIPLINES DEMOLITION DRAWINGS FOR RELATED DEMOLITION WORK. THE ARCHITECTURAL DRAWINGS DO NOT INDICATE ALL THE DEMOLITION WORK REQUIRED IN THIS CONTRACT.
- PATCH TO MATCH ADJACENT SURFACES ALL EXPOSED SURFACES AFFECTED BY THE DEMOLITION WORK THAT SHALL REMAIN EXPOSED TO VIEW UNLESS SPECIFICALLY INDICATED OTHERWISE.

DEMOLITION PLAN KEYNOTES

REPRESENTED BY **1**
APPLIES TO DRAWINGS A1.2.1

- REMOVE DOG KENNEL
- REMOVE WINDOW ENLARGE OPENING IN WALL TO ACCOMMODATE DOOR. REFER TO DOOR SCHEDULE FOR DOOR SIZE AND TYPE.
- REMOVE EYEWASH STATION
- REMOVE TACK BOARD
- EXISTING SAFE TO REMAIN
- REMOVE DOOR, FRAME, AND ASSOCIATED HARDWARE
- REMOVE PAPER TOWEL DISPENSER
- REMOVE EYEWASH STATION
- REMOVE CAGES. REFER TO 4/A1.2.1
- REMOVE ALL WALL BASE IN KENNEL AREA
- REMOVE WINDOW SHADES
- EXISTING SCALE TO REMAIN
- CEILING ABOVE SHOWERS TO REMAIN
- REMOVE COUNTER AND SUPPORTS
- REMOVE CASEWORK CABINETS AND COUNTER
- REMOVE PORTION OF WALL
- REMOVE DOOR, FRAME TO REMAIN

8/18/2025 12:47:24 PM

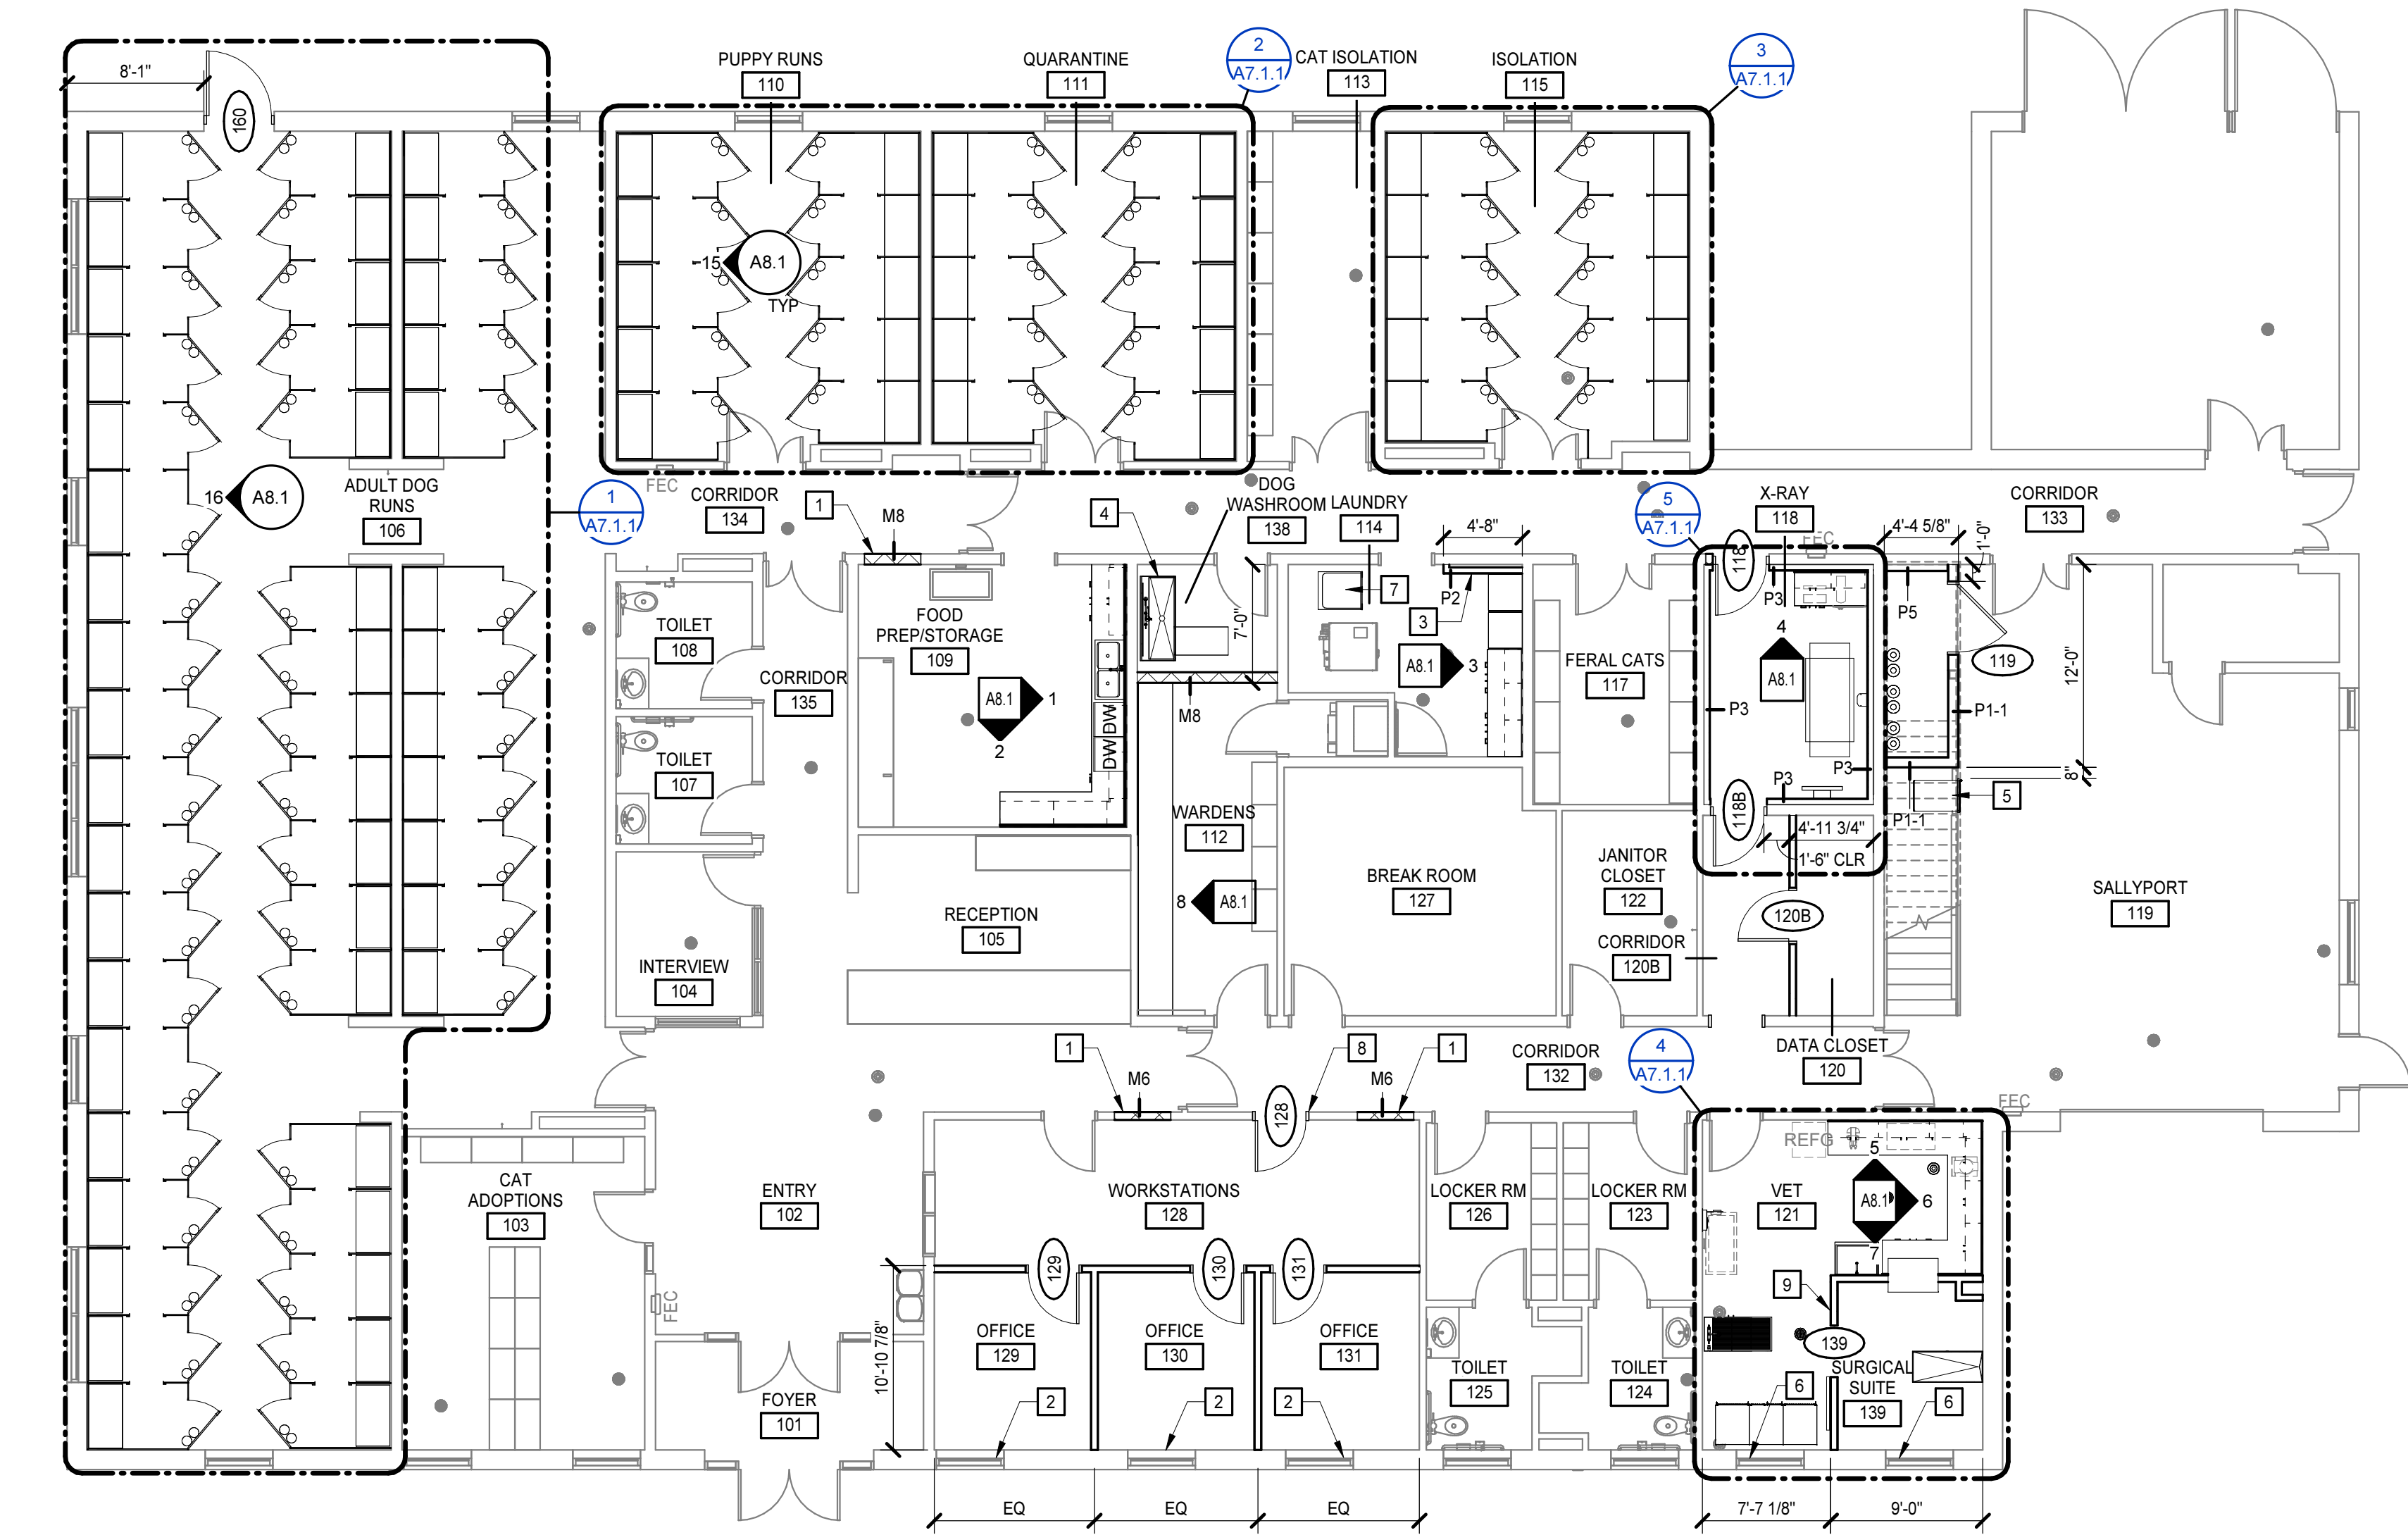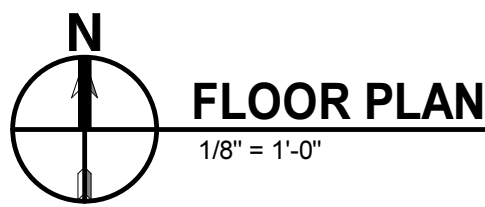

FLOOR PLAN KEYNOTES


REPRESENTED BY **1**
APPLIES TO DRAWINGS A2.1

- INFILL OPENING. MATCH ADJACENT CONSTRUCTION.
- HORIZONTAL LOUVER BLINDS
- RECESSED EYEWASH. INSTALL PANIC BAR AT 48" AFF MAX TO COMPLY WITH ACCESSIBLE REACH RANGES.
- GROOMING TUB WITH LEFT HAND RAMP
- REINSTALL CAGE. PROVIDE STAINLESS STEEL ANGLE CLOSURE ON ALL SIDES AS REQUIRED.
- SOLAR CONTROL WINDOW FILM
- FRONT-LOAD WASHER
- PROVIDE (2)-L3 1/2x2 1/2x6'18" (LONG LEG VERTICAL AND BACK-TO-BACK) BEAR 4" INTO SOUND AND SOLID CMU
- PUSH BUTTON DOOR OPERATOR

HENRICO COUNTY ANIMAL SHELTER RENOVATION

10421 WOODMAN ROAD, GLEN ALLEN, VA 23060
HENRICO COUNTY

PROJECT NO. 615225	DATE: AUGUST 18, 2025
REVISIONS	
DATE	DESCRIPTION

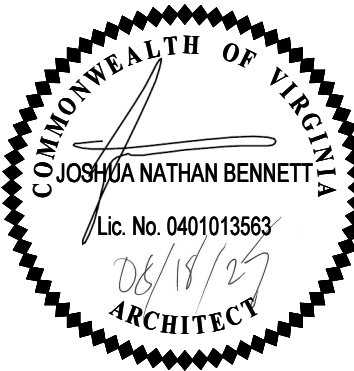


MOSELEYARCHITECTS

5200 NORFOLK STREET, RICHMOND, VA 23230
PHONE (804) 784-7555 FAX (804) 355-5690
MOSELEYARCHITECTS.COM

FLOOR PLAN

A2.1.1

1 INTERIOR FINISH PLAN
A4.1.1 A3.0.1 1/8" = 1'-0"

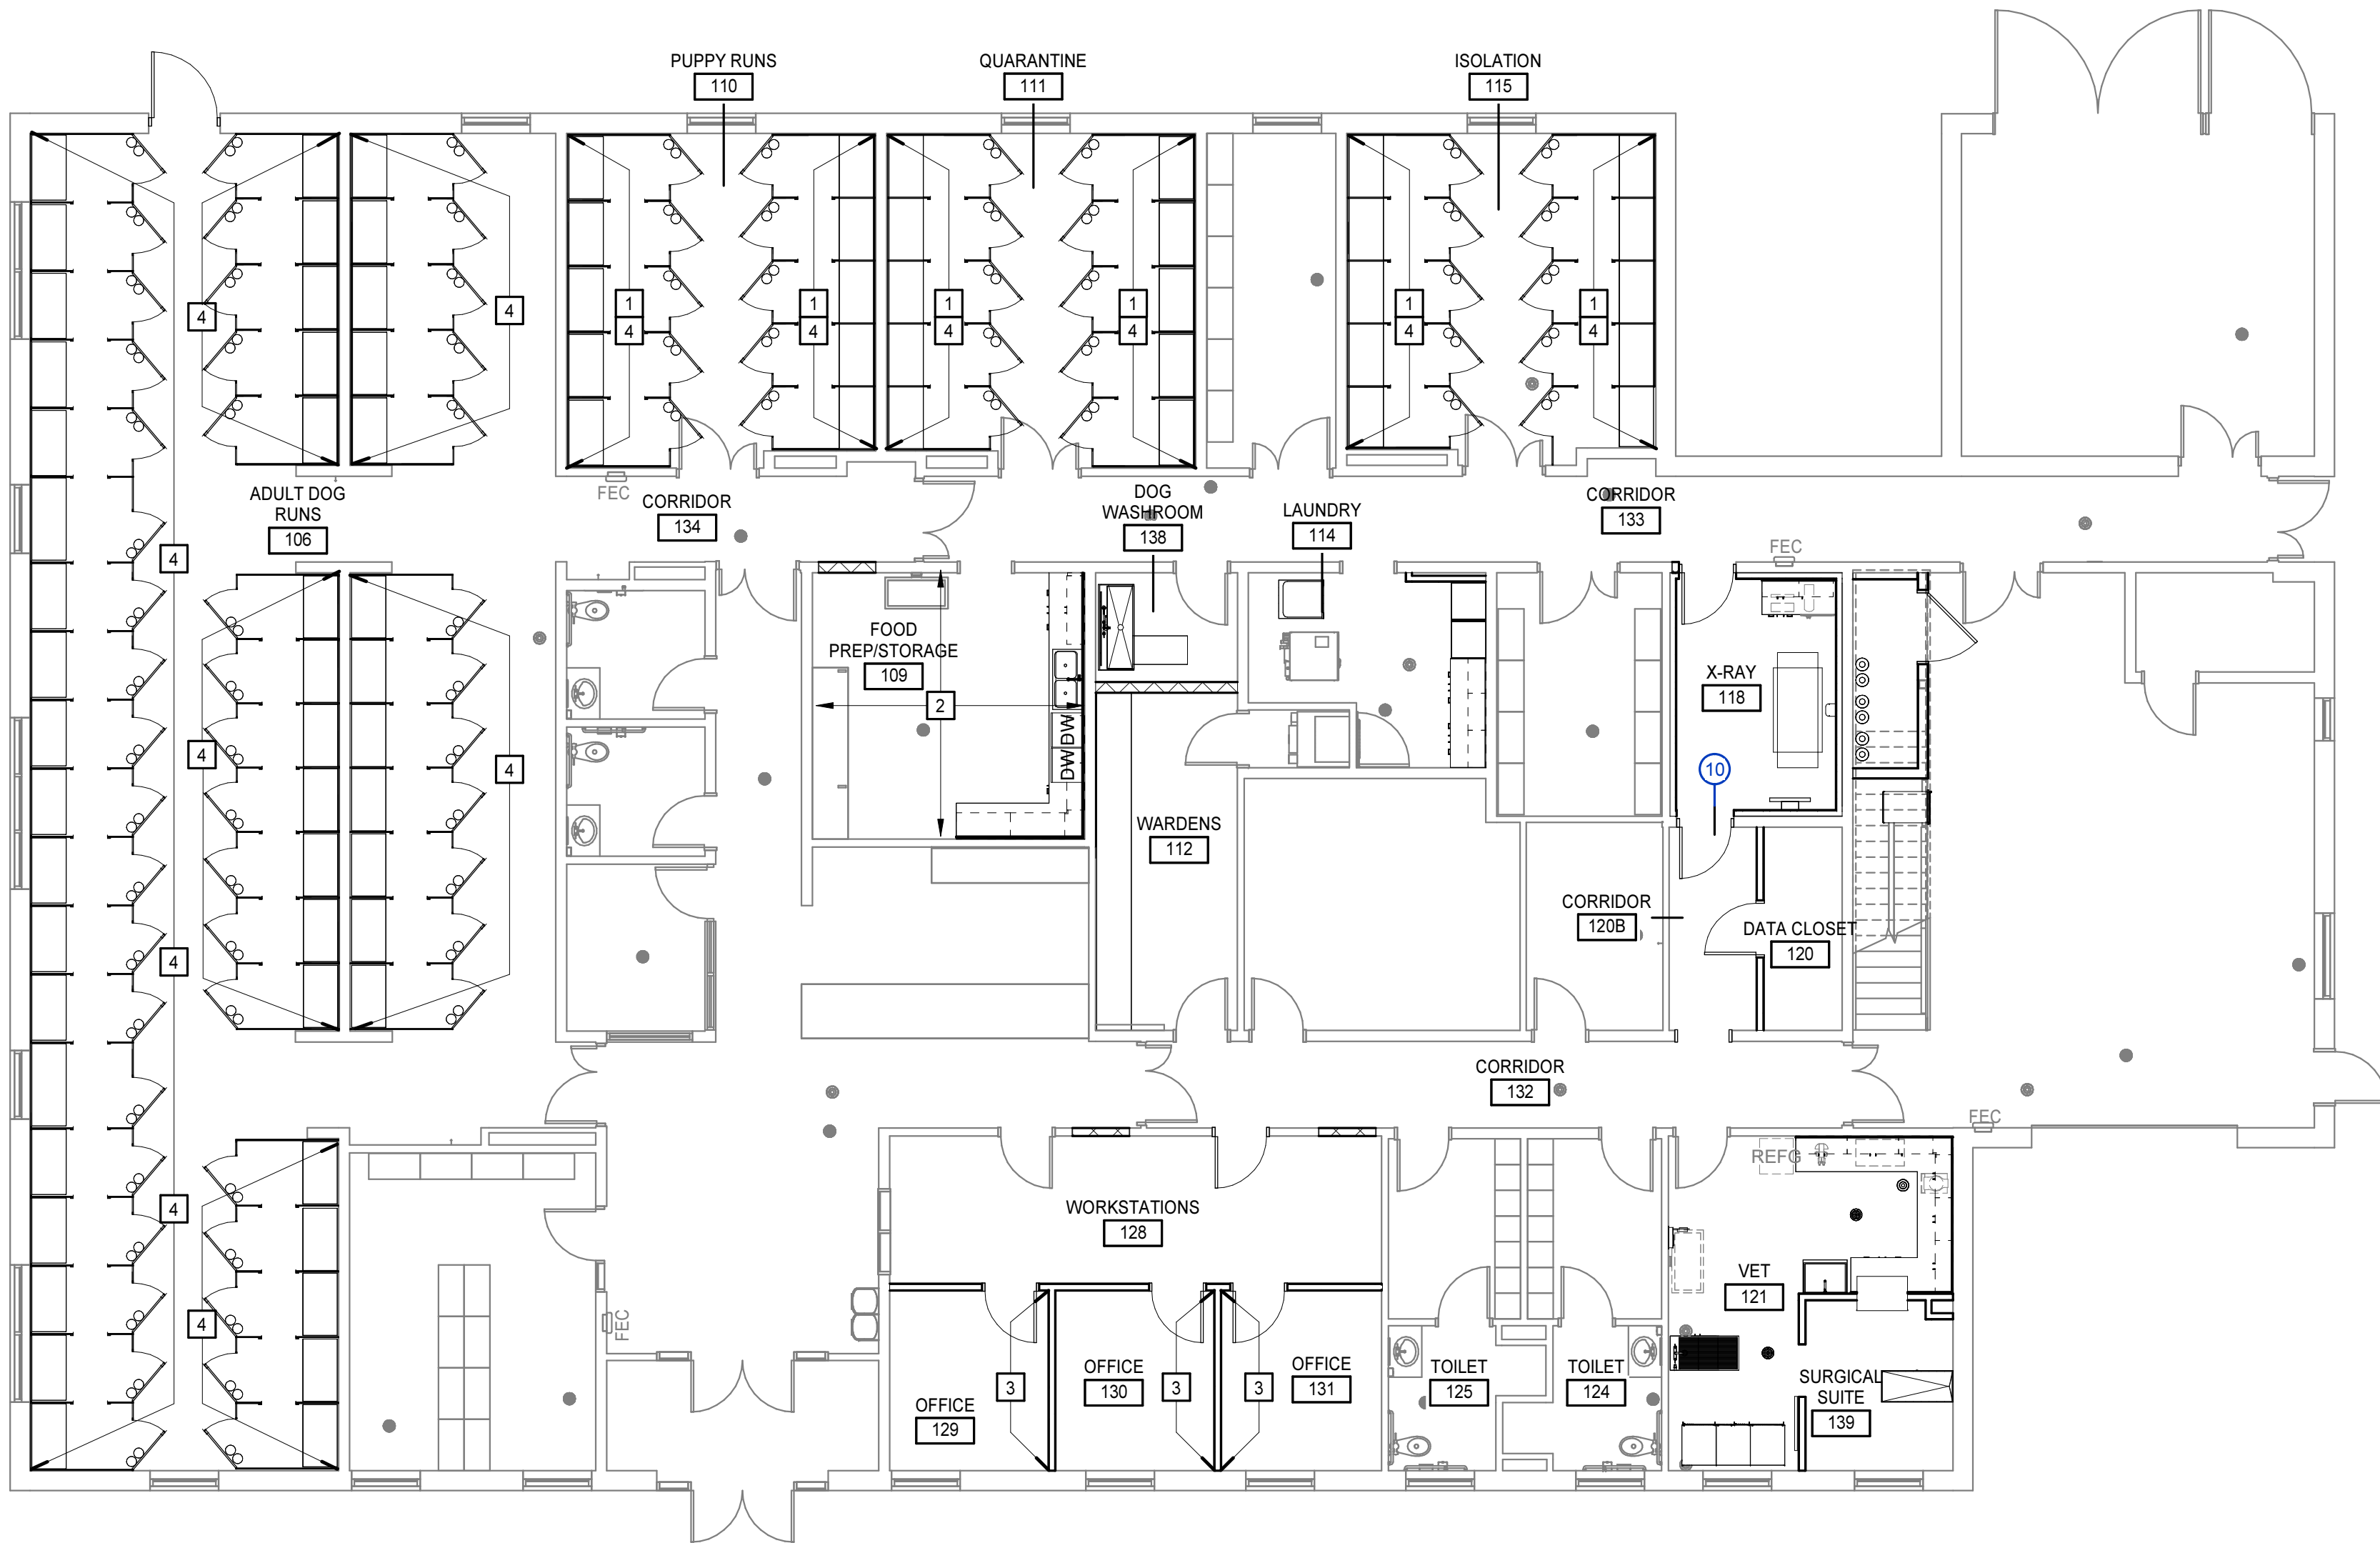

FINISH SCHEDULE

NUMBER	NAME	FLOOR	BASE	WALLS				WAINSCOT	CEILING	NOTES
				NORTH	EAST	SOUTH	WEST			
109	ADULT DOG RUNS	EX/ RES	RES	EPX PT	EPX PT	EPX PT	EPX PT		EX	2
107	TOILET	EX	EX	EX	EX	EX	EX		GB PT	
108	TOILET	EX	EX	EX	EX	EX	EX		GB PT	
109	FOOD PREP/STORAGE	EX/ RES	RES	EPX PT	EPX PT	EPX PT	EPX PT		EX	2
110	PUPPY RUNS	EX/ RES	RES	EPX PT	EPX PT	EPX PT	EPX PT		EX	2
111	QUARANTINE	EX/ RES	RES	EPX PT	EPX PT	EPX PT	EPX PT		EX	2
112	WARDENS	EX/ RES	RES	PT	PT	PT	PT		ACP-A	2
114	LAUNDRY	EX/ RES	RES	EPX PT	EPX PT	EPX PT	EPX PT		EX	2
115	ISOLATION	EX/ RES	RES	EPX PT	EPX PT	EPX PT	EPX PT		EX	2
118	X-RAY	EX	EX	EPX PT	EPX PT	EPX PT	EPX PT		ACP-A	
120	DATA CLOSET	SUT	RB	PT	PT	PT	PT		EXPG PT	
120B	CORRIDOR	EX/ RES	RES	PT	PT	PT	PT		ACP-A	2
121	VET	RES	RES	EPX PT	EPX PT	EPX PT	EPX PT		ACP-B	1
122	JANITOR CLOSET	EX	EX	EX	EX	EX	EX		GB PT	1
124	TOILET	EX	EX	EX	EX	EX	EX		GB PT	
125	TOILET	EX	EX	EX	EX	EX	EX		GB PT	
128	WORKSTATIONS	VT	RB	PT	PT	PT	PT		ACP-A	
129	OFFICE	VT	RB	PT	PT	PT	PT		ACP-A	
130	OFFICE	VT	RB	PT	PT	PT	PT		ACP-A	
131	OFFICE	VT	RB	PT	PT	PT	PT		ACP-A	
132	CORRIDOR	EX/ RES	RES	PT	PT	PT	PT		EX	2
133	CORRIDOR	EX	EX	EPX PT	EPX PT	EPX PT	EPX PT		EX	
134	CORRIDOR	EX	EX	EPX PT	EPX PT	EPX PT	EPX PT		EX	
138	DOG WASHROOM	EX/ RES	RES	EPX PT	EPX PT	EPX PT	EPX PT		EX	2
139	SURGICAL SUITE	RES	RES	EPX PT	EPX PT	EPX PT	EPX PT		ACP-B	1

NOTE:

1. PROVIDE INTEGRAL EPOXY RESINOUS COVE WALL BASE 8"H, REFER DETAIL BELOW.
2. PATCH EXISTING FLOORING WITH NEW RESINOUS MATERIAL TO MATCH EXISTING FLUID-APPLIED FLOORING IN COLOR AND COMPOSITION. REMOVE THE EXISTING BASE AND INSTALL NEW RESINOUS COVE BASE, REFER TO DETAIL 2/A3.0.1


FINISH SCHEDULE GENERAL NOTES

- A. FINISH SCHEDULE DESCRIBES ONLY THE BASIC OR PREDOMINANT SURFACE FINISH.
- B. PROVIDE SAME FINISHES AS THE ADJACENT SPACE IN ALCOVES AND CONTINUOUS SPACES WITHOUT DESIGNATED SPACE NUMBERS.
- C. CASEWORK FINISHES ARE NOT NOTED IN THE FINISH SCHEDULE. REFER TO CASEWORK ELEVATIONS AND SPECIFICATIONS FOR MATERIALS AND FINISHES.
- D. DIRECTIONAL WALL FINISH INDICATORS (NORTH, EAST, SOUTH, WEST) REFER TO THE "PLAN" NORTH ORIENTATION.
- E. BULKHEADS AND SOFFITS MAY NOT BE INDICATED IN FINISH SCHEDULES. REFER TO RCP DETAILS, AND OTHER DOCUMENTS FOR EXTENT.
- F. PROVIDE CONTINUOUS SEALANT BETWEEN INTERIOR SLAB-ON-GRADE AND VERTICAL ELEMENT WHERE JOINT IS NOT CONCEALED BY FINISH BASE OR OTHER CONSTRUCTION.
- G. REFER TO SPECIFICATIONS FOR INFORMATION ON FINISH FIRE CLASSIFICATION RATING.
- H. PAINT ALL EXPOSED ELEMENTS (SUCH AS PIPING AND CONDUITS) TO MATCH ADJACENT COLOR (HIDE & BLEND).
- I. WHERE NEW RESINOUS FLOORING IS SPECIFIED, PROVIDE INTEGRAL EPOXY RESINOUS COVE WALL BASE 8"H.

FINISH PLAN KEYNOTES

REPRESENTED BY **11**
APPLIES TO DRAWINGS A3.0.1

- 1 ACCENT WALL PAINT ABOVE KENNELS
- 2 ACCENT WALL PAINT AT ALL WALLS ABOVE 7'-4" HIGH
- 3 ACCENT WALL PAINT THIS WALL, FULL HEIGHT
- 4 ACOUSTIC WALL PANELS, REFER TO A8.1 FOR TYPICAL LAYOUT AND PANEL SIZE

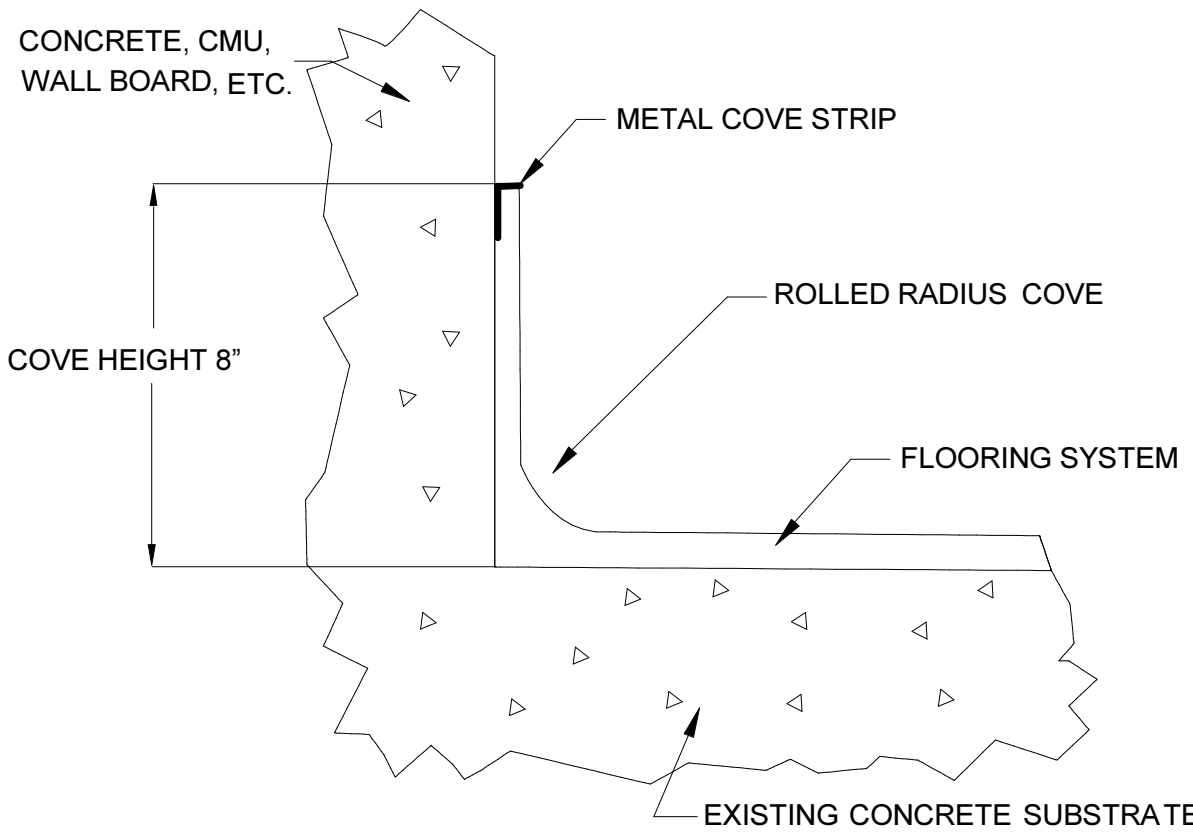


3 RES COVE BASE DETAIL
TYP A3.0.1 3" = 1'-0"

NOTE: USE DRY MIXED TROWELABLE MORTAR VERSION OF FLOORING MATERIAL TO BUILD COVE.

DOOR SCHEDULE																
DOOR			DOOR					FRAME								
NUMBER	TYPE	SIZE (NOMINAL)	MATL	LOUVER	UC	GLAZING TYPE	TYPE	NUMBER	SECTIONS	HEAD DETAIL	JAMB DETAIL	JAMB DETAIL	SILL DETAIL	FIRE RATING	LEAD LINED	NOTES
118B	F	3'-0" x 7'-0" x 1 3/4"	STL	--	--	--	STL	2	A	9	8	8				LEAD LINED
119	F	4'-0" x 7'-0" x 1 3/4"	STL	--	--	--	STL	1	A	1	1	1				
120B	F	3'-0" x 7'-0" x 1 3/4"	WD	--	--	--	STL	2	A	1	1	1		60 MIN		
128	N2	3'-0" x 7'-0" x 1 3/4"	STL	--	--	1	STL	2	A	1	1	1				
129	N2	3'-0" x 7'-0" x 1 3/4"	STL	--	--	1	STL	1	A	1	1	1				
130	N2	3'-0" x 7'-0" x 1 3/4"	STL	--	--	1	STL	1	A	1	1	1				
131	N2	3'-0" x 7'-0" x 1 3/4"	STL	--	--	1	STL	1	A	1	1	1				
139	FG	3'-0" x 7'-0" x 2"	ALUM	--	--	2	SLIDE	1	--	7	6	6				PUSH BUTTON OPERATOR
160	G	3'-10" x 7'-0" x 1 3/4"	STL	--	--	2	STL	3	A	5	4	4				

GENERAL NOTES

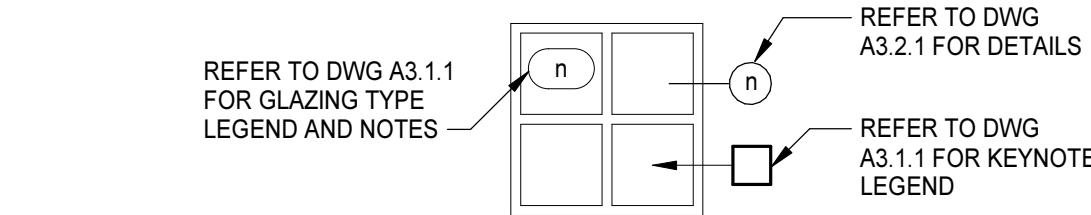

- A. UNLESS INDICATED OTHERWISE, ALL DETAIL NUMBERS IN THE DOOR AND FRAME SCHEDULE FOR HEAD, JAMB, AND SILL CONDITIONS REFER TO DRAWING A3.2.1.
- B. DOOR AND FRAME DETAILS INDICATE GENERAL CHARACTERISTICS OF DOOR AND FRAME SIZES AND COMPONENTS AND MAY NOT INDICATE EXACT FIELD CONDITIONS OR REQUIREMENTS. COORDINATE DETAILS WITH OTHER DRAWINGS AND SPECS TO DETERMINE ALL COMPONENTS (E.G., SEALANTS, ANCHORS, HARDWARE, LINTELS, CLIPS) REQUIRED FOR COMPLETE AND FUNCTIONAL INSTALLATION.
- C. DOOR SWINGS ON FLOOR PLANS TAKE PRECEDENCE OVER SWINGS INDICATED ELSEWHERE (E.G., ELEVATIONS).

GLAZING TYPES

REPRESENTED BY (n)

- 1/4" CLEAR
- 1" TINTED INSULATING

- NOTES:
- ALL GLAZING IN INTERIOR FRAMES SHALL BE TYPE 1, UNO
 - ALL GLAZING IN EXTERIOR FRAMES SHALL BE TYPE 2, UNO
 - GLAZE ALL OPENINGS IN FRAMES UNLESS SPECIFICALLY INDICATED OTHERWISE
 - ALL GLAZING SHALL BE SAFETY GLASS UNLESS INDICATED OTHERWISE

DOOR, FRAME AND GLAZING TYPE KEYNOTES


REPRESENTED BY (n)

APPLIES TO DRAWINGS A3.1.1

- SIZE AS REQUIRED TO ACCOMMODATE DOOR, HARDWARE, AND FRAMING COMPONENTS


SLIDING DOOR TYPE

1/4" = 1'-0"

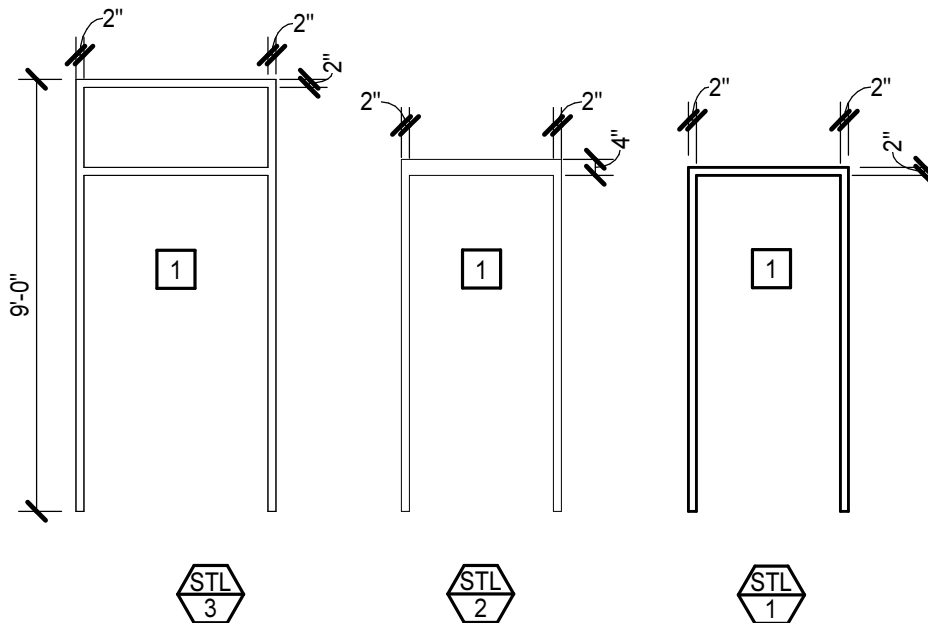

DOOR FRAME TYPES

1/4" = 1'-0"

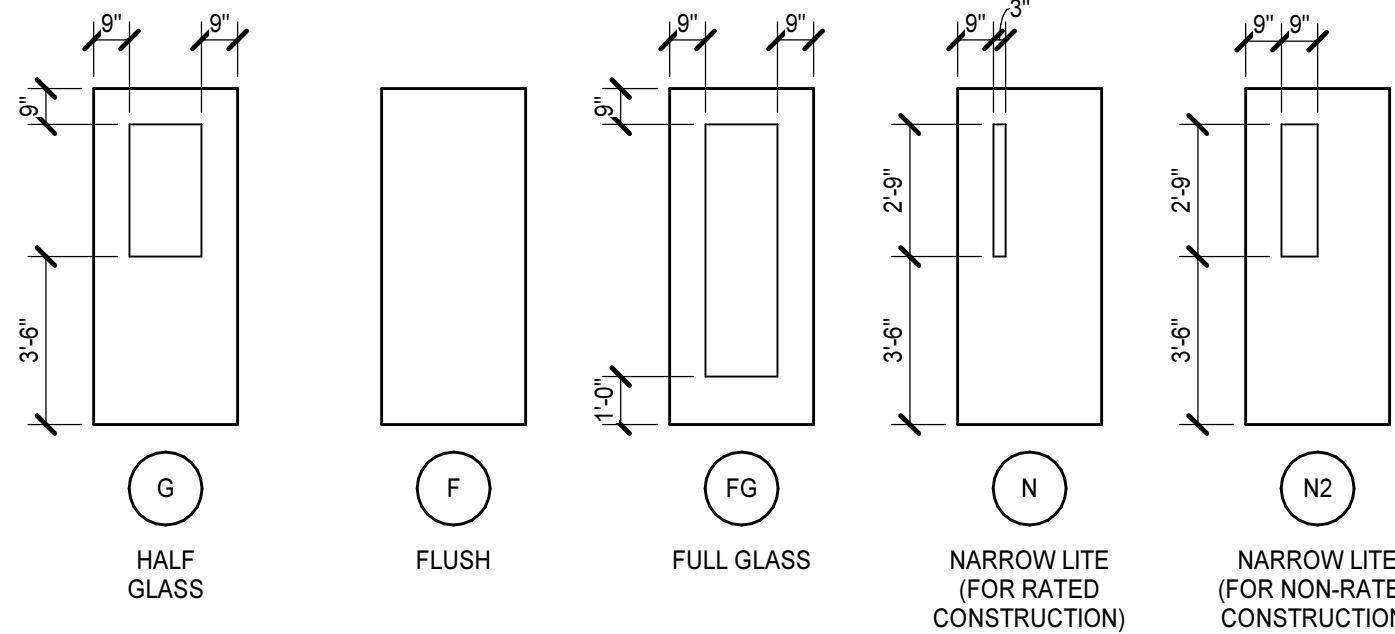


DOOR TYPES


NO SCALE

PROJECT NO:	615225
DATE:	AUGUST 18, 2025
REVISIONS	
DATE	DESCRIPTION




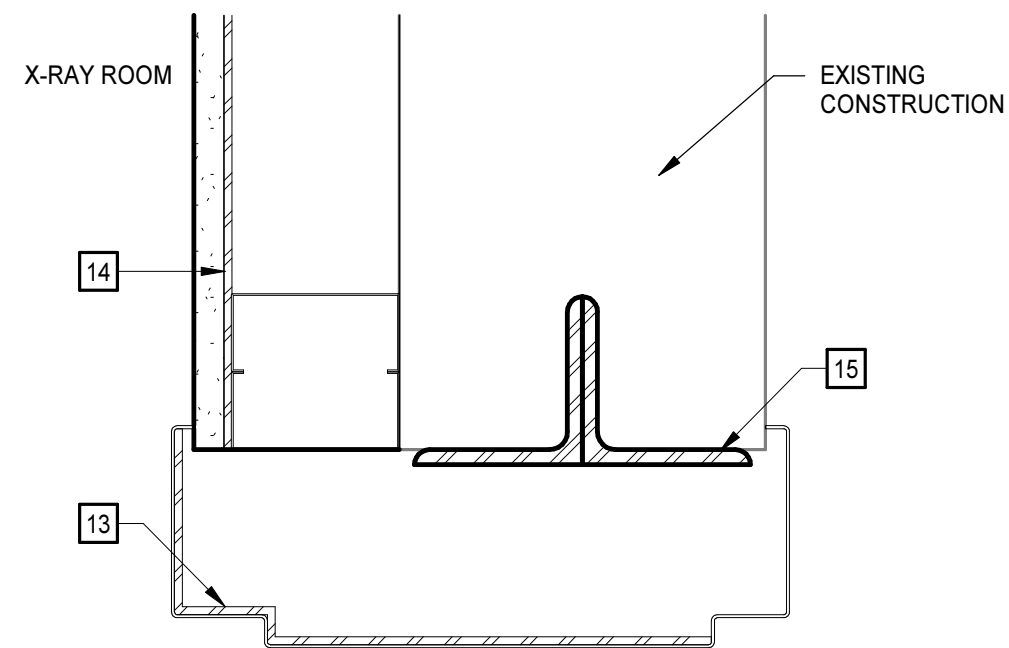


10 HEAD DETAIL
A2.0.x | A3.2.1 3" = 1'-0"

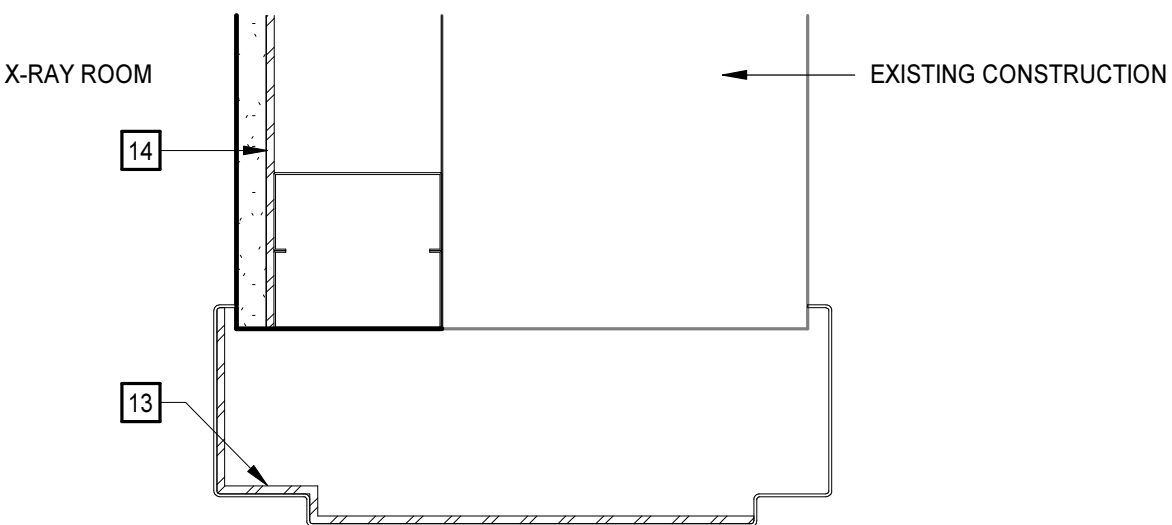


9 HEAD DETAIL
A3.2.1 3" = 1'-0"

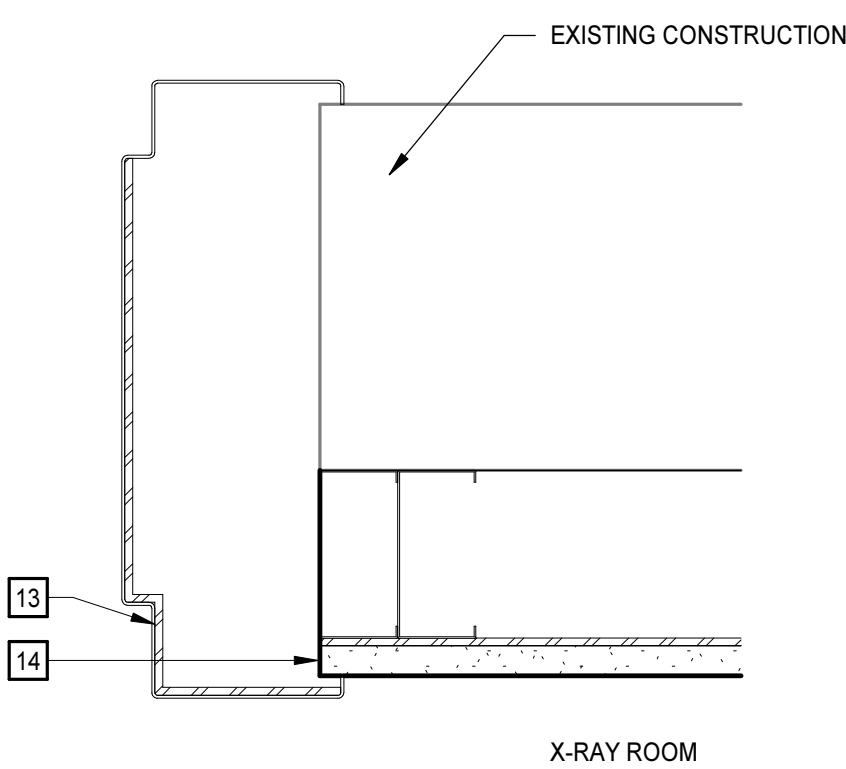


8 JAMB DETAIL
A3.2.1 3" = 1'-0"

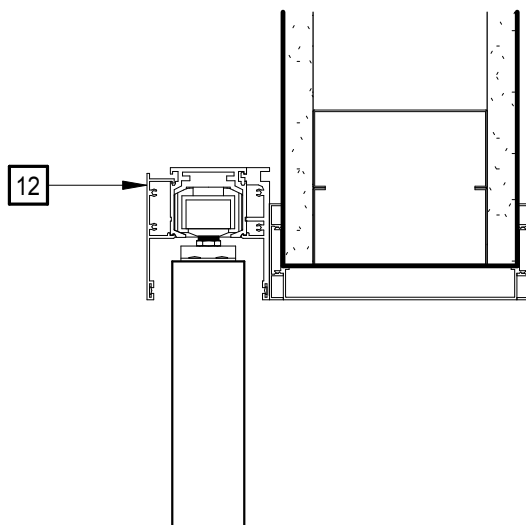


7 HEAD DETAIL
A3.1.1 | A3.2.1 3" = 1'-0"

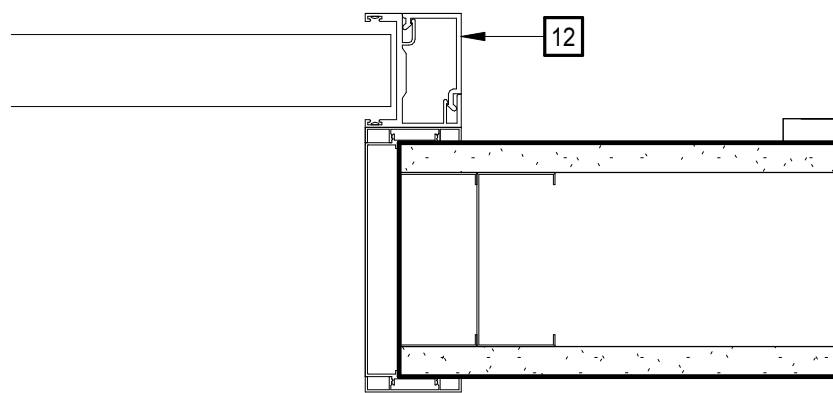


6 JAMB DETAIL
A3.1.1 | A3.2.1 3" = 1'-0"

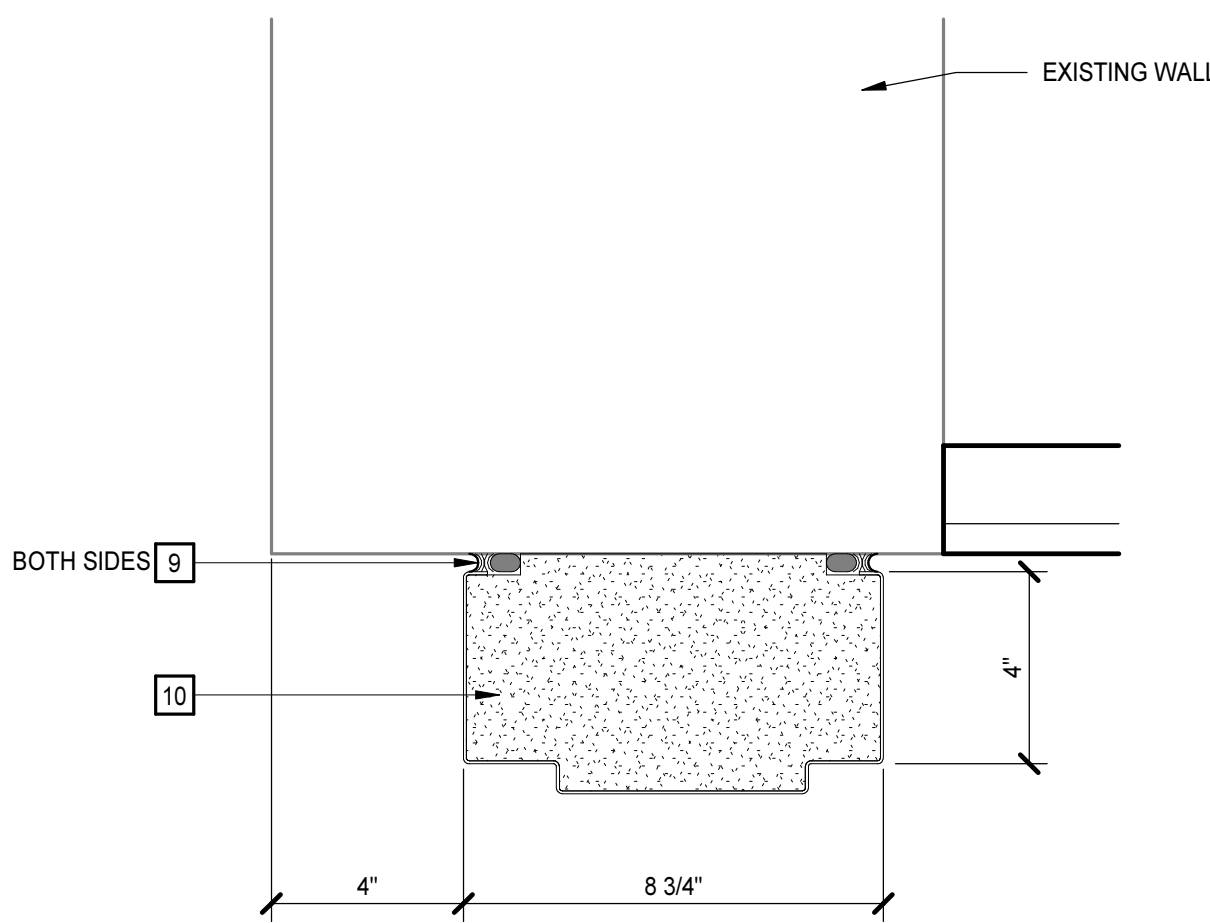


5 HEAD DETAIL
A3.2.1 3" = 1'-0"

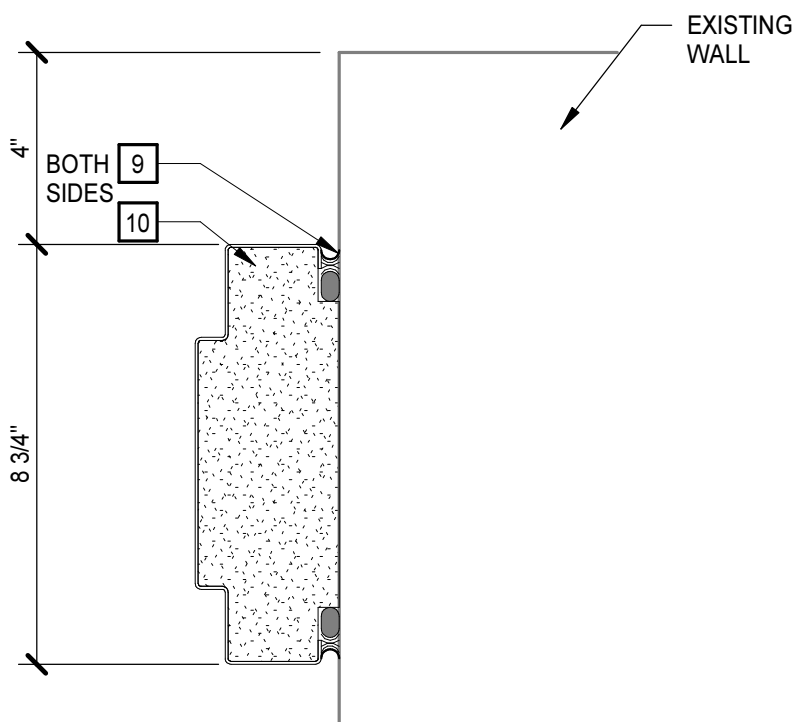


4 JAMB DETAIL
A3.2.1 3" = 1'-0"

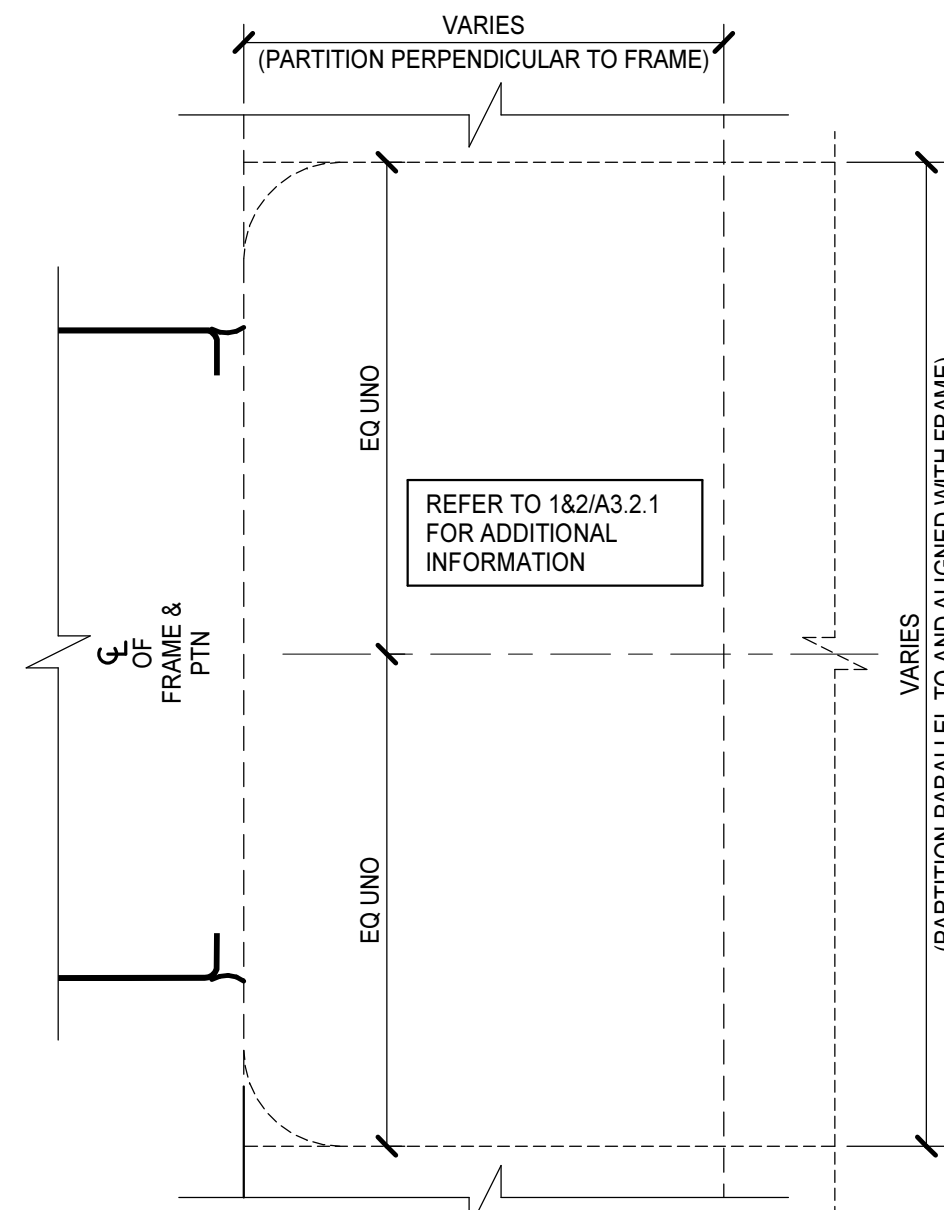


3 INTERIOR BETWEEN THE JAMB - BUTTED HEAD/JAMB/SILL
A3.2.1 6" = 1'-0"

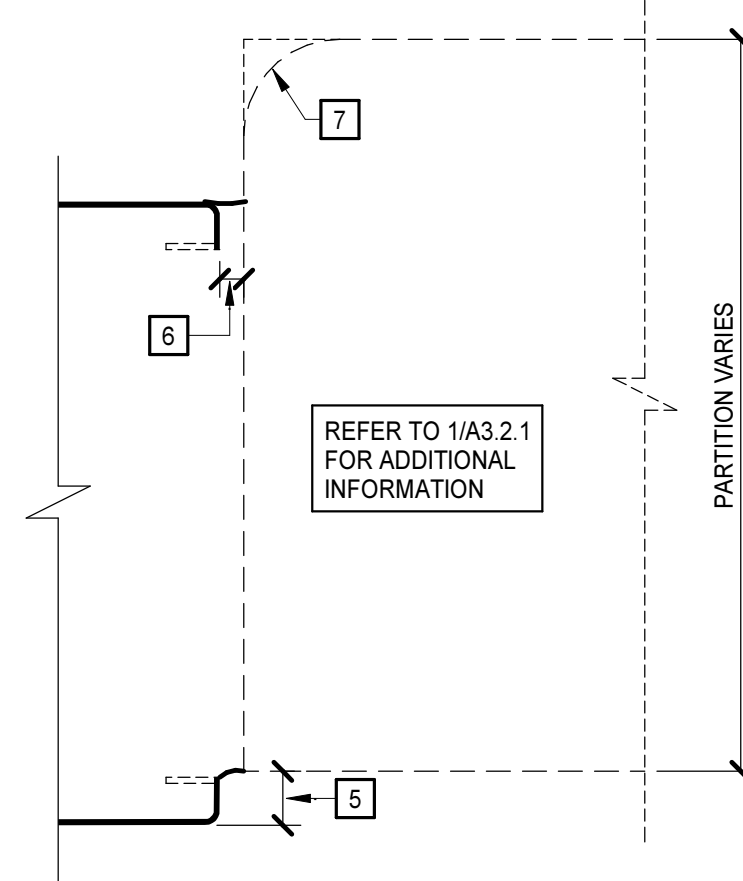

2 INTERIOR BETWEEN THE JAMB - PROJECTED HEAD/JAMB/SILL
A3.2.1 6" = 1'-0"

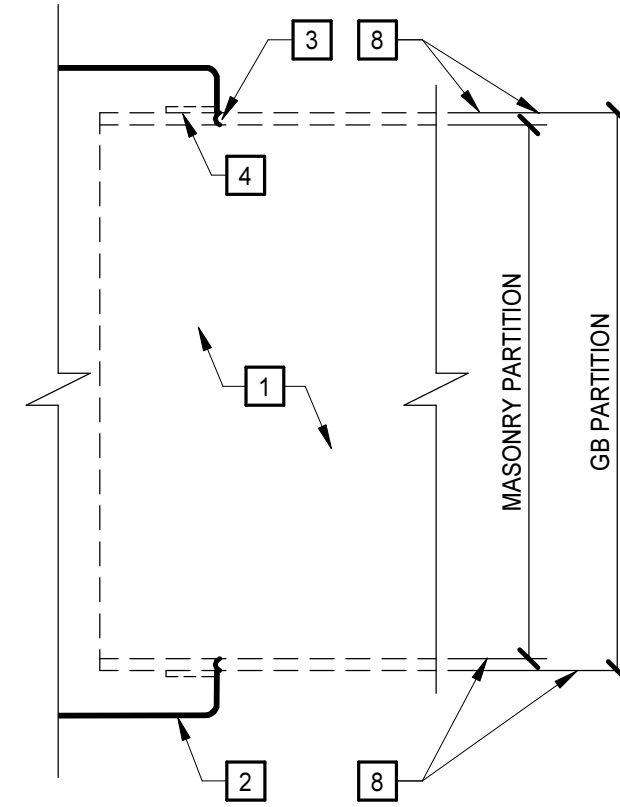


1 INTERIOR WRAP HEAD/JAMB/SILL
A3.2.1 6" = 1'-0"

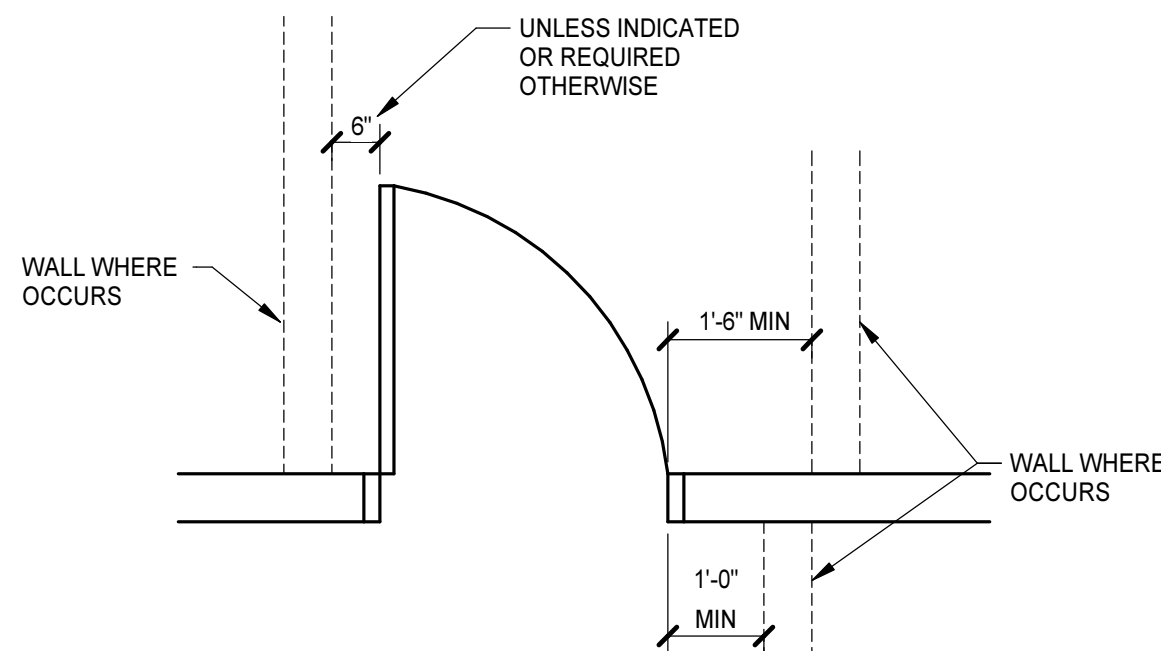


MANEUVERING CLEARANCE AT DOORS
NO SCALE


DOOR AND FRAME DETAIL KEYNOTES	
REPRESENTED BY [n]	
APPLIES TO DRAWINGS A3.2.1 - A3.2.n	
1	ANCHORAGES, REINFORCING, SPECIFIC PARTITION CONSTRUCTION AND/OR LINTELS ARE NOT SHOWN FOR CLARITY.
2	REFER TO FRAME SECTION IN DOOR SCHEDULE FOR TYPE.
3	SEALANT, ALL SIDES - TOOL TO 90°.
4	BACKBEND RETURN @ GB LOCATIONS ONLY.
5	9/16" @ MAS, 1/2" @ GB.
6	1/4" @ JAMBS, UNO, DIMENSION @ HEAD & SILL VARIES.
7	BULLNOSE @ CMU JAMBS & SILLS.
8	0" @ GB LOCATIONS; 1/16" @ MAS LOCATIONS.
9	BACKER ROD AND SEALANT
10	GROUT SOLID
12	SLIDING DOOR ASSEMBLY
13	STEEL FRAME WITH LEAD SHIELDING
14	LEAD LINED GYP BOARD
15	PROVIDE (2)-L3 1/2x3 1/2x5/16 (BACK-TO-BACK) BEAR 4" INTO SOUND AND SOLID CMU

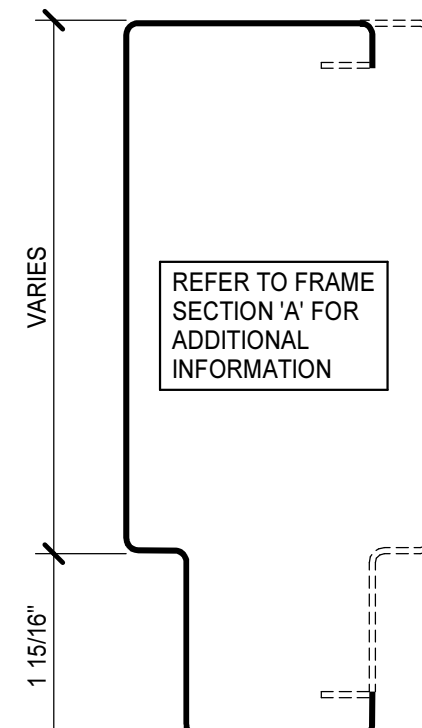


SINGLE RABBET
D

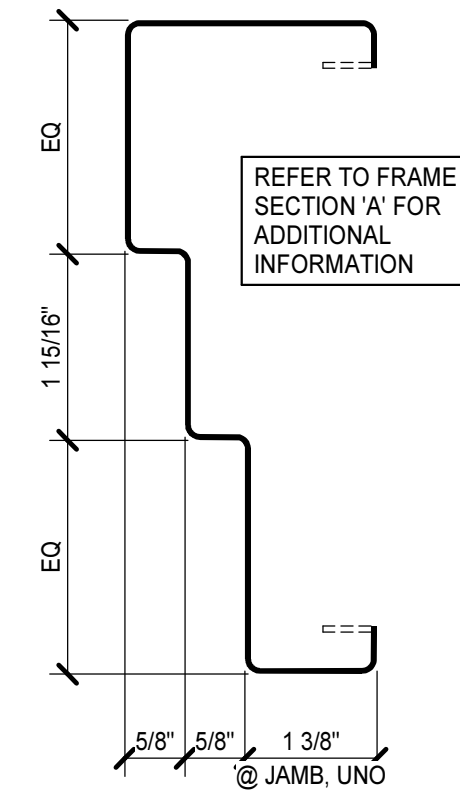

DBL EGRESS @ JAMB, UNO
B
HEAD SECTION SIMILAR

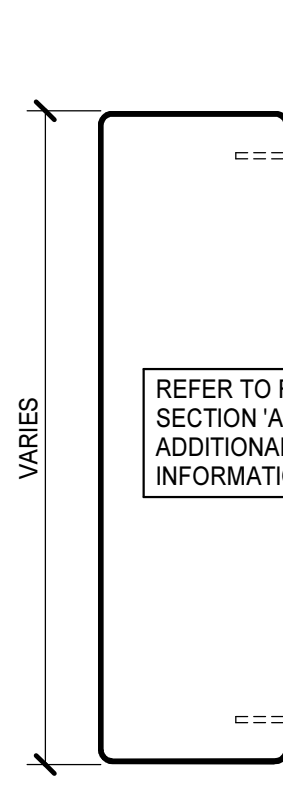





CASED OPENING
C

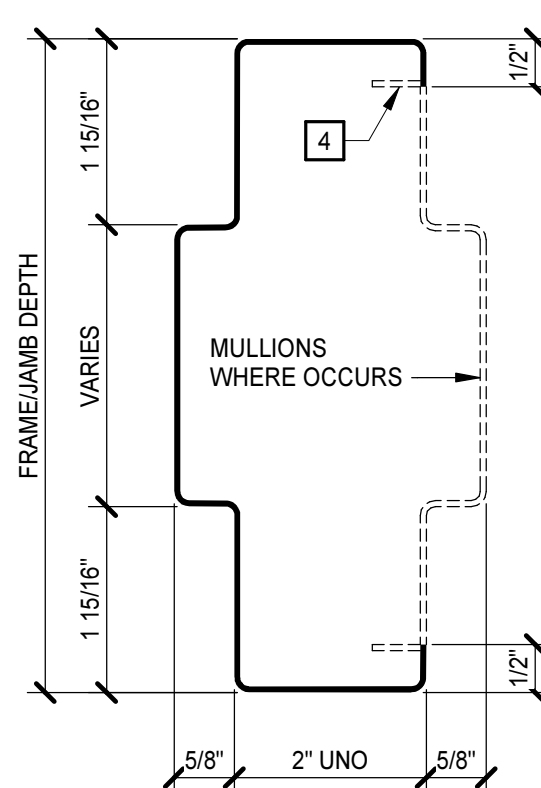


DBL RABBET
A

1. ALL FRAME/JAMB DEPTHS, OTHER THAN WRAP CONDITIONS, SHALL BE 8 3/4" UNO.
2. ALL FRAME/JAMB DEPTHS AT WRAP CONDITIONS SHALL BE SIZED TO SUIT PARTITION.
3. DOORS, PANELS, GLAZING, STOPS, AND OTHER FRAME INFILLS ARE NOT SHOWN IN FRAME SECTIONS AS THEY VARY - PROVIDE SAME WHERE INDICATED.


STEEL FRAME SECTIONS
NO SCALE

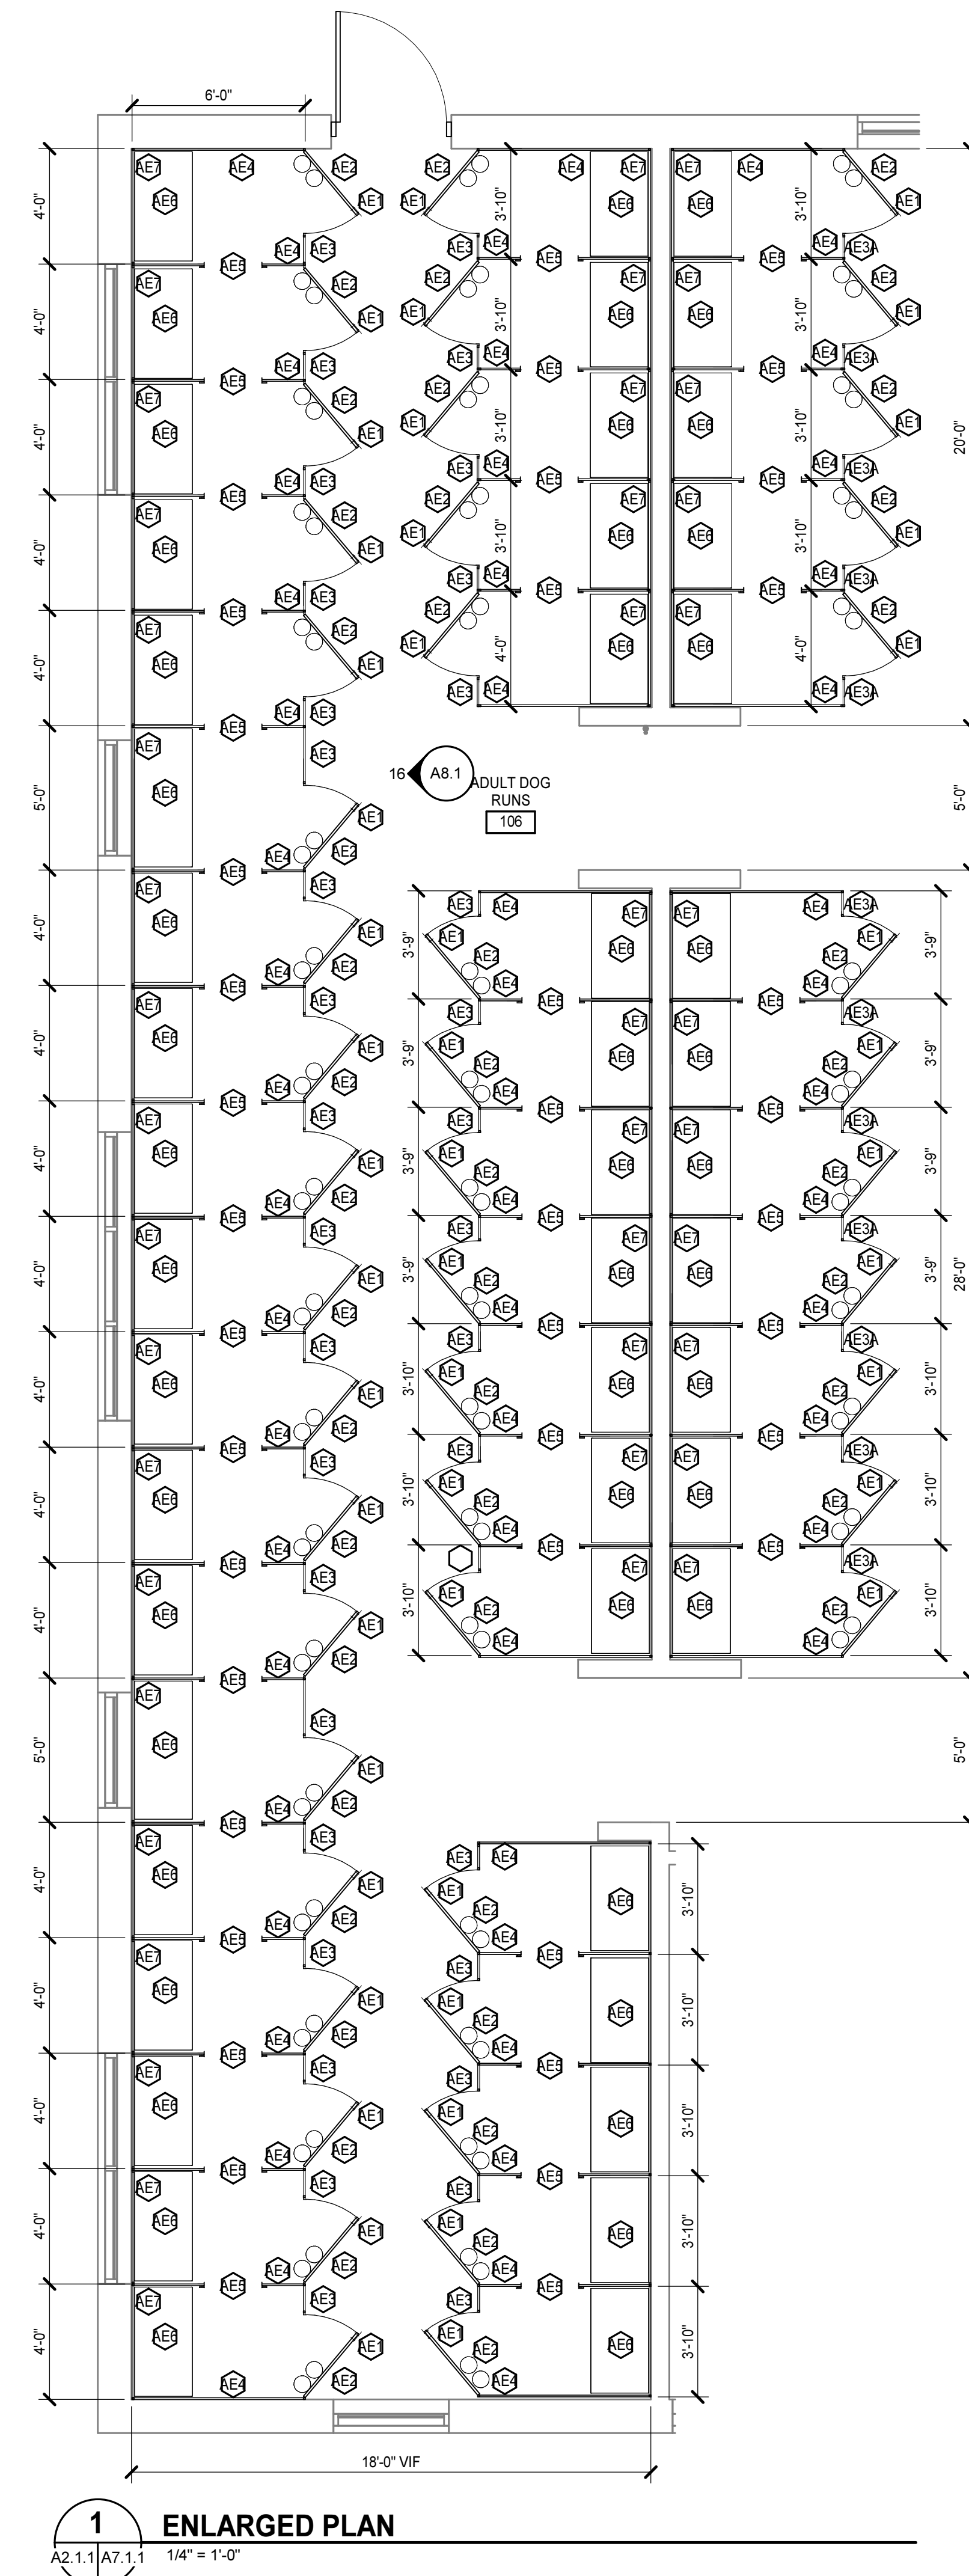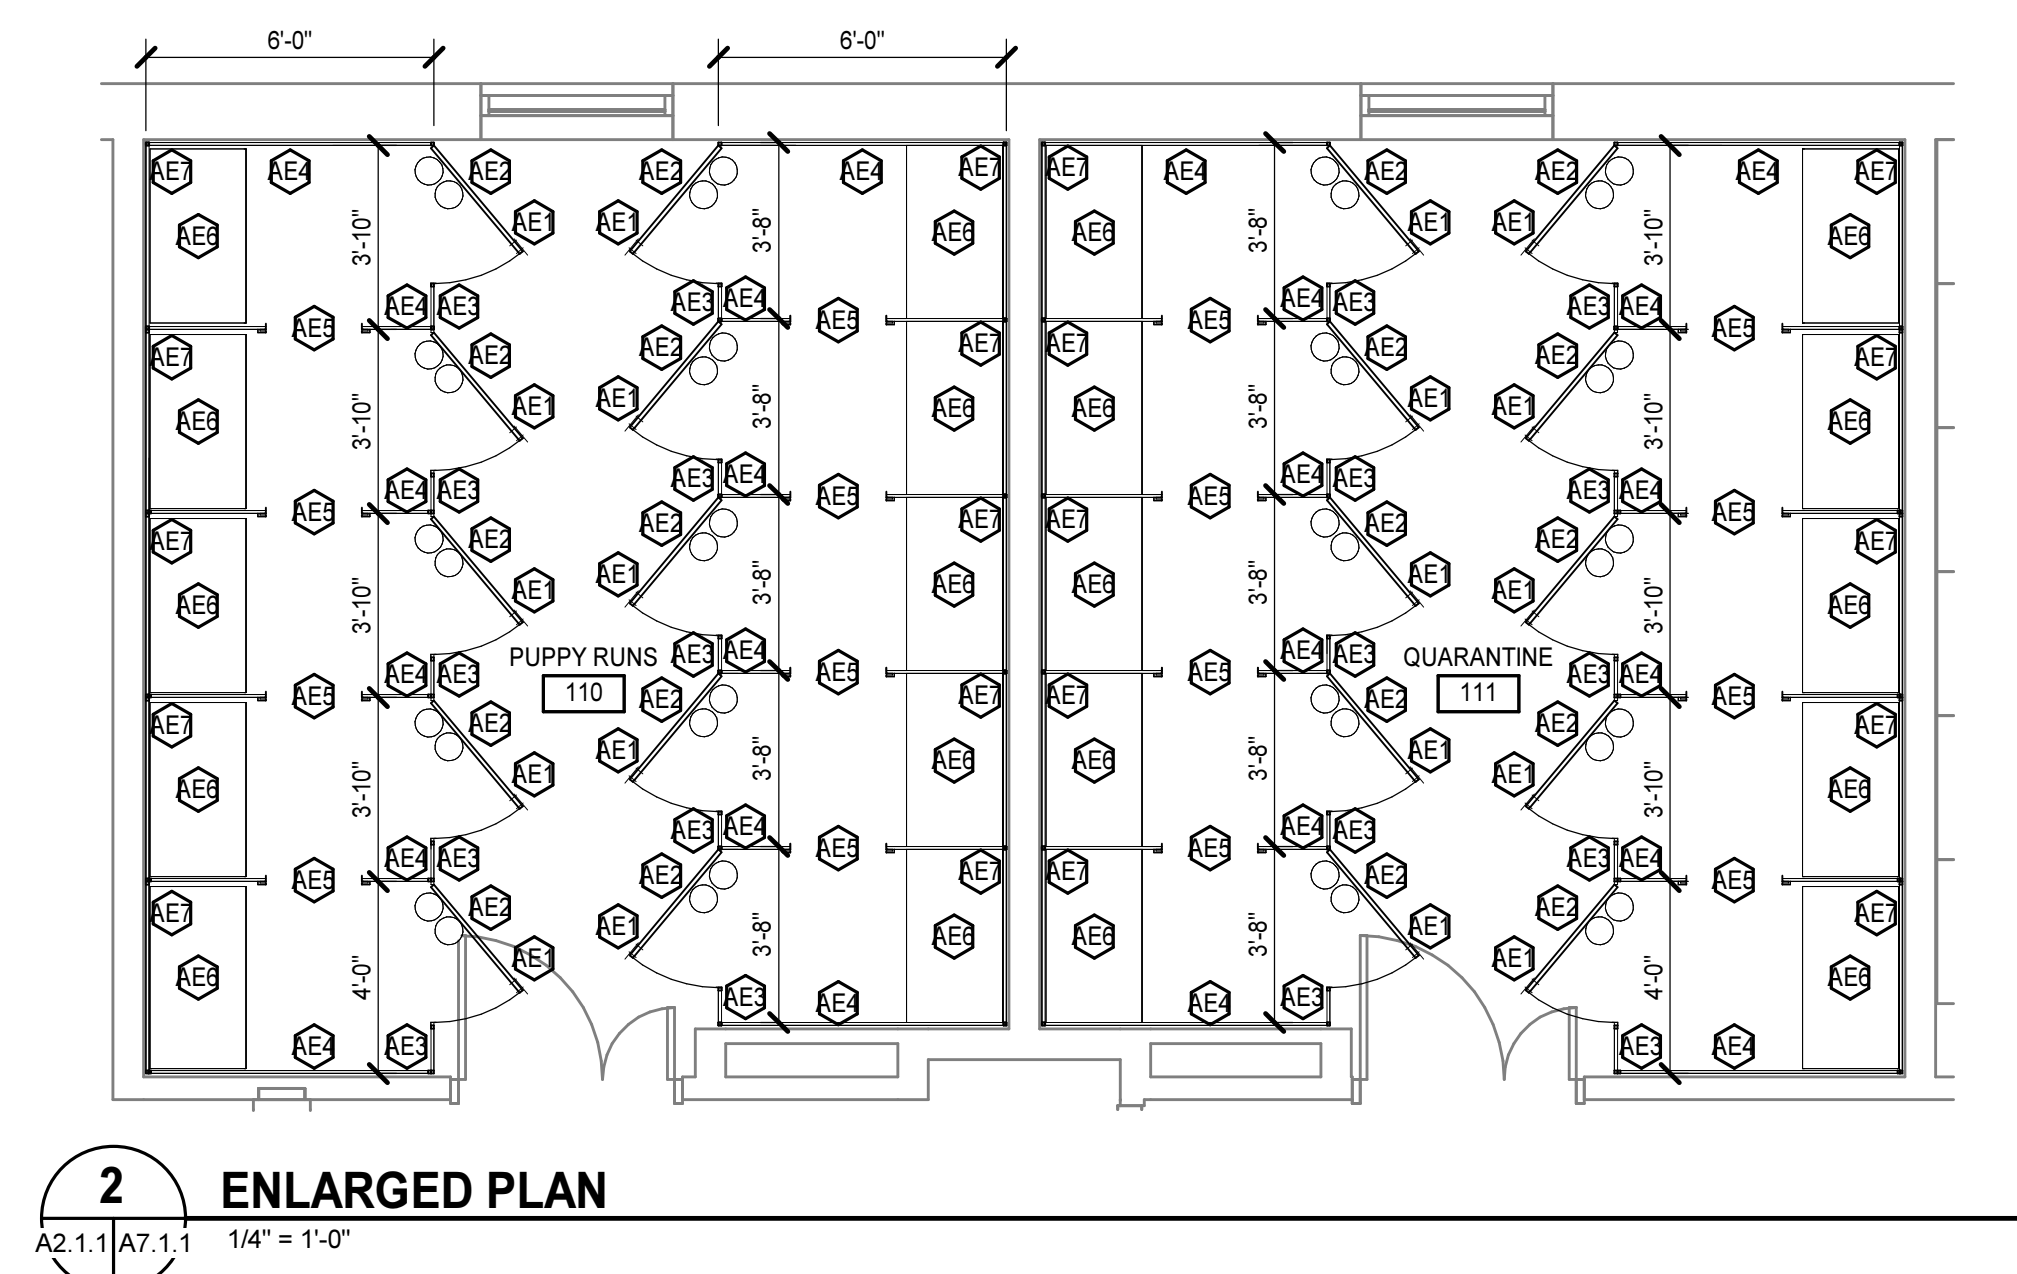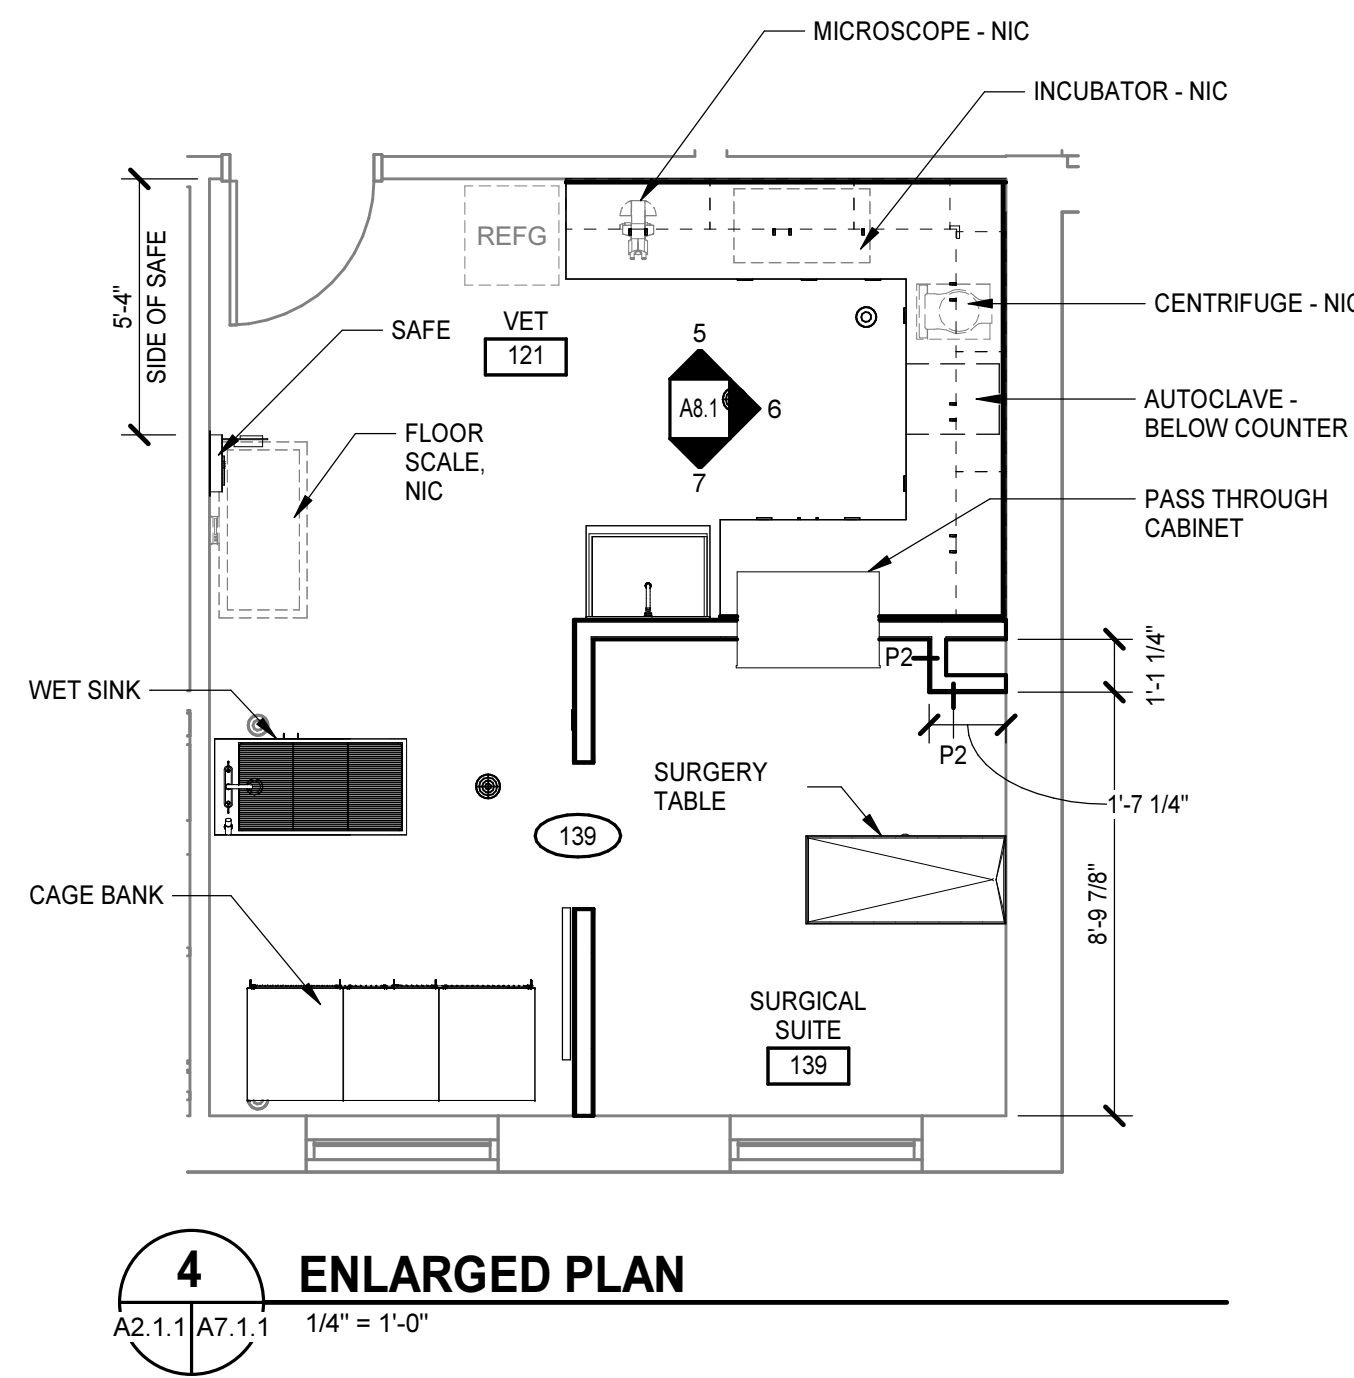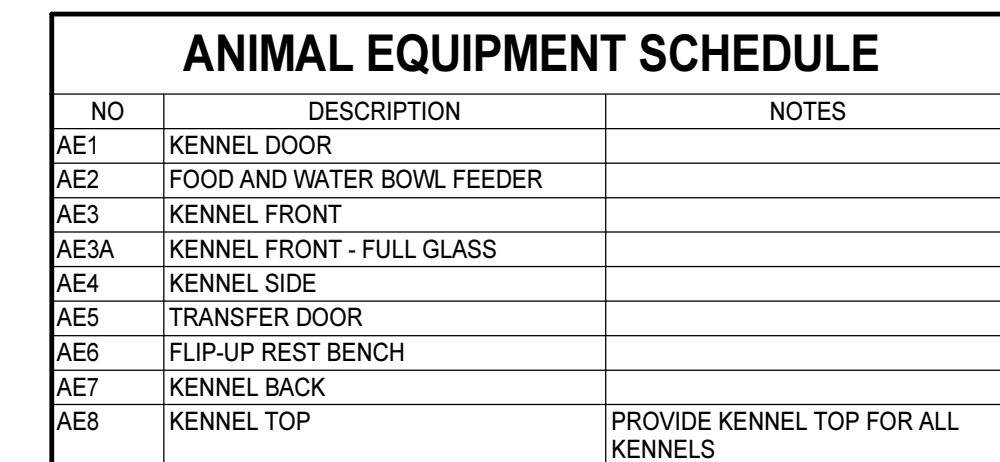


7 121 VET - SOUTH
1/4" = 1'-0"

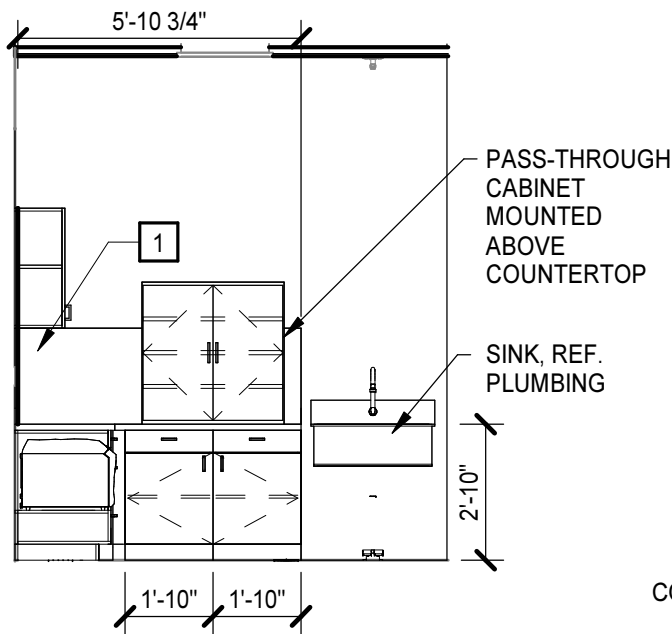


6 121 VET - EAST
1/4" = 1'-0"

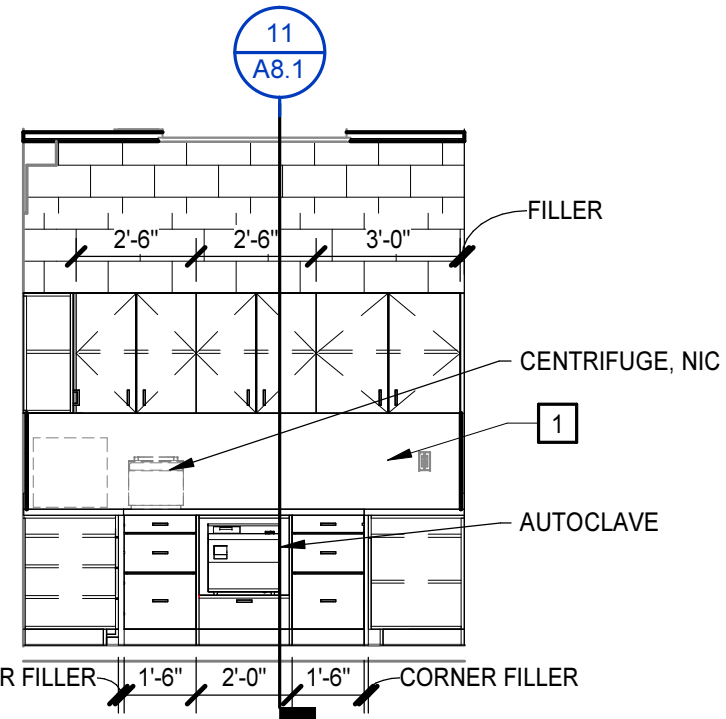


5 121 VET - NORTH
1/4" = 1'-0"

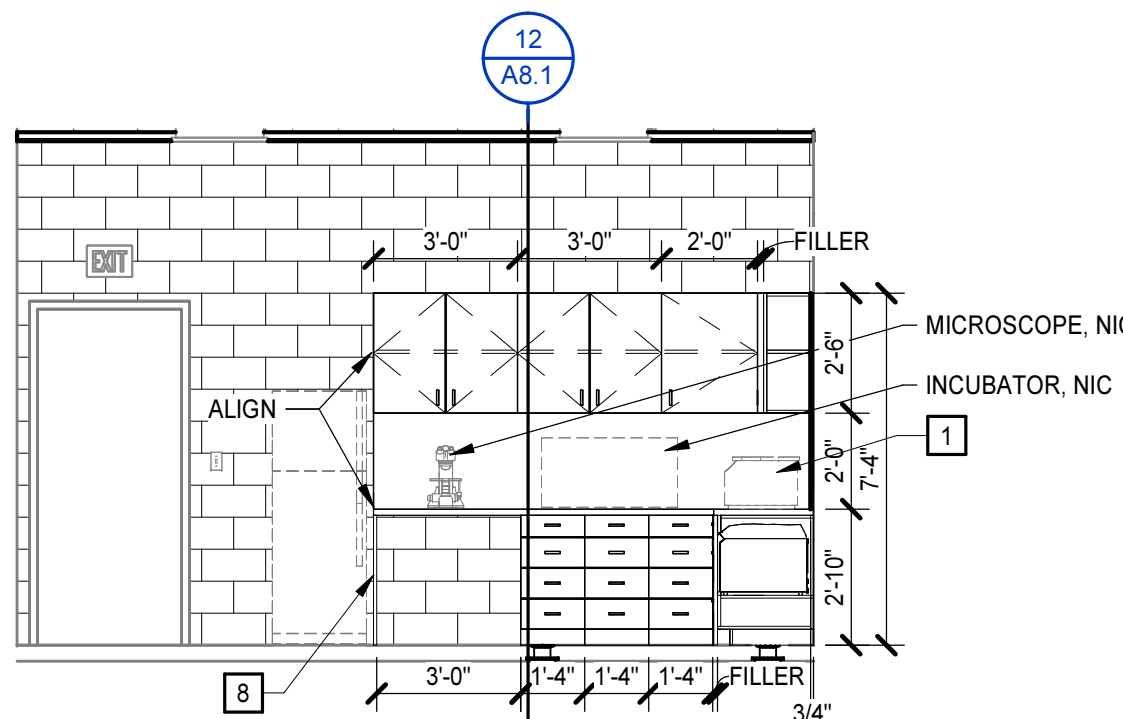


4 118 X-RAY
1/4" = 1'-0"

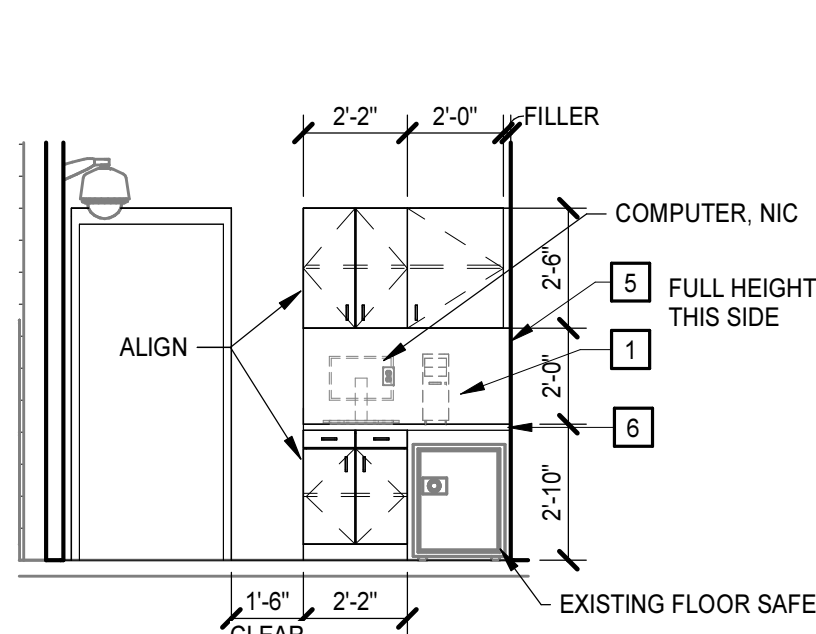


3 114 LAUNDRY
1/4" = 1'-0"

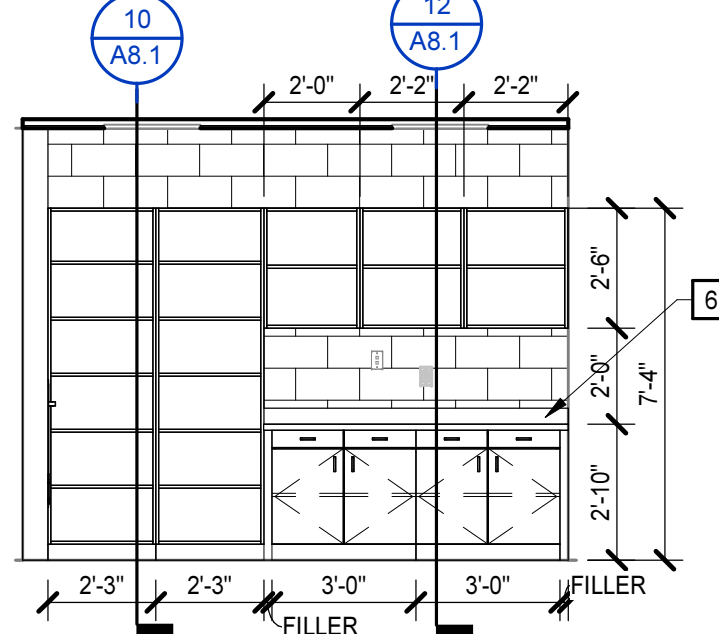


2 109 FOOD PREP/STORAGE (SOUTH)
1/4" = 1'-0"

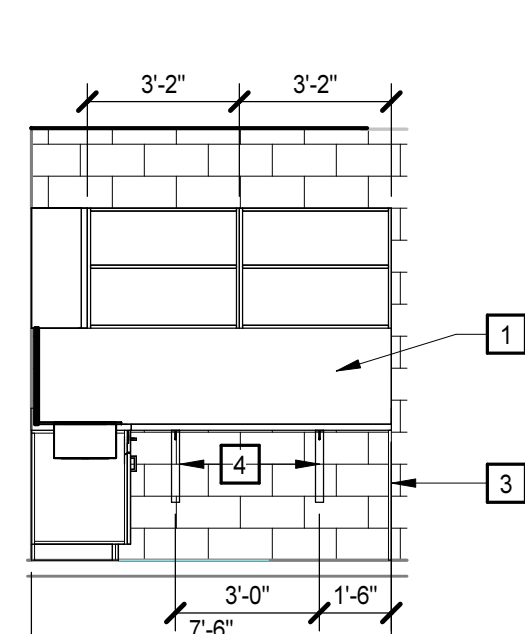


1 109 FOOD PREP/STORAGE (EAST)
1/4" = 1'-0"

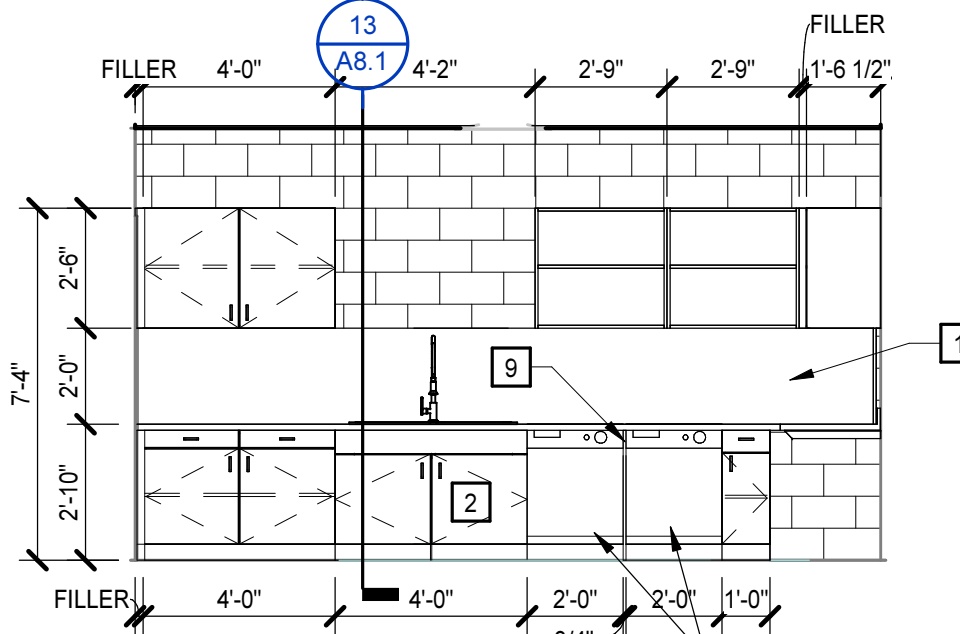


13 TYPICAL ADA CABINET SECTION
3/4" = 1'-0"

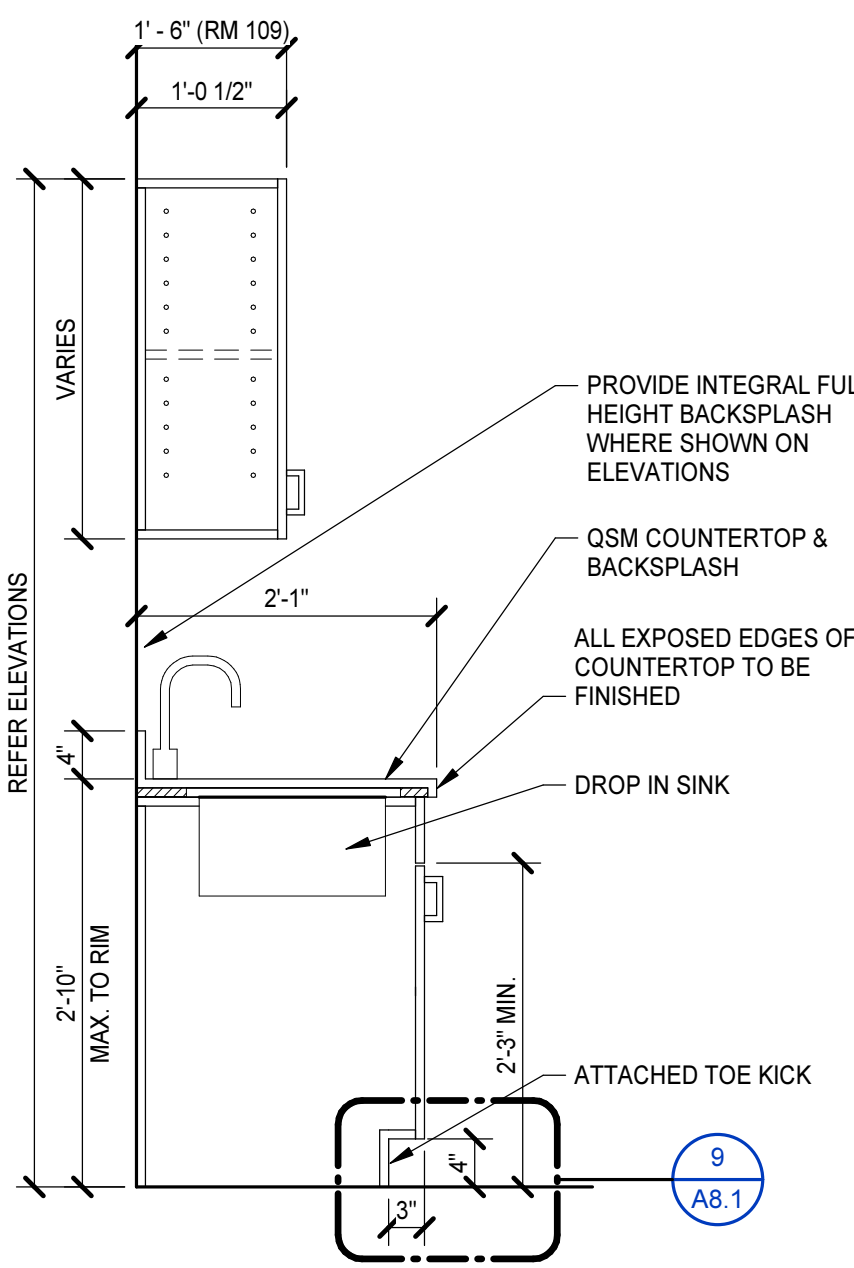


12 TYPICAL CABINET SECTION
3/4" = 1'-0"

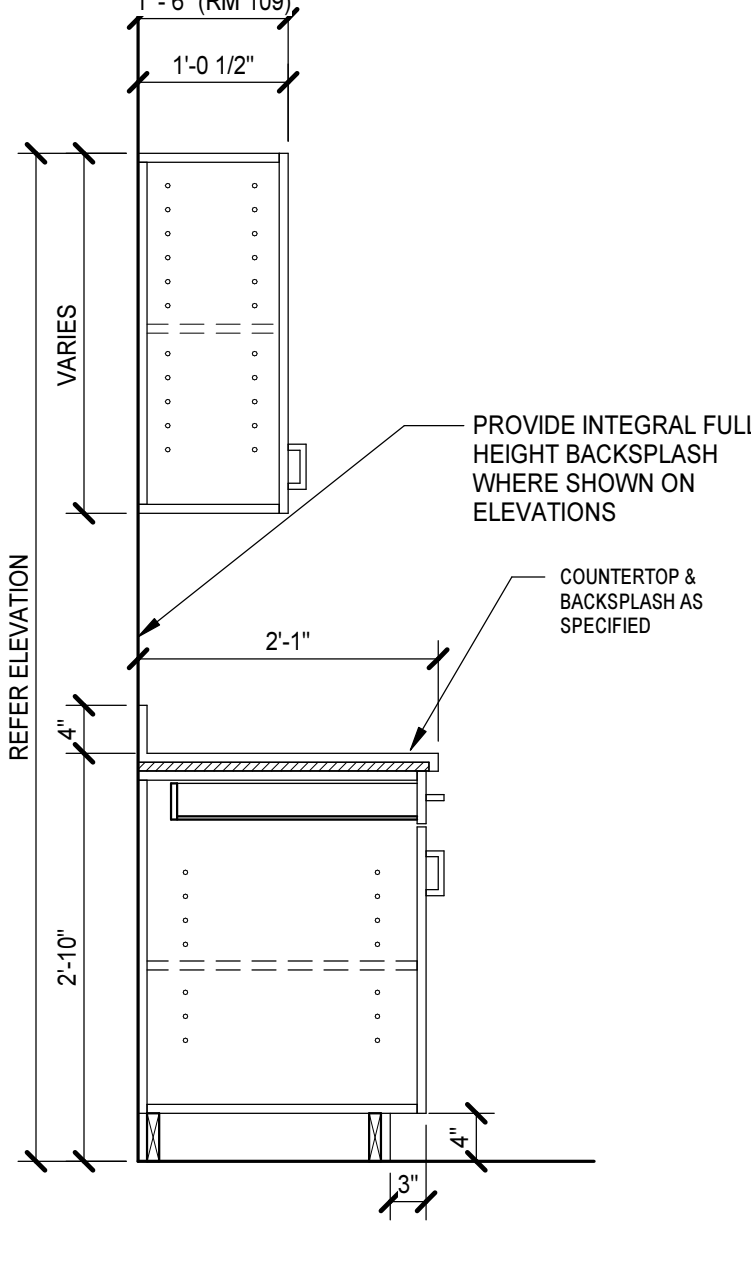


11 CABINET SECTION
3/4" = 1'-0"

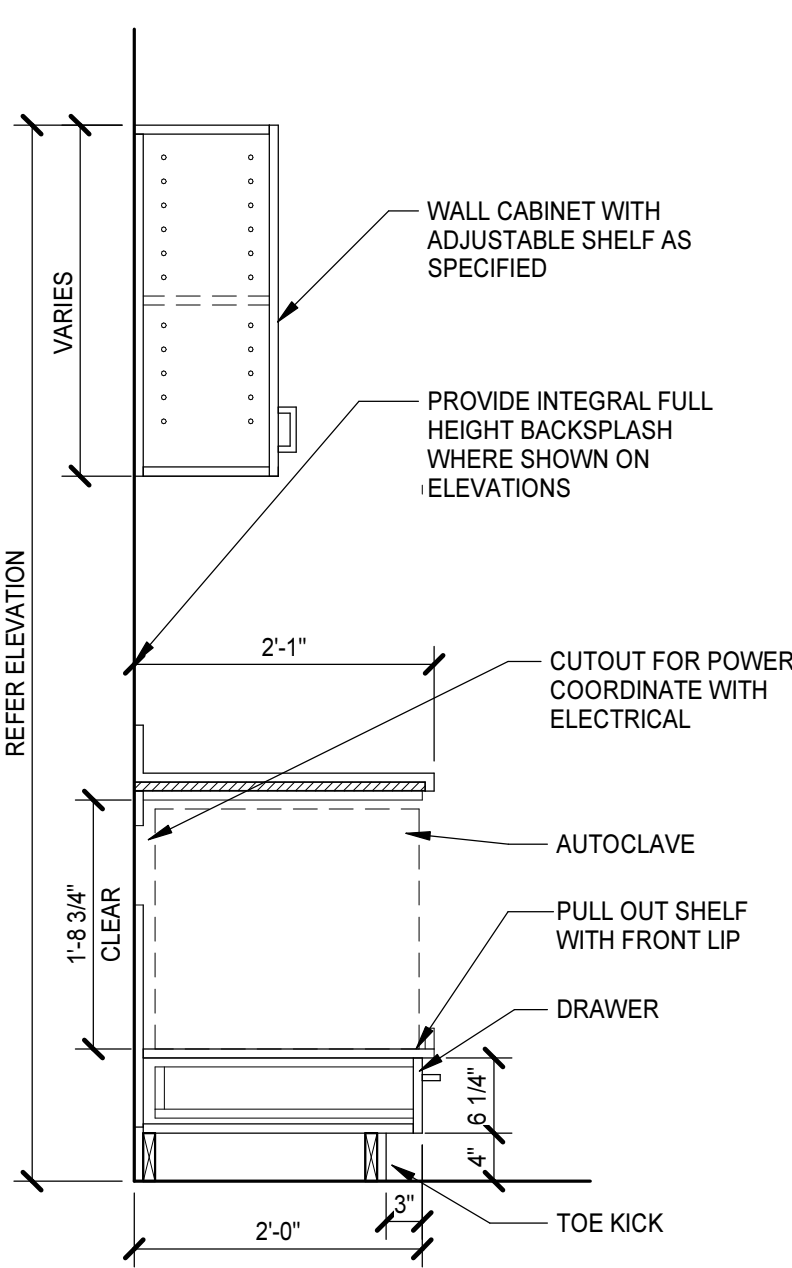


10 TYPICAL TALL CABINET SECTION
3/4" = 1'-0"

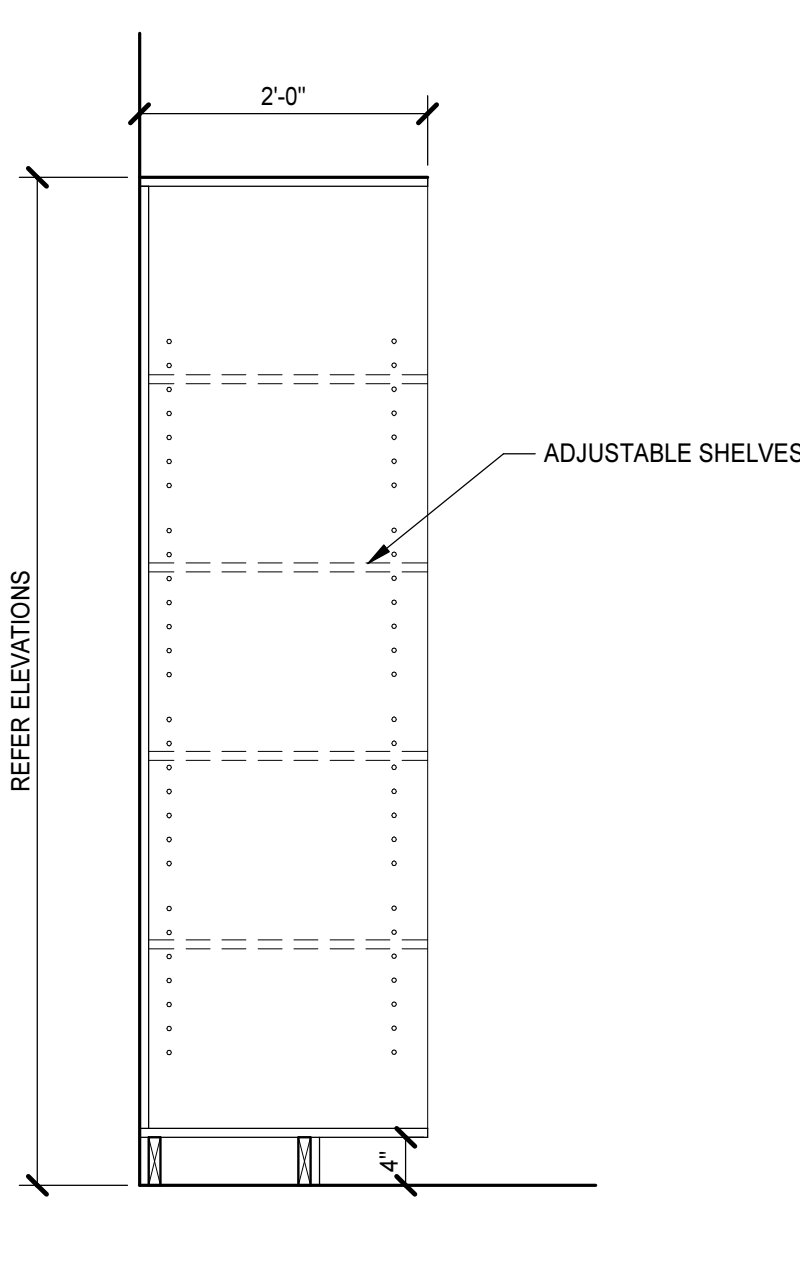


9 DETAIL - ACCESSIBLE TOE KICK
3" = 1'-0"

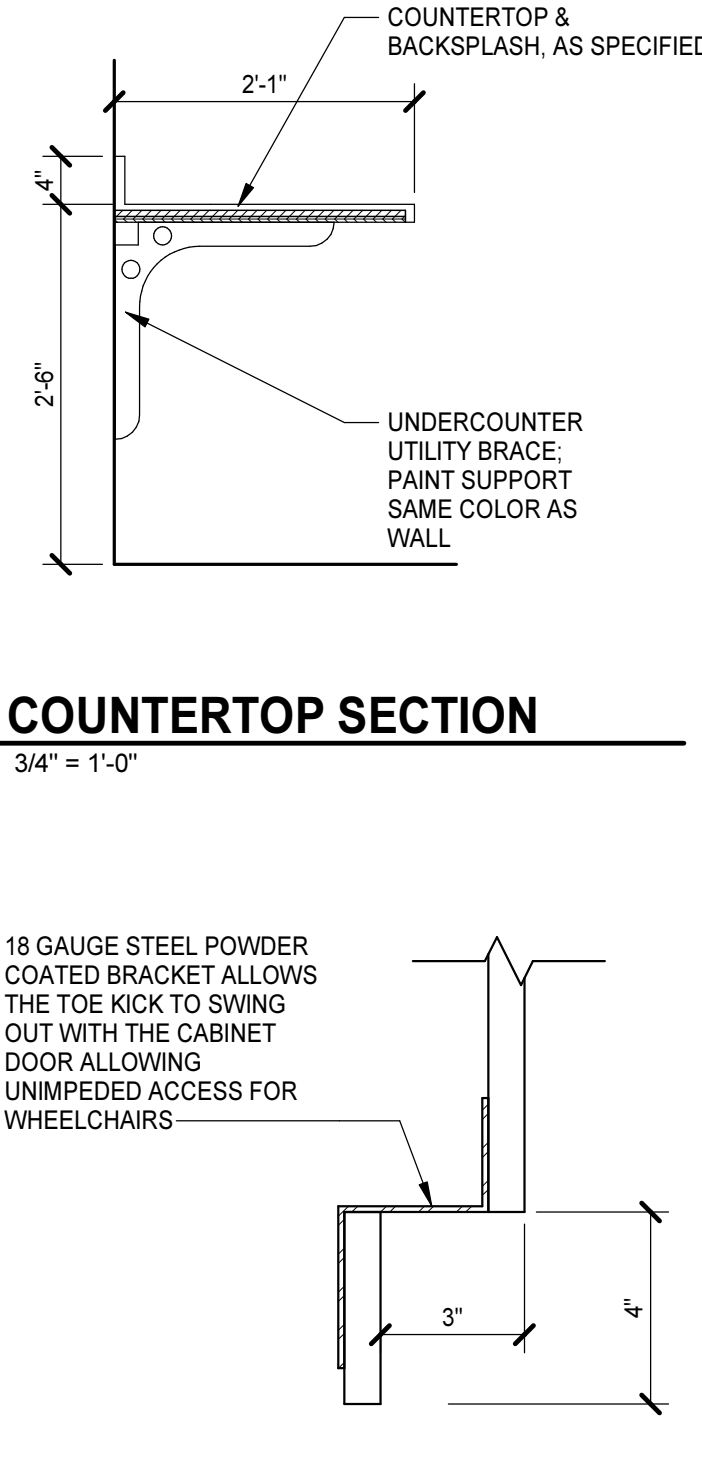


8 112 WARDENS
1/4" = 1'-0"

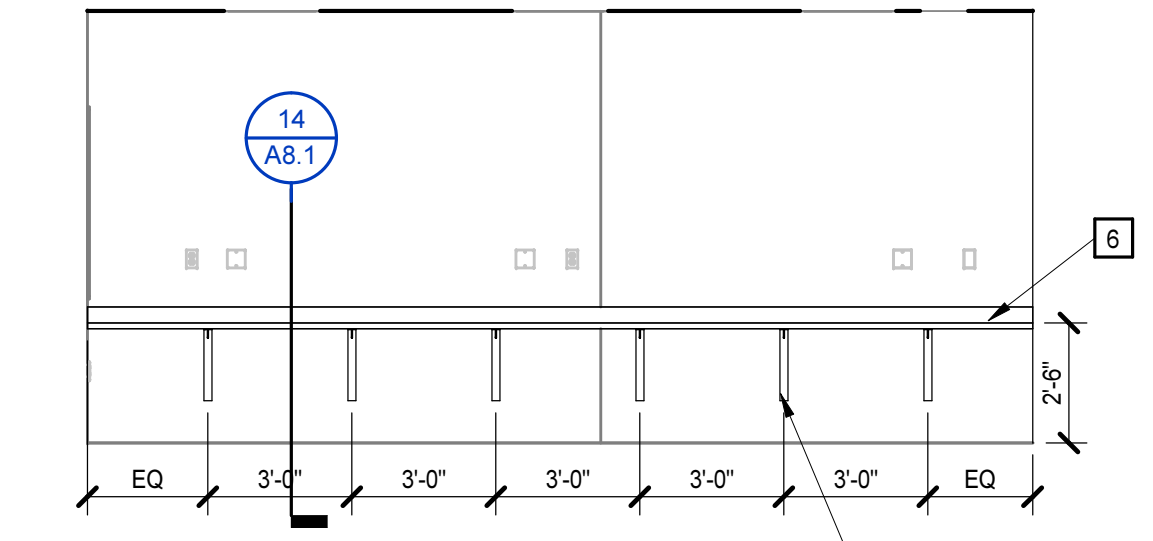

15 TYPICAL ACOUSTIC WALL PANELS (BID ADDITIVE)
1/4" = 1'-0"

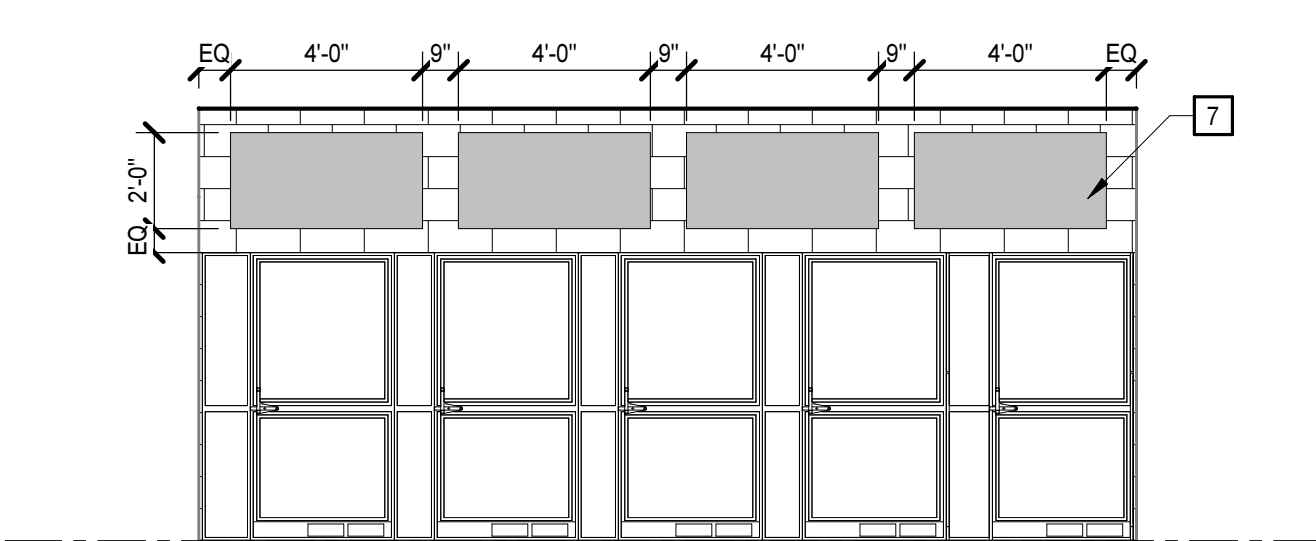

16 ACOUSTIC WALL PANELS - RM 106 (BID ADDITIVE)
1/4" = 1'-0"

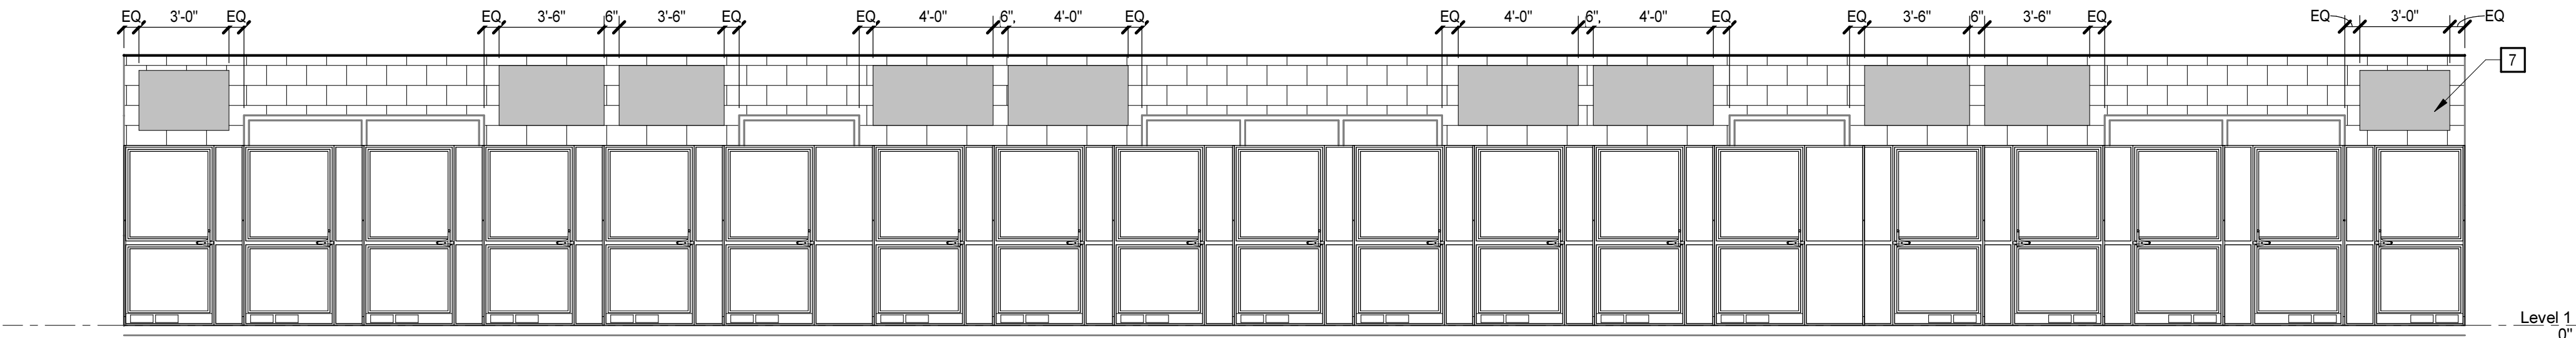


CASEWORK GENERAL NOTES

- A. UNLESS INDICATED OTHERWISE, ALL COUNTERTOP(S):
a. 2'-10" AFF MAX OR 2'-10" MAX TO TOP OF RIM AT DROP-IN SINKS AND LAVATORIES WHERE OCCURS
b. 2'-1" DEEP
c. STAINLESS STEEL
d. BACKSPLASHES: 4" HIGH AT ALL SIDES AND BACK
e. EXTEND COUNTERTOP 1/2" PAST BASE CABINET AT ALL EXPOSED CASEWORK ENDS
f. VERIFY SLAB LEVELNESS AT CASEWORK PRIOR TO INSTALL. CONSTRUCTION TOLERANCES DO NOT APPLY TO ACCESSIBILITY DIMENSIONS, MAX DIMENSIONS SHALL BE MAINTAINED.
- B. UNLESS INDICATED OTHERWISE, ALL BASE CABINET(S):
a. 2'-0" DEEP NOMINAL
b. TOE KICKS: 4" NOMINAL HIGH (REDUCE AS NEEDED FOR TOLERANCES) AND 3" DEEP
c. SINK LOCATIONS: BASE CABINET WITH ATTACHED TOE KICK FOR BARRIER FREE ACCESS. WIDTH AS INDICATED ON DRAWING.
d. PHENOLIC CORE
- C. UNLESS INDICATED OTHERWISE, ALL WALL CABINET(S):
a. 1'-0 1/2" DEEP NOMINAL
b. 2'-0" HIGH
c. TOP AT 7'-0" AFF
d. MINIMUM 11" CLEAR INTERIOR DEPTH
e. PHENOLIC CORE
- D. UNLESS INDICATED OTHERWISE, ALL TALL CABINET(S):
a. 2'-0" DEEP NOMINAL
b. 7'-0" HIGH
c. TOE KICKS: 4" HIGH AND 3" DEEP
d. PHENOLIC CORE
- E. BUILT-IN EQUIPMENT: SIZE OPENING (HEIGHT, WIDTH, AND DEPTH) AND ROUGH-IN REQUIREMENTS AS REQUIRED BASED ON APPROVED MANUFACTURER SUBMITTED.
- F. ALL SHELVES: ADJUSTABLE UNLESS INDICATED OTHERWISE.
- G. PROVIDE FINISH END PANELS AT ALL EXPOSED CASEWORK ENDS.
- H. LOCKS: REQUIRED ONLY IN ROOM 118


CASEWORK KEYNOTES

REPRESENTED BY **7**
APPLIES TO DRAWINGS A8.1 - A8.m


1. EXTEND STAINLESS STEEL BACKSPLASH TO WALL CABINETS
2. ADA CABINET WITH ATTACHED TOE-KICK
3. RECTANGULAR CLOSURE PANEL TO MATCH CABINETS
4. SUPPORT BRACKET
5. SIDE SPLASH
6. SOLID SURFACE COUNTERTOP AND BACKSPLASH
7. ACOUSTIC WALL PANELS, PAINTED IN FIELD
8. RECTANGULAR STAINLESS STEEL CLOSURE PANEL
9. 3/4" RECTANGULAR STAINLESS STEEL PANEL

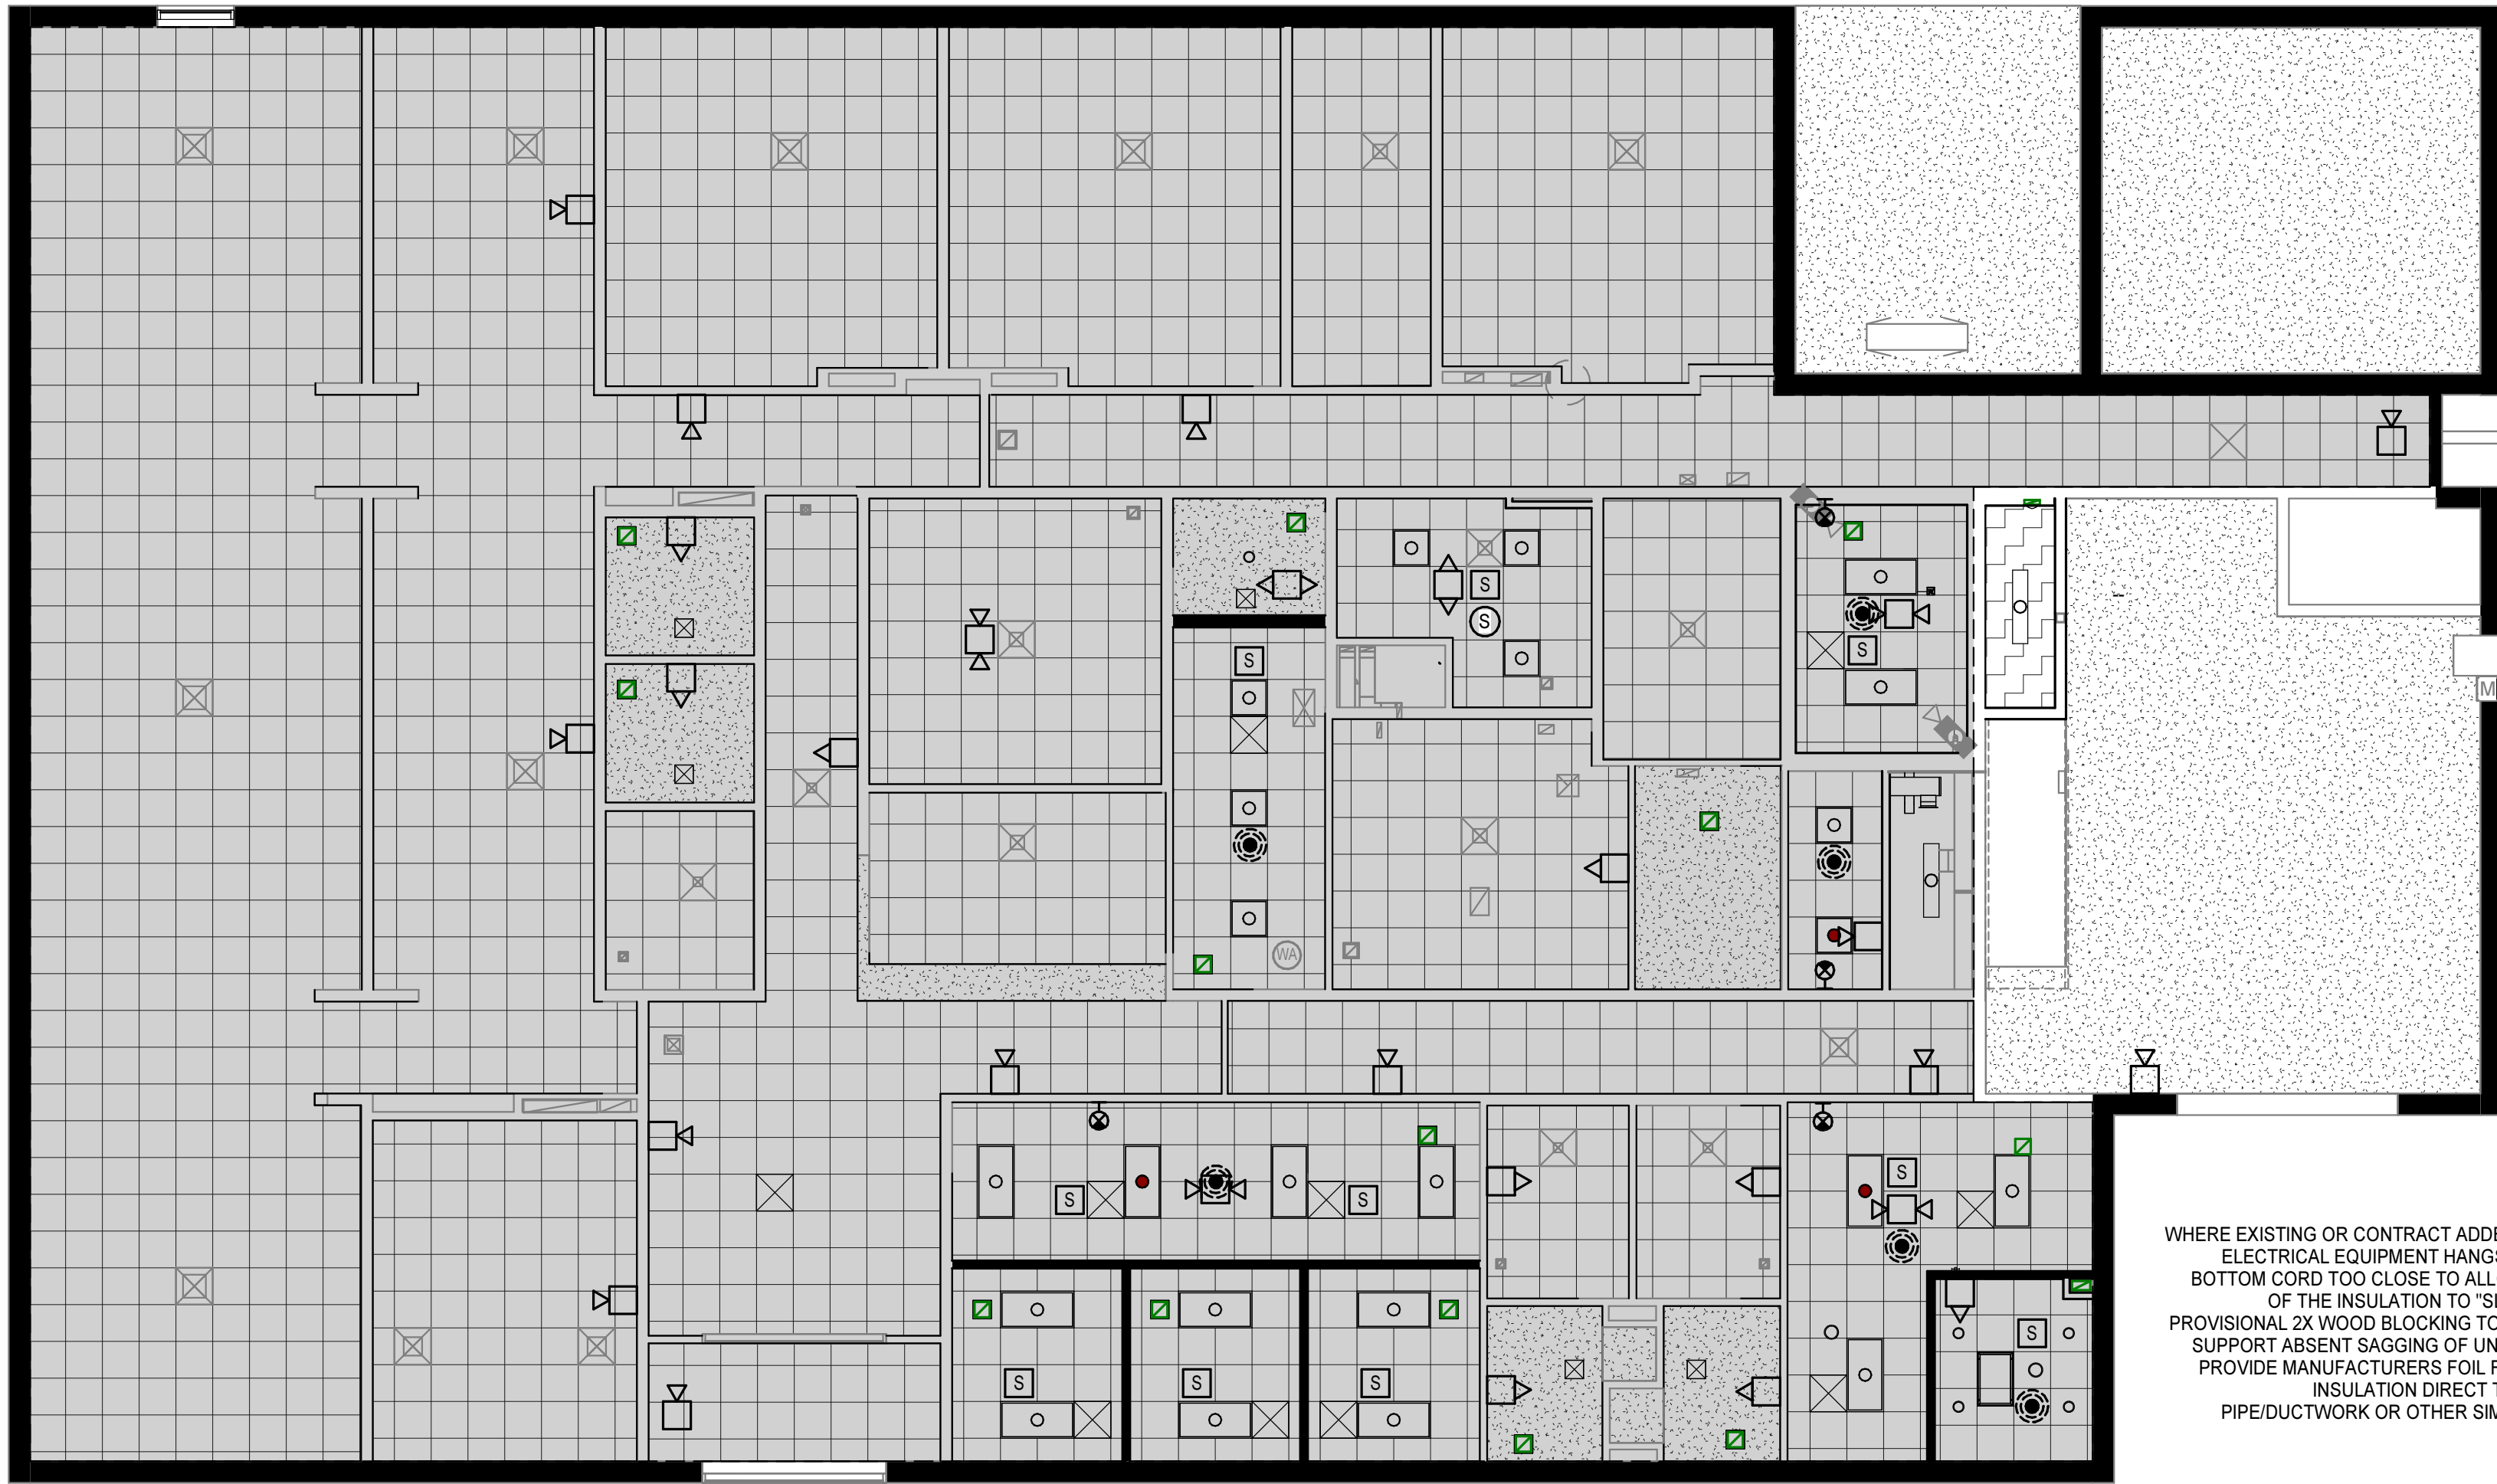

REFLECTED CEILING PLAN - INSULATION WORK
1/8" = 1'-0"

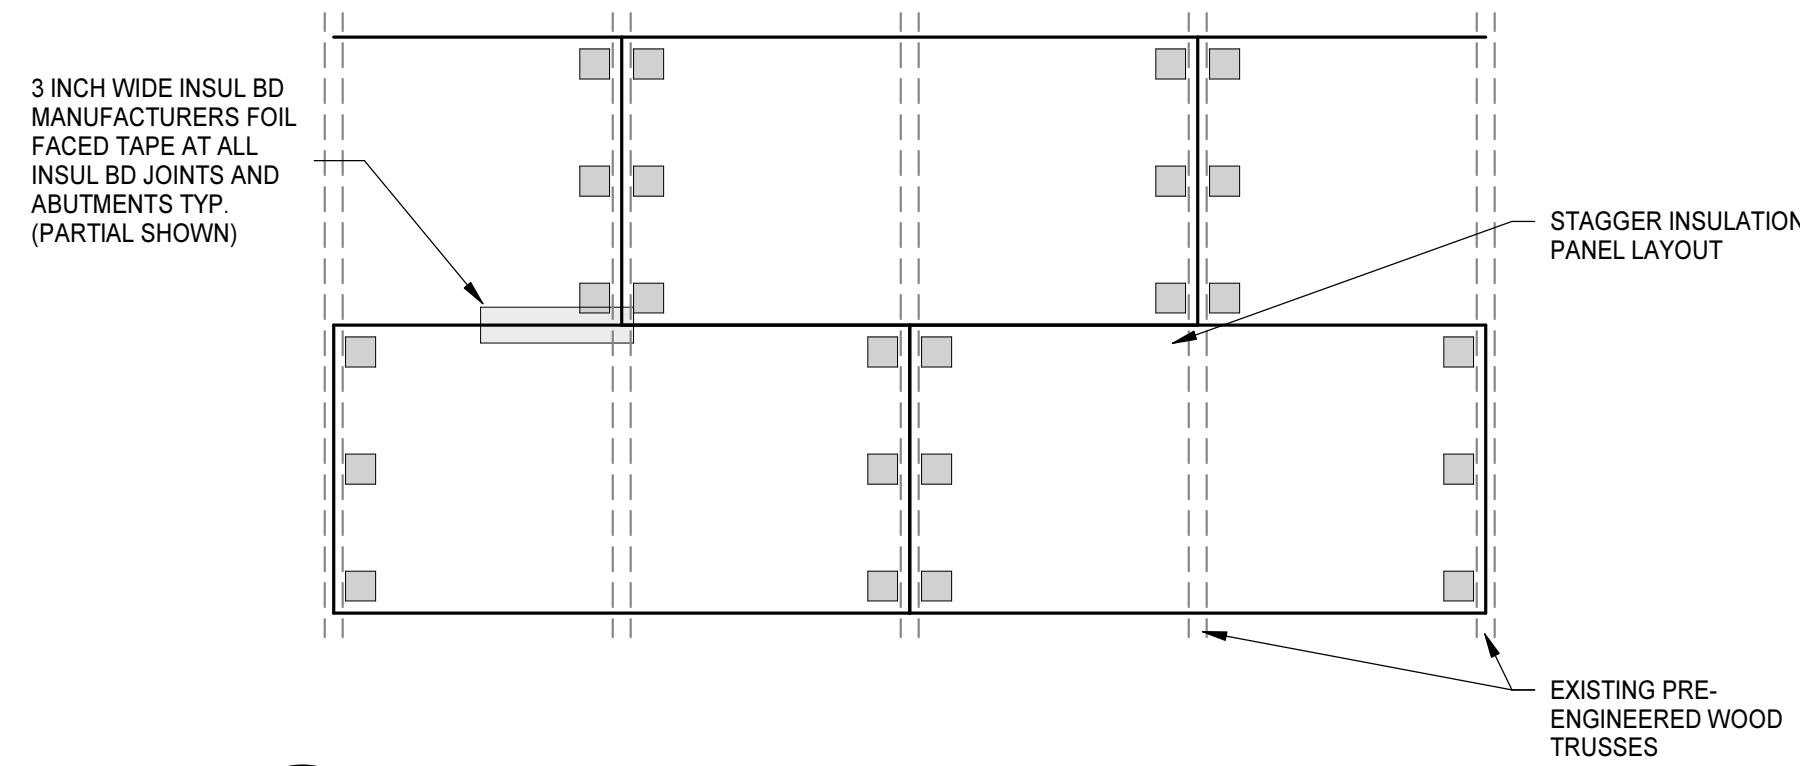


REFLECTED VIEW - PANEL LAYOUT
3/4" = 1'-0"

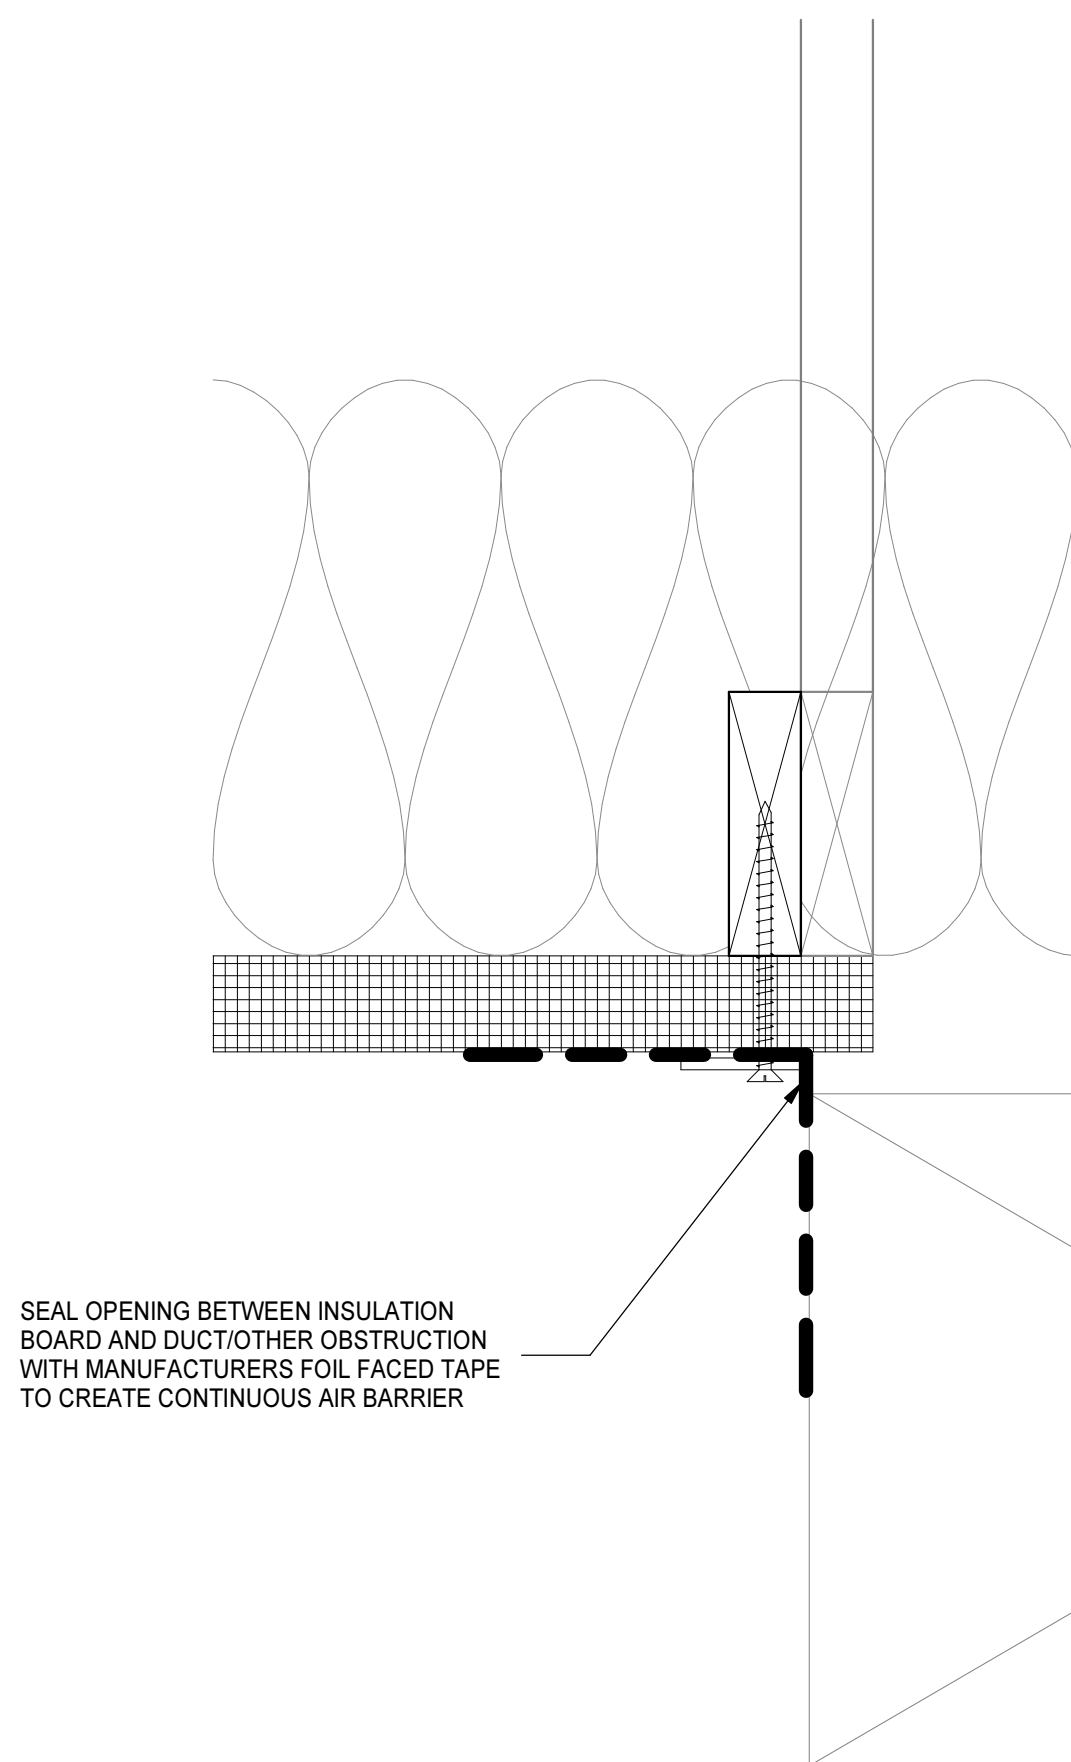

DETAIL
3" = 1'-0"

WHERE EXISTING OR CONTRACT ADDED MECHANICAL AND ELECTRICAL EQUIPMENT HANGS BELOW THE TRUSS BOTTOM CORD TOO CLOSE TO ALLOW FULL THICKNESS OF THE INSULATION TO "SLIDE THROUGH" ADD PROVISIONAL 2X WOOD BLOCKING TO ASSURE ADEQUATE SUPPORT. ASSESS SAGGING OF UNSUPPORTED EDGES. PROVIDE MANUFACTURERS FOIL FACED TAPE TO SEAL INSULATION DIRECT TO SUCH OFFENDING PIPE/DUCTWORK OR OTHER SIMILAR OBSTRUCTION.

DETAIL
3/4" = 1'-0"

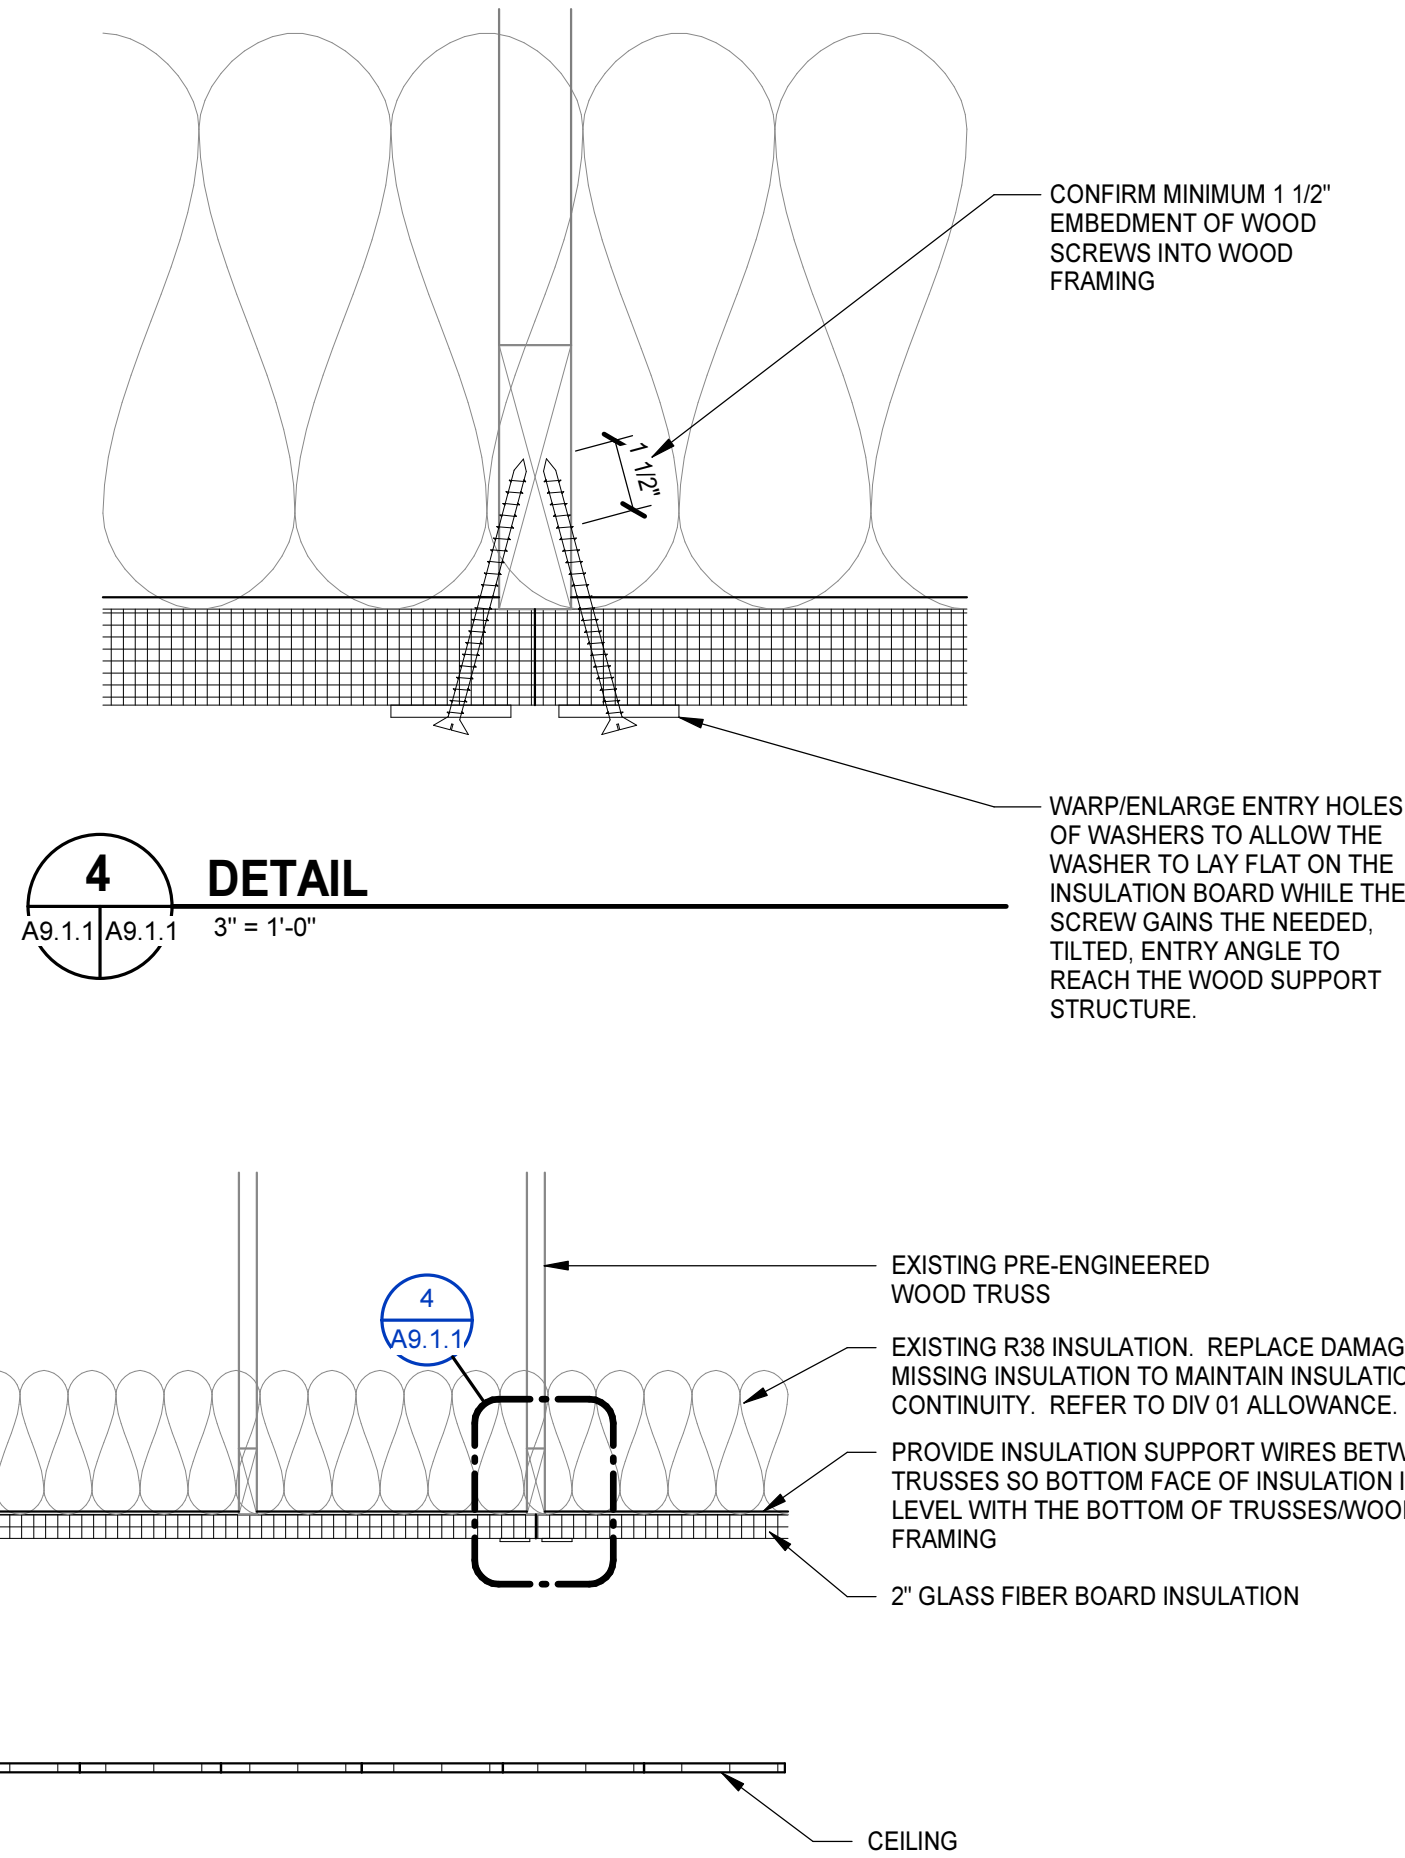

DETAIL
3" = 1'-0"



FIRST FLOOR PLAN
1/8" = 1'-0"

REFLECTED CEILING PLAN LEGEND

APPLIES TO DRAWINGS A9.1.1
REFER TO M, E & FP DRAWINGS FOR REFLECTED CEILING PLAN SYMBOLS NOT INDICATED BELOW

	SPACE NUMBER CEILING HEIGHT, AFF UNO
	INTERIOR APPLICATIONS: GYPSUM BOARD CEILING
	EXTERIOR APPLICATIONS: GYPSUM SOFFIT BOARD OR GYPSUM SHEATHING
	2'-0" x 2'-0" LAY-IN ACOUSTICAL CEILING PANELS IN SUSPENDED GRID
	1 HR RATED HORIZONTAL SHAFT WALL (X2)
	INSTALL 2' GLASS FIBER INSULATION BOARD AGAINST EXISTING STRUCTURE
	ACCESS PANEL
	EXTERIOR WALL
	INTERIOR WALL/PARTITION TO UNDERSIDE OF DECK
	INTERIOR WALL/PARTITION TO CAP ABOVE OR TERMINATES ADJACENT TO A RATED HORIZONTAL ASSEMBLY
	INTERIOR WALL/PARTITION 4' MIN ABOVE HIGHEST ADJACENT CEILING. IF NECESSARY TO ACHIEVE RESULTS DESIRED, EXTEND WALL HEIGHT SO WALL BRACING IS NOT EXPOSED TO VIEW IN FINISHED SPACES
	INTERIOR WALL/PARTITION TO UNDERSIDE OF CEILING
	EXISTING TO REMAIN, VERIFY VERTICAL EXTENTS WHERE THE HEIGHT IMPACTS THE WORK


REFLECTED CEILING PLAN/DETAIL GENERAL NOTES

- ALL CEILING HEIGHTS SHALL BE 9'-0" AFF UNLESS INDICATED OTHERWISE.
- DRAWINGS INDICATE GRID LAYOUT DIAGRAMMATICALLY. REFER TO SPECIFICATIONS FOR SPECIFIC GRID LAYOUT CRITERIA AT PERIMETER CONDITIONS THAT MAY DIFFER FROM GRID LAYOUT INDICATED ON DRAWINGS.
- CENTER CEILING MOUNTED ITEMS WITHIN CEILING PANELS, UNLESS INDICATED OTHERWISE.
- REINSTALL ALL CEILING ELEMENTS REMOVED FOR INSULATION INSTALLATION AND CEILING REPLACEMENT.

REFLECTED CEILING PLAN KEYNOTES

REPRESENTED BY [n]
APPLIES TO DRAWINGS A9.1.1

- CFSS-S
- 5/8" GYP BD, TERMINATE 4" ABV FIN CLG
- FIN CLG: FINISH AND/OR HEIGHT AFF VARIES
- GYP BD: EXTEND FULL HEIGHT, UNLESS INDICATED OTHERWISE
- EXISTING CEILING TO REMAIN
- PROVIDE SLOTTED METAL FRAMING ABOVE CEILING FOR SURGICAL LIGHTS
- EXTEND WALLS UP TO HORIZONTAL SHAFTWALL FOR CONTINUOUS RATING ENCLOSURE
- PROVIDE HORIZONTAL SHAFT WALL ENCLOSING WAGO PIPING ABOVE CEILING
- PROVIDE P7-1 WALLS FROM HORIZONTAL SHAFT WALL TO ROOF TO ENCLOSE PIPING

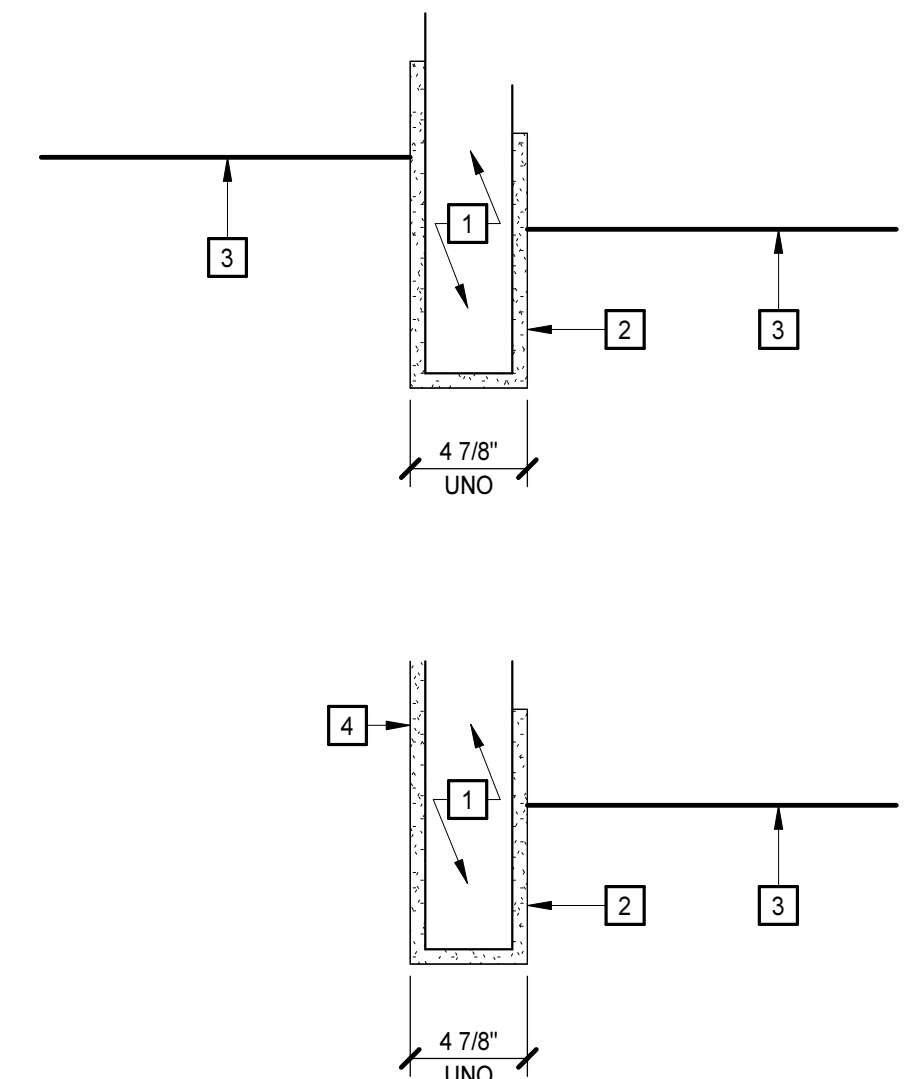

BULKHEAD DETAILS
NO SCALE



ABBREVIATIONS

@	AT	EX	EXISTING	PC	PRECAST
AAV	AIR ADMITTANCE VALVE	EXP	EXPANSION	PCF	POUNDS PER CUBIC FOOT
ABV	ABOVE	FOO	FLOOR CLEANOUT	PD	PUMP DISCHARGE
AC-X	AIR COMPRESSOR DESIGNATION	FD	FLOOR DRAIN	PLUMB	PLUMBING
ADJ	ADJUSTABLE	FDC	FIRE DEPARTMENT CONNECTION	PLYWD	PLYWOOD
ADNL	ADDITIONAL	FF	FINISHED FLOOR	POLY	POLYETHYLENE
APF	ABOVE FINISHED FLOOR	FFE	FINISHED FLOOR ELEVATION	PPT	PRESSURE PRESERVATIVE TREATED
AFS	ABOVE FINISHED GRADE	FG	FINISHED GRADE	REFAB	REFABRICATE(D)
AHU	AIR HANDLING UNIT	FH	FIRE HYDRANT	PROJ	PROJECT
ALT	ALTERMATE	FHC	FIRE HOSE CABINET	PSF	POUNDS PER SQUARE FOOT
ALUM	ALUMINUM	FHS	FIRE HOSE STATION	PSI	POUNDS PER SQUARE INCH
AP	ACCESS PANEL	FV	FIRE VALVE CABINET	PV	PROPANE VENT
APPR	APPROXIMATE	FX	FIXTURE	PVC	POLYVINYL CHLORIDE
ARCH	ARCHITECTURAL	FLR	FLOOR	PVMT	PAVEMENT
AUTO	AUTOMATIC	FLSHG	FLASHING	R	RISER
AVG	AVERAGE	FOR	FUEL OIL RETURN	RAD	RADIUS
BFF	BELOW FINISHED FLOOR	FOS	FUEL OIL SUPPLY	RC-P	RECIRCULATION PUMP DESIGNATION
BFG	BELOW FINISHED GRADE	FOV	FUEL OIL VENT	RD	ROOF DRAIN (BOTTOM OUTLET)
BLDG	BUILDING	FS	FLOOR SINK	RDS	ROOF DRAIN (SIDE OUTLET)
BO	BOTTOM OF	FSD	FOUNDATION SUB-DRAIN	REF	REFERENCE
BOT	BOTTOM	FT	FOOT OR FEET	REQD	REQUIRED
BSMT	BASSEMENT	FVC	FIRE VALVE CABINET	REQMT	REQUIREMENTS
BTWN	BETWEEN	G	GAS	RL	RAIN LEADER
CA	COMPRESSED AIR	GCO	GRADE CLEANOUT	RM	ROOM
CI	CAST IRON	GWV	GAS WATER HEATER	RO	ROUGH OPENING
CP	CAST-IN-PLACE CONCRETE	HB	HOSE BIBB	RV	SOUTH
CL	CENTERLINE	HORIZ	HORIZONTAL	S	SANITARY
CLG	CEILING	HP	HORSEPOWER	SCH	SCHEDULE
CLR	CLEAR	HR-X	HOSE REEL DESIGNATION	SD	STORM DRAINAGE PIPING
CMP	CORRUGATED METAL PIPE	HTG	HEATING	SDN	STORM DRAIN NOZZLE
CNTR	COUNTER	HV	HOT WATER	SF	SQUARE FOOT/FEET
CO	CLEANOUT	HWR	HOT WATER RETURN	SHT	SHEET
COL	COLUMN	HWS	HOT WATER SUPPLY	SIM	SIMILAR
CONC	CONCRETE	ID	INSIDE DIAMETER	SLT	SEALANT
CONDS	CONDENSATE	IN	INCH	SLT	SEALANT
CONSTR	CONSTRUCTION	INSUL	INSULATE OR INSULATION	SOG	SLAB ON GRADE
CONT	CONTINUATION	INV	INVERT	SP	SUMP PUMP
CONTR	CONTRACT-(OR)	JAN	JANITOR	SPEC	SPECIFICATION
CORR	CORRIDOR	KIT	KITCHEN	SPR	SPRINKLER
CP	CIRCULATING PUMP	KW	KITCHEN WASTE	SQ	SQUARE
CR	CLASSROOM	LAB	LABORATORY	SRO	SECONDARY ROOF DRAIN
CT	COOLING TOWER	LAV	LAVATORY	SS	STAINLESS STEEL
CU	COPPER	LBS	POUNDS	SSD	SECONDARY STORM DRAINAGE PIPING
CU FT	CUBIC FEET	LF	LINEAR FOOT (FEET)	STD	STANDARD
CU YD	CUBIC YARD	LP	PROPANE	STL	STEEL
CW	COLD WATER	LPV	PROPANE VENT	STOR	STORAGE
DB	DRY BULB	MATL	MATERIAL	STRUCT	STRUCTURAL
DCW	DOMESTIC COLD WATER	MAX	MAXIMUM	SUSP	SUSPENDED
DEMO	DEMOLISH OR DEMOLITION	MECH	MECHANICAL	TD	TRENCH DRAIN
DF	DRINKING FOUNTAIN	MED	MEDIUM	THK	THICKNESS
DHR(140)	DOMESTIC HOT WATER RETURN (140°)	MFR	MANUFACTURER	TLT	TOILET
DHW	DOMESTIC HOT WATER	MH	MANHOLE	TMV	THERMOSTATIC MIXING VALVE
DHW(140)	DOMESTIC HOT WATER (140°)	MIN	MINIMUM	TOSL	TOP OF SLAB
DI	DROP INLET	MISC	MISCELLANEOUS	TW	DOMESTIC TEMPERED WATER (90° F)
DIA	DIAMETER	MTD	MOUNTED	TYP	TYPICAL
DIP	DUCTILE IRON PIPE	N	NORTH	UG	UNDERGROUND
DN	DOWN	N/A	NOT APPLICABLE/AVAILABLE	UNO	UNLESS NOTED (INDICATED) OTHERWISE
DR-X	COMPRESSED AIR DRYER DESIGNATION	NC	NORMALLY CLOSED	V	VENT
DS	DOWNSPOUT	NG	NATURAL GAS	VAC	VACUUM
DT	DRAIN TILE	NOV	NATURAL GAS VENT	VB	VACUUM BREAKER
DTL	DETAIL	NIC	NOT IN CONTRACT	VERT	VERTICAL
DTW	DOMESTIC TEMPERED WATER	NO	NORMALLY OPEN	VIF	VERIFY IN FIELD
DWG	DRAWING	NO. (#)	NUMBER	VTR	VENT THROUGH ROOF
DWP	DOMESTIC WATER BOOSTER PUMP	NOM	NOMINAL	W	WEST
E	EAST	O2	OXYGEN	W	WITH
ED	EMERGENCY SECONDARY ROOF DRAIN	OC	ON CENTER	W/O	WITHOUT
ELEC	ELECTRICAL	OD	OUTSIDE DIAMETER	WAGO	WASTE ANESTHETIC GAS DISPOSAL
ELEV	ELEVATION	OFCI	OWNER FURNISHED CONTRACTOR INSTALLED	WB	WATER HAMMER ARRESTER
EFBD	ELECTRICAL PANELBOARD	OFF	OFFICE	WC	WATER CLOSET
EQ	EQUAL	OH	OVERHEAD	WCO	WALL CLEANOUT
EQUIP	EQUIPMENT	OPNG	OPENING	WSHF	WATER SOURCE HEAT PUMP
ETR	EXISTING TO REMAIN	OPP	OPPOSITE	WWF	WELDED WIRE FABRIC
EVC	ELECTRIC WATER COOLER	OSD	OPEN SITE DRAIN	WWM	WELDED WIRE MESH
EVH	ELECTRIC WATER HEATER	OXY	OXYGEN	XFMR	TRANSFORMER

GRAPHICS SYMBOLS LEGEND


	PIPE WITH SIZE AND SERVICE		POINT OF CONNECTION TO EXISTING
	FLOW IN DIRECTION OF ARROW		LIMIT OF DEMOLITION
	PITCH DOWN IN DIRECTION OF ARROW AT INDICATED SLOPE		KEYNOTE
	PIPE CAP		STRUCTURAL GRID LINE WITH DESIGNATION
	PIPE TURNED DOWN		SPACE IDENTIFICATION TAG SPACE NUMBER BUILDING AREA (WHEN USED)
	PIPE TURNED UP		EQUIPMENT IDENTIFICATION TAG EQUIPMENT NUMBER UNIT DESIGNATION
	PIPE TEE UP		
	PIPE TEE DOWN		
	UNION		
	CONCENTRIC PIPE REDUCTION		
	END OF LINE CLEANOUT PLUG		
	FLOOR CLEANOUT		
	WALL CLEANOUT		
	YARD CLEANOUT (CLEANOUT TO GRADE)		
	FLOOR DRAIN WITH TAG		
	FLOOR SINK WITH TAG		
	PRESSURE GAUGE WITH GAUGE COCK		
	LIQUID FILLED THERMOMETER		
	WATER HAMMER ARRESTOR (PLUMBING & DRAINAGE INSTITUTE SIZE INDICATED)		
	FLOW SWITCH		
	TEMPERATURE/PRESSURE PLUG		
	VALVE		
	VALVE IN RISER		
	GAS COCK		
	VENTURI FLOW METER		
	MANUAL BALANCING VALVE		
	AUTOMATIC BALANCING VALVE WITH FLOW TAPS		
	SWING CHECK VALVE		
	PRESSURE REDUCING VALVE		
	SOLENOID OPERATED VALVE		
	TEMPERATURE AND PRESSURE RELIEF VALVE		
	BACKWATER VALVE		
	HOSE BIBB OR WALL HYDRANT		
	REDUCED PRESSURE PRINCIPLE BACKFLOW PREVENTER		
	DOUBLE CHECK BACKFLOW PREVENTER		
	PUMP		

	SECTION WHERE CUT SECTION LETTER DRAWING WHERE SECTION IS INDICATED
	ENLARGED PLAN WHERE CUT ENLARGED PLAN NUMBER DRAWING WHERE ENLARGED PLAN IS INDICATED
	DETAIL TAG DETAIL NUMBER DRAWING WHERE DETAIL IS INDICATED
	SANITARY RISER TAG SANITARY RISER IDENTIFIER DRAWING WHERE SANITARY RISER IS TAGGED
	DOMESTIC RISER TAG DOMESTIC RISER IDENTIFIER DRAWING WHERE DOMESTIC RISER IS TAGGED


	DETAIL TITLE DETAIL NUMBER DRAWING WHERE DETAIL IS INDICATED DRAWING WHERE DETAIL IS CUT ADDITIONAL DRAWING REFERENCES
	SANITARY RISER DIAGRAM SANITARY RISER DIAGRAM IDENTIFIER DRAWING WHERE SANITARY RISER IS INDICATED DRAWING WHERE SANITARY RISER IS TAGGED ADDITIONAL DRAWING REFERENCES
	DOMESTIC RISER DIAGRAM DOMESTIC RISER DIAGRAM IDENTIFIER DRAWING WHERE DOMESTIC RISER IS INDICATED DRAWING WHERE DOMESTIC RISER IS TAGGED ADDITIONAL DRAWING REFERENCES
	FUEL GAS RISER DIAGRAM FUEL GAS RISER DIAGRAM IDENTIFIER DRAWING WHERE FUEL GAS RISER IS INDICATED DRAWING WHERE FUEL GAS RISER IS TAGGED ADDITIONAL DRAWING REFERENCES

GENERAL NOTES

- A. THE CONTRACT DOCUMENTS ARE COMPLEMENTARY AND WHAT IS REQUIRED BY ONE SHALL BE AS BINDING AS IF REQUIRED BY ALL. IN THE CASE OF A CONFLICT, DISAGREEMENT, OR AMBIGUITY, PROVIDE THE BETTER QUALITY. IN THE CASE OF A CONFLICT, DISAGREEMENT, OR AMBIGUITY, PROVIDE THE GREATER QUANTITY OF WORK.
- B. COORDINATE PIPING LOCATIONS AND INSTALLATION WITH EACH TRADE TO AVOID CONFLICTS WITH OTHER TRADES.
- C. PROVIDE FLOOR CLEANOUTS INDICATED FLUSH WITH FLOOR FINISHES.
- D. PROVIDE CLEANOUTS WHERE INDICATED AND ADDITIONAL CLEANOUTS AS REQUIRED BY LOCAL CODE.
- E. REFER TO DRAWINGS FROM EACH DISCIPLINE BEFORE ROUGHING-IN PLUMBING FIXTURES.
- F. OBTAIN DIMENSIONS AND ROUTING IN FIELD BEFORE INSTALLATION OF PLUMBING AND FIXTURES.
- G. INSTALL ALL DRAINAGE PATTERN FITTINGS AND PIPING IN ACCORDANCE WITH APPLICABLE FEDERAL, STATE, AND LOCAL CODES.
- H. PROVIDE ISOLATION VALVES IN ACCORDANCE WITH DIAGRAMS, DETAILS, AND DIVISION 22 SPECIFICATIONS.

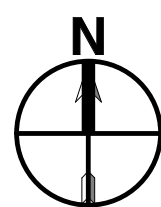



FOUNDATION PLAN - DEMOLITION - PLUMBING
1/4" = 1'-0"

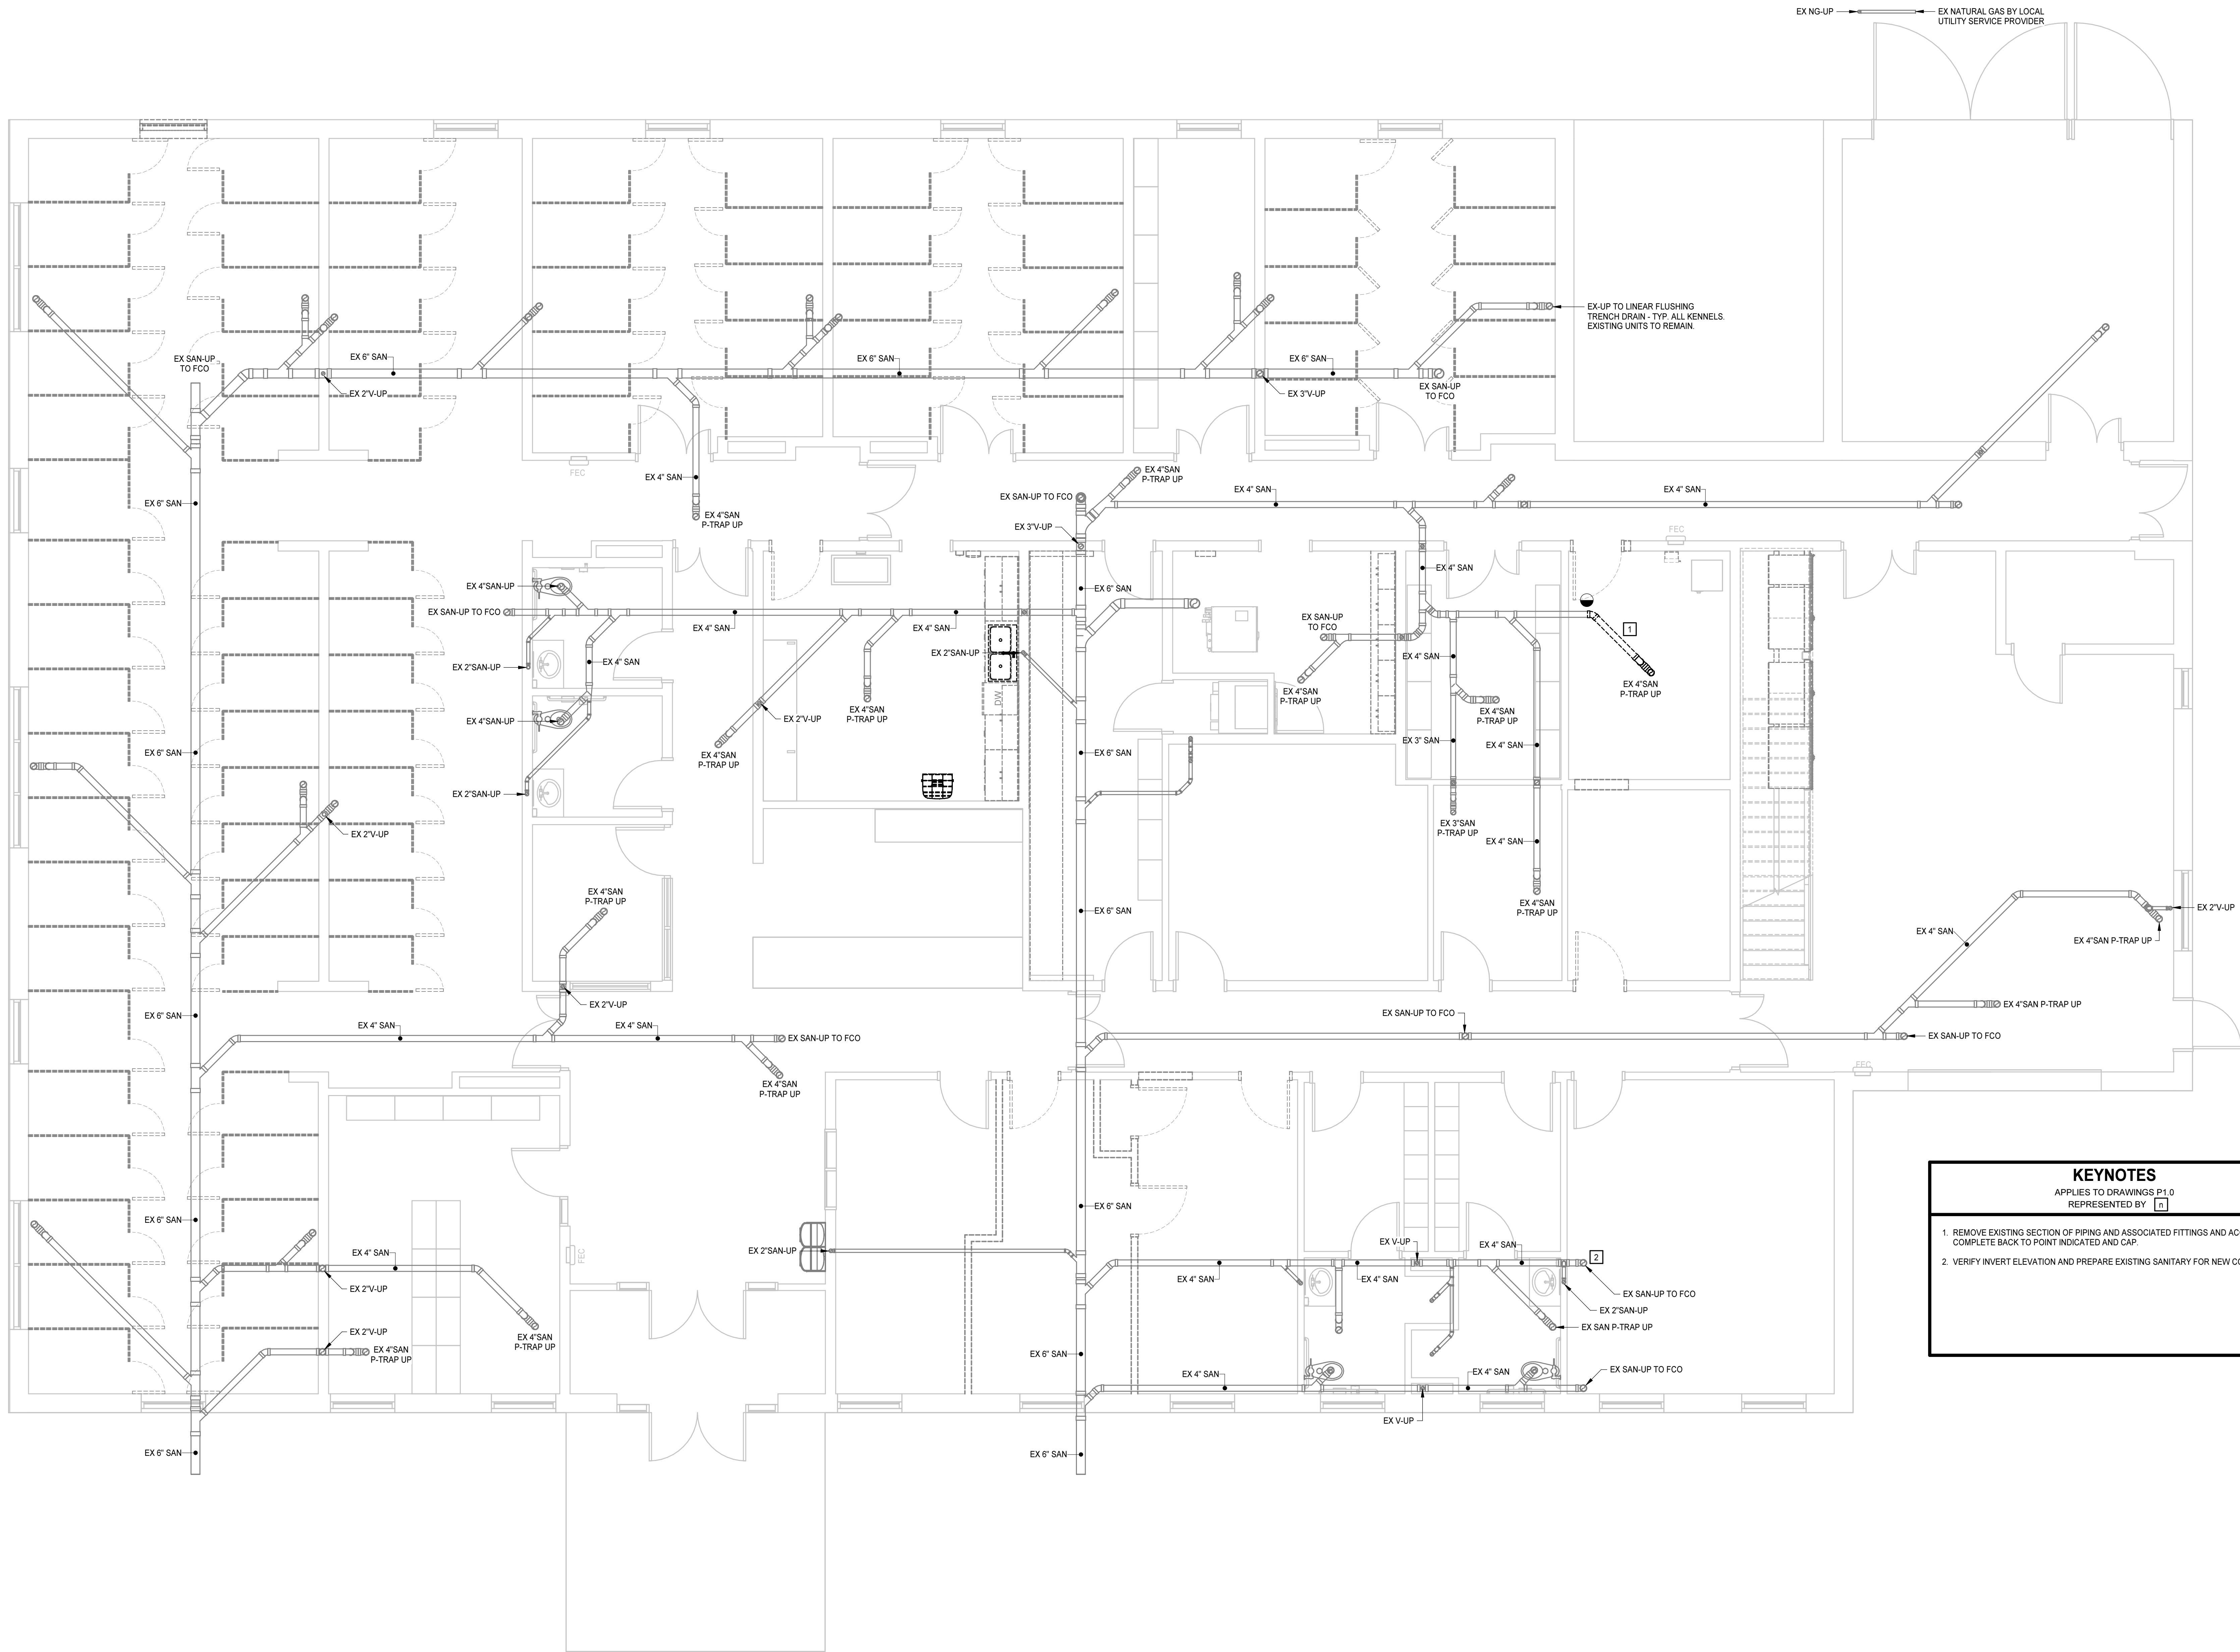

KEYNOTES

APPLIES TO DRAWINGS P1.0
REPRESENTED BY [N]

1. REMOVE EXISTING SECTION OF PIPING AND ASSOCIATED FITTINGS AND ACCESSORIES COMPLETE BACK TO POINT INDICATED AND CAP.
2. VERIFY INVERT ELEVATION AND PREPARE EXISTING SANITARY FOR NEW CONNECTION.

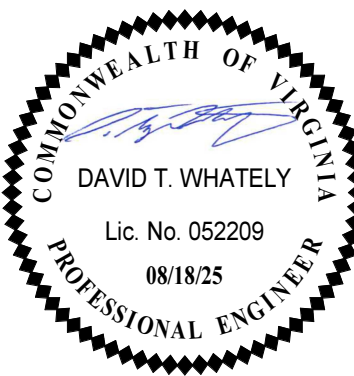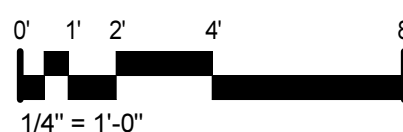


8/18/2025 12:06:16 PM




FIRST FLOOR PLAN - DEMOLITION - SANITARY

1/4" = 1'-0"

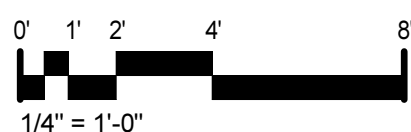

FIRST FLOOR PLAN -
DEMOLITION -
SANITARY

P1.1

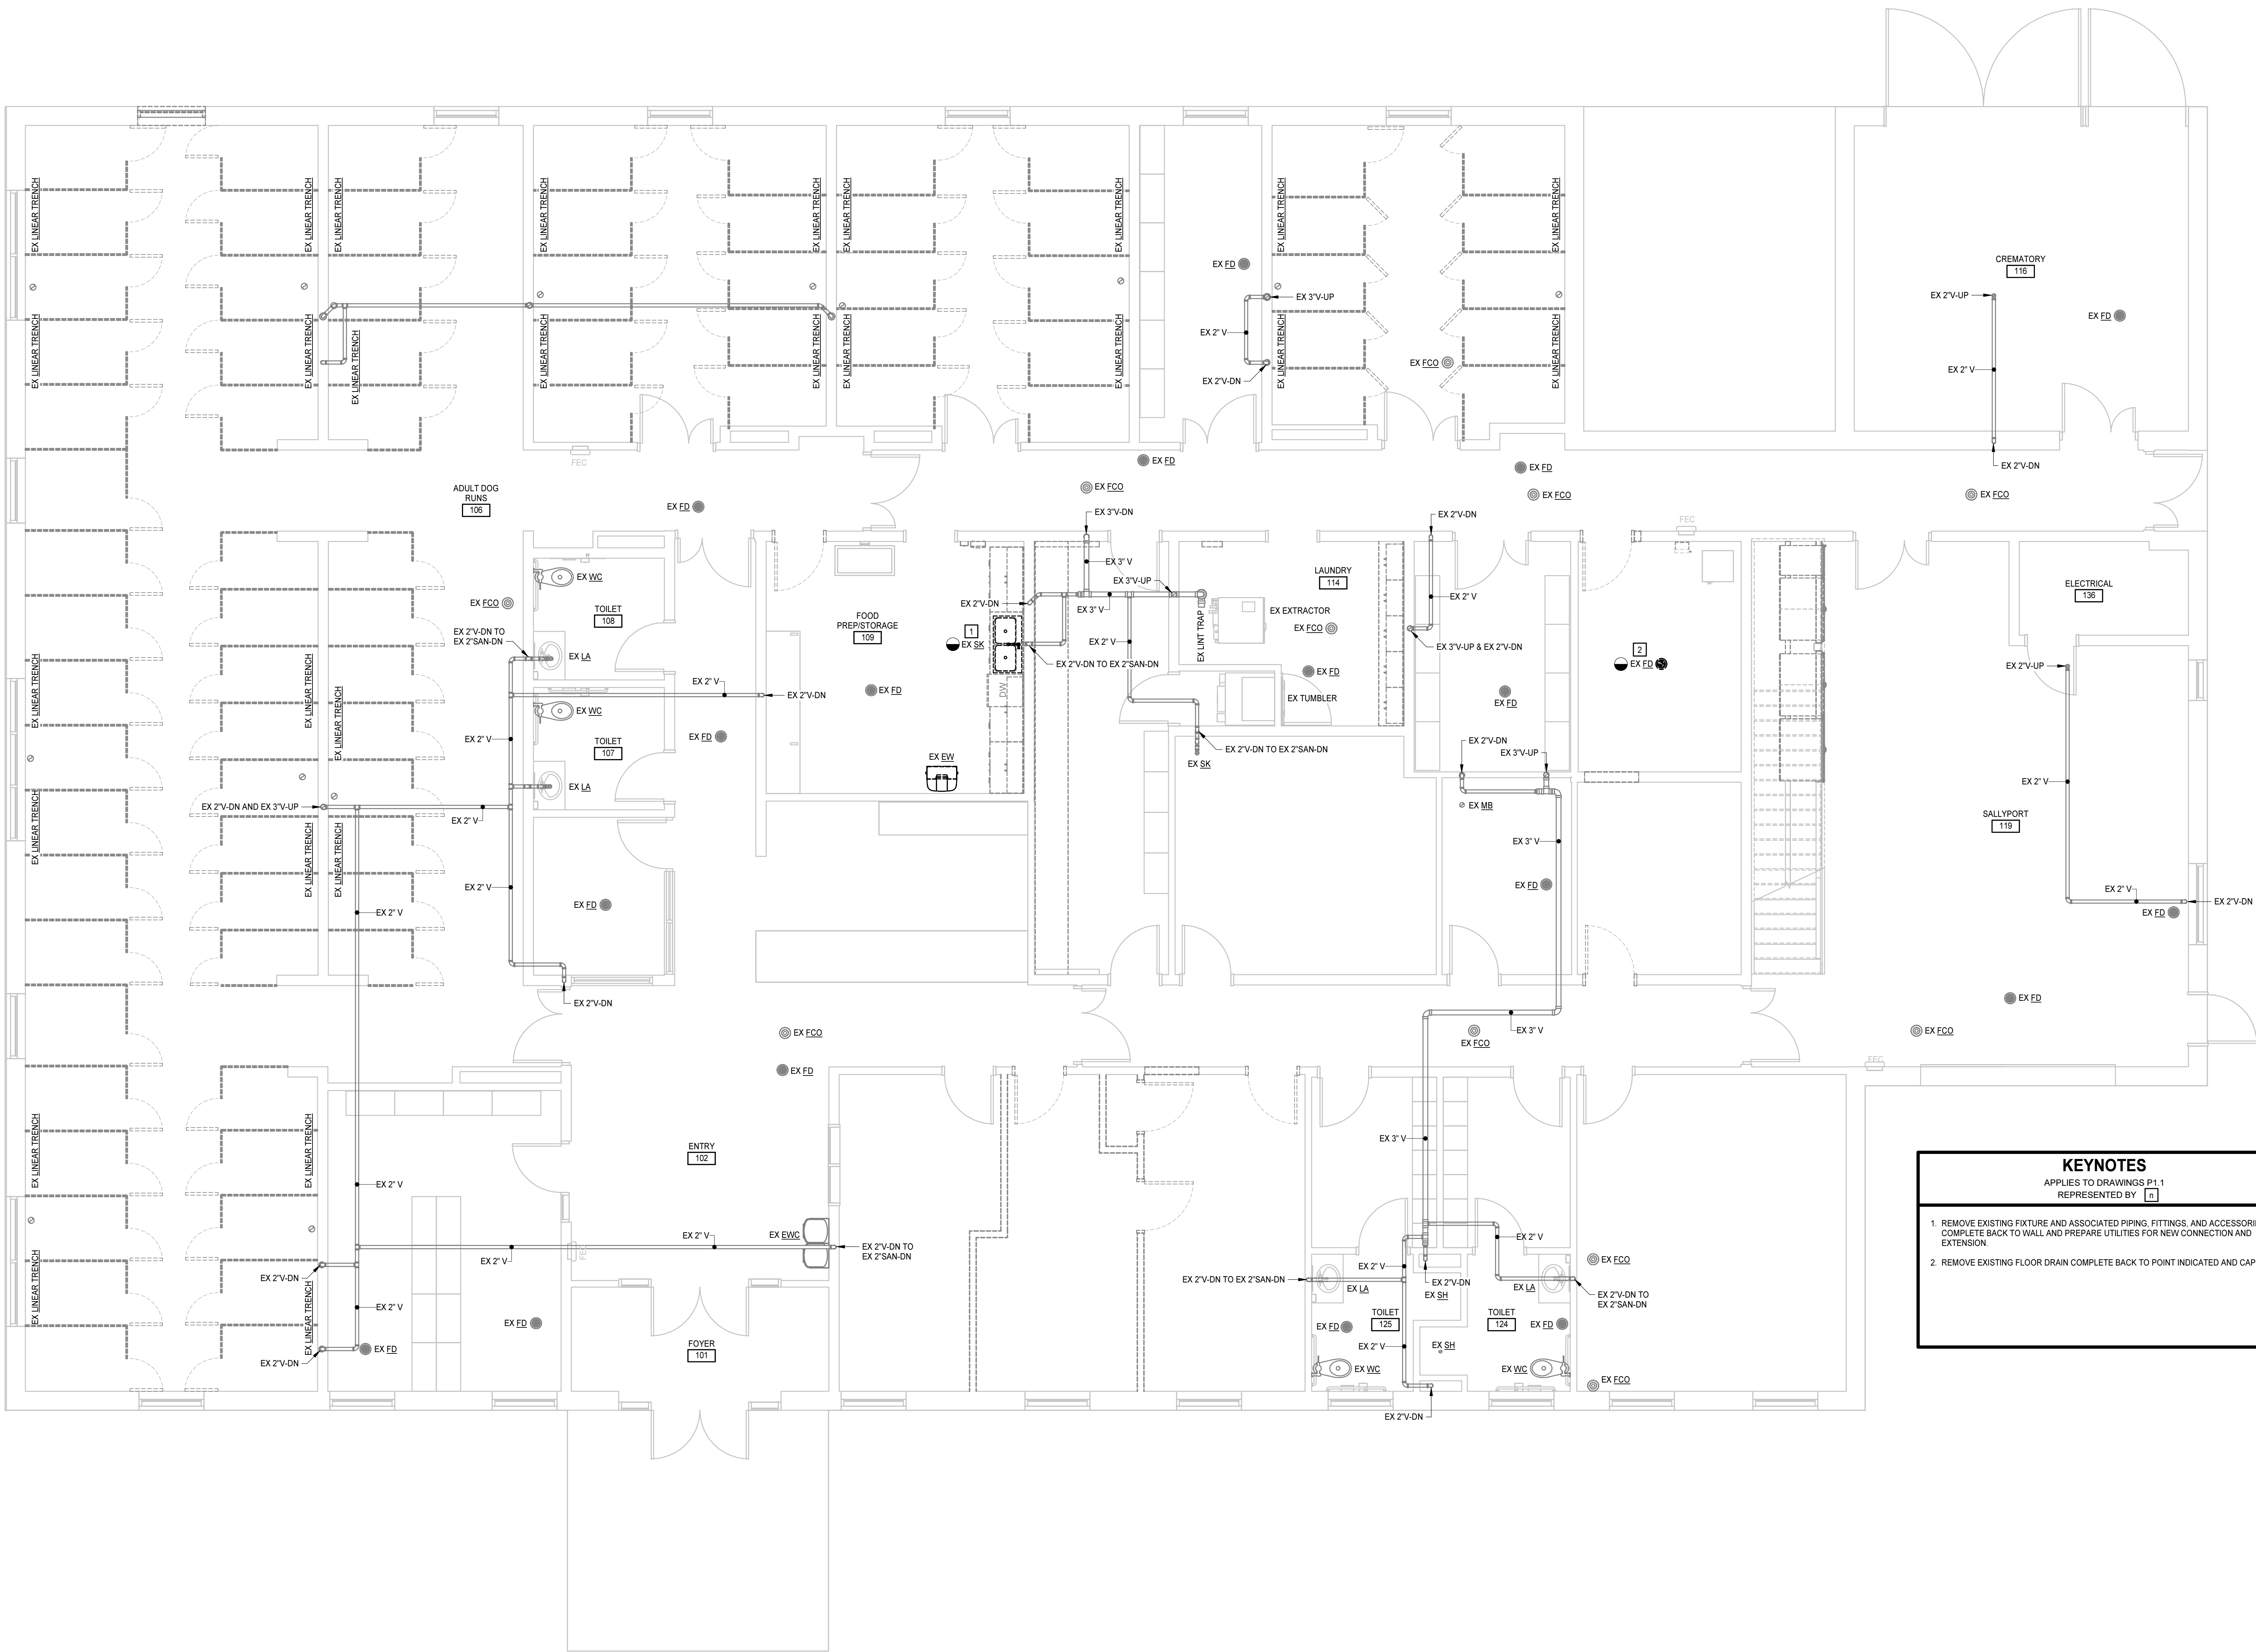

KEYNOTES


APPLIES TO DRAWINGS P1.1
REPRESENTED BY [N]

1. REMOVE EXISTING FIXTURE AND ASSOCIATED PIPING, FITTINGS, AND ACCESSORIES COMPLETE BACK TO WALL AND PREPARE UTILITIES FOR NEW CONNECTION AND EXTENSION.
2. REMOVE EXISTING FLOOR DRAIN COMPLETE BACK TO POINT INDICATED AND CAP.

HENRICO COUNTY ANIMAL SHELTER RENOVATION

10421 WOODMAN ROAD, GLEN ALLEN, VA 23060
HENRICO COUNTY


PROJECT NO.	615225
DATE:	AUGUST 18, 2025
REVISIONS	
DATE	DESCRIPTION

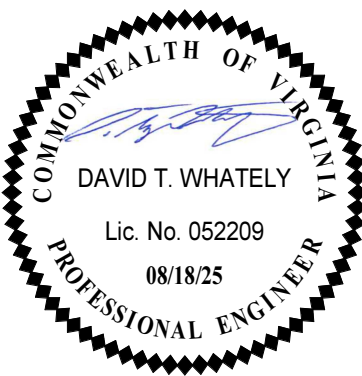

MOSELEYARCHITECTS


3200 NORFOLK STREET, RICHMOND, VA 23230
PHONE (804) 784-7555 FAX (804) 355-5690
MOSELEYARCHITECTS.COM

8/19/2025 12:05:20 PM

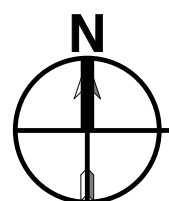

FIRST FLOOR PLAN - DEMOLITION - DOMESTIC

1/4" = 1'-0"

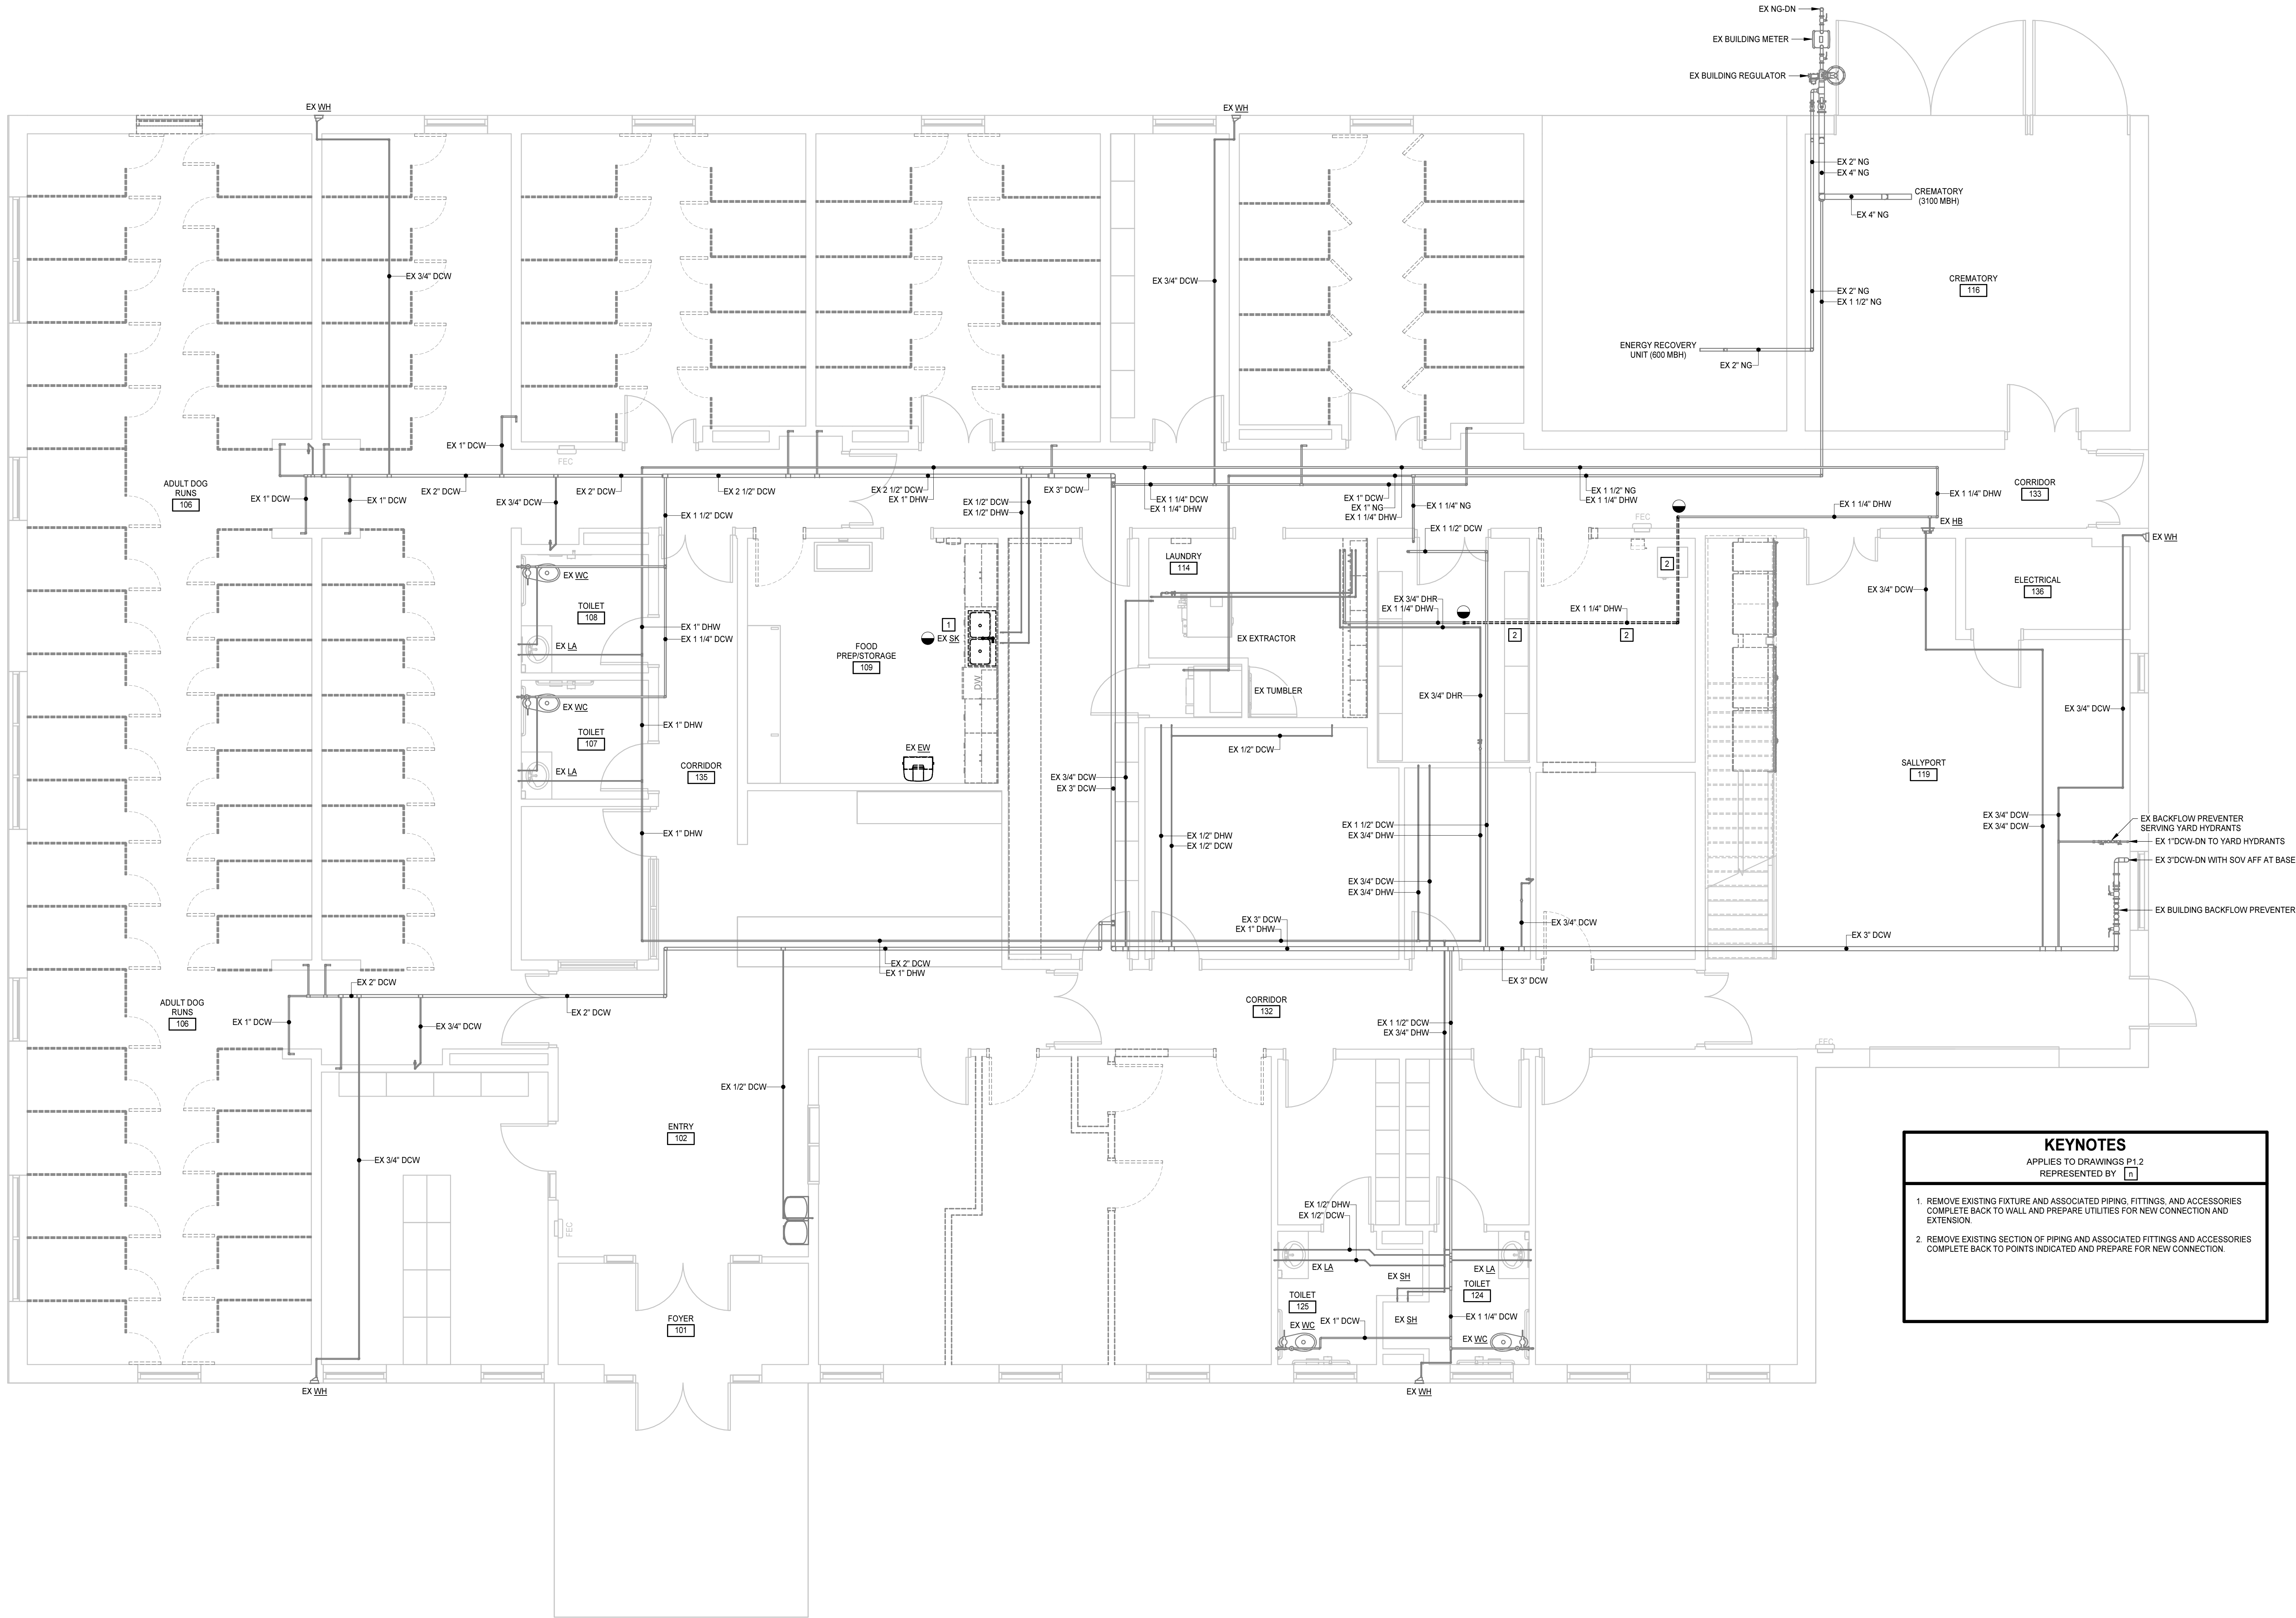

KEYNOTES

APPLIES TO DRAWINGS P1.2
REPRESENTED BY [N]

1. REMOVE EXISTING FIXTURE AND ASSOCIATED PIPING, FITTINGS, AND ACCESSORIES COMPLETE BACK TO WALL AND PREPARE UTILITIES FOR NEW CONNECTION AND EXTENSION.
2. REMOVE EXISTING SECTION OF PIPING AND ASSOCIATED FITTINGS AND ACCESSORIES COMPLETE BACK TO POINTS INDICATED AND PREPARE FOR NEW CONNECTION.

PROJECT NO:	615225
DATE:	AUGUST 18, 2025
REVISIONS	
DATE	DESCRIPTION


FIRST FLOOR PLAN -
DEMOLITION -
DOMESTIC

P1.2

HENRICO COUNTY ANIMAL SHELTER RENOVATION



10421 WOODMAN ROAD, GLEN ALLEN, VA 23060

HENRICO COUNTY

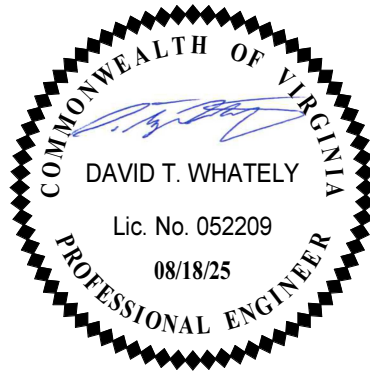



MOSELEYARCHITECTS

5200 NORFOLK STREET, RICHMOND, VA 23230
PHONE (804) 784-7555 FAX (804) 355-5690
MOSELEYARCHITECTS.COM

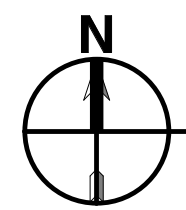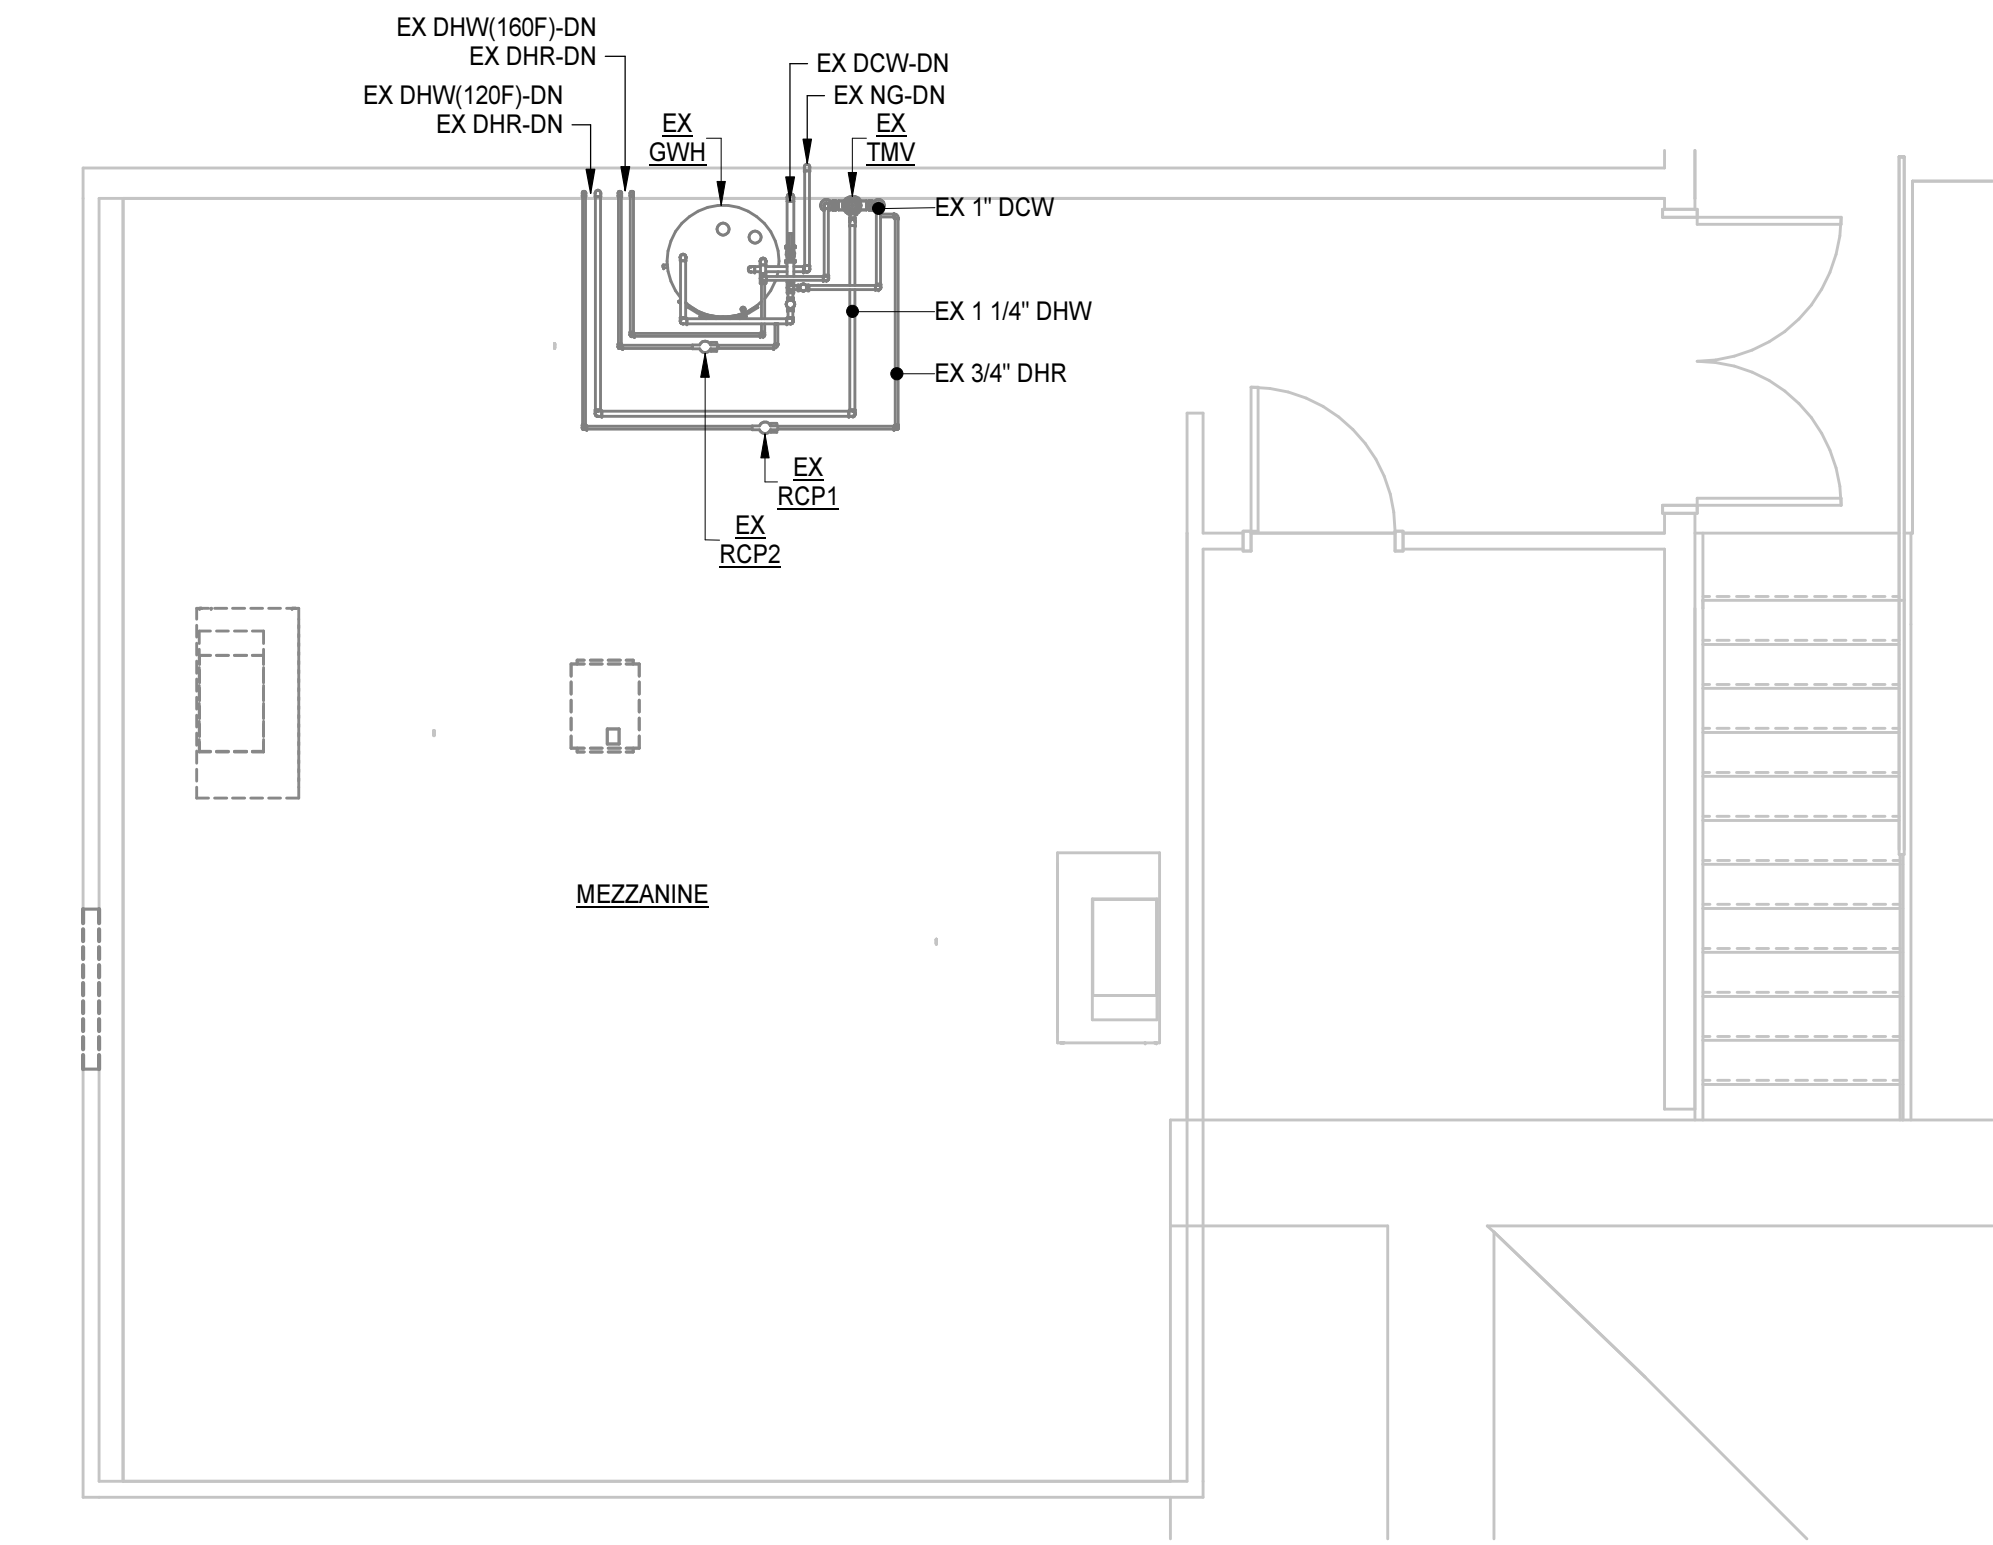

MEZZANINE PLAN - DEMOLITION - DOMESTIC

1/4" = 1'-0"

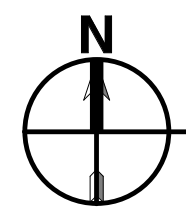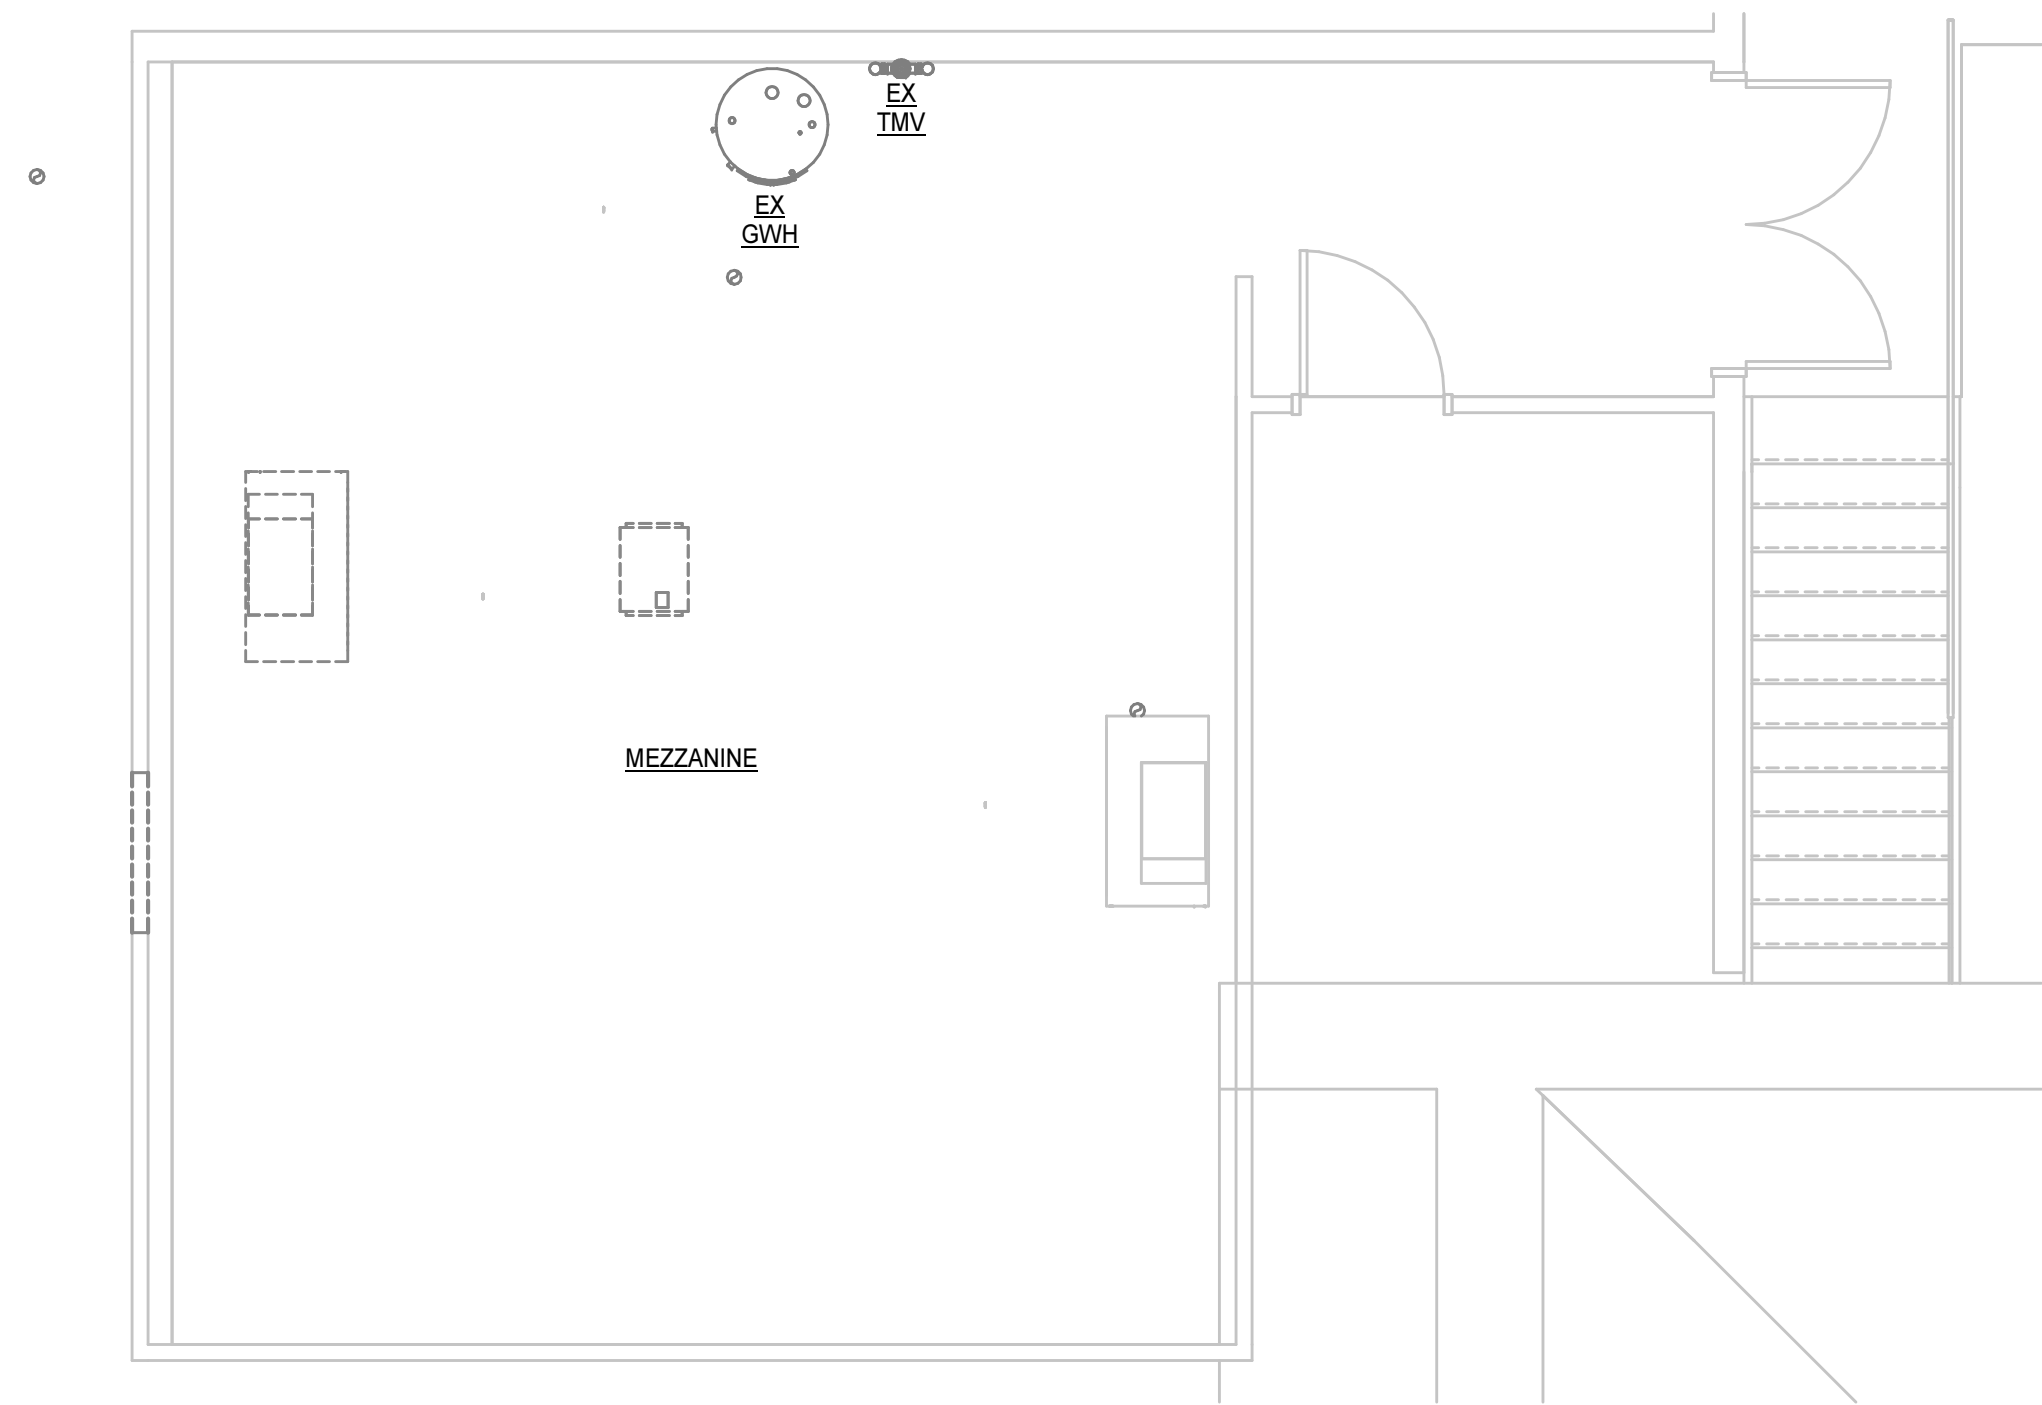

MEZZANINE PLAN - DEMOLITION - SANITARY


1/4" = 1'-0"




1/4" = 1'-0"

8/19/2025 12:05:22 PM

 **FOUNDATION PLAN - PLUMBING**
1/4" = 1'-0"

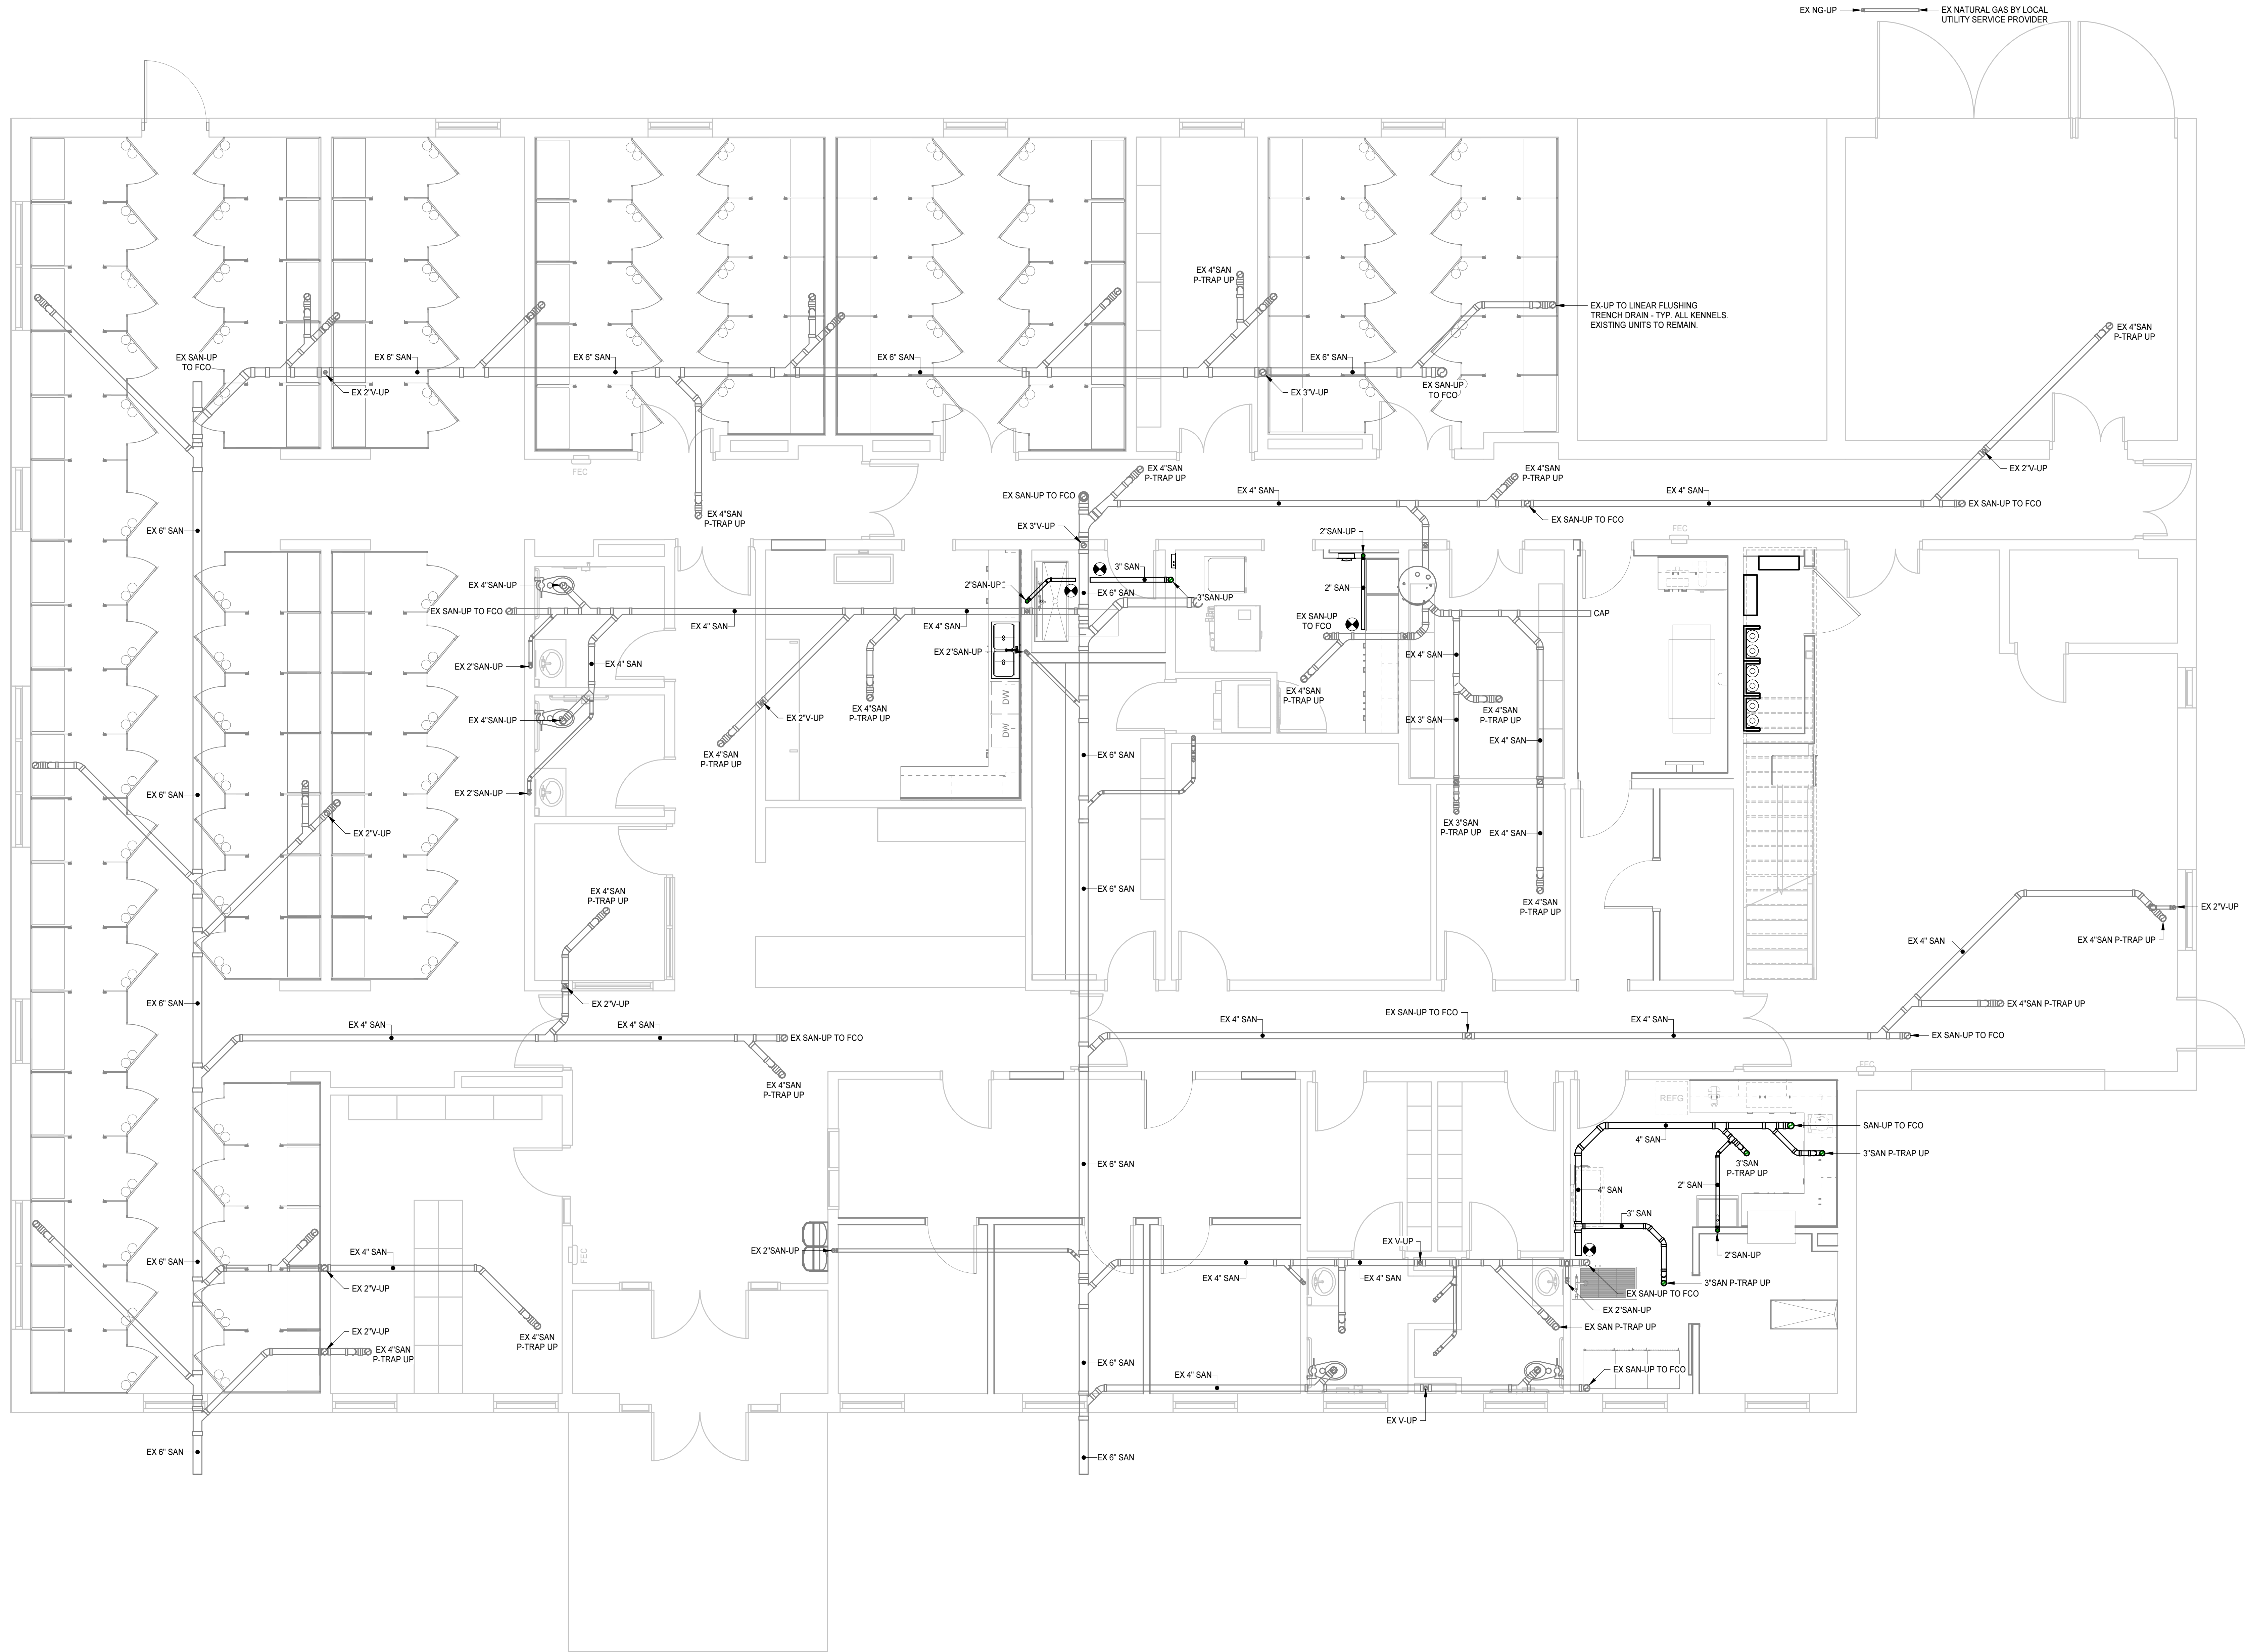

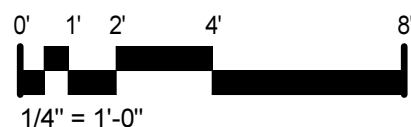
1/4" = 1'-0"


PROJECT NO: 615225
DATE: AUGUST 18, 2025

REVISIONS	
DATE	DESCRIPTION

**FOUNDATION PLAN -
PLUMBING**

HENRICO COUNTY ANIMAL SHELTER RENOVATION


10421 WOODMAN ROAD, GLEN ALLEN, VA 23060
HENRICO COUNTY

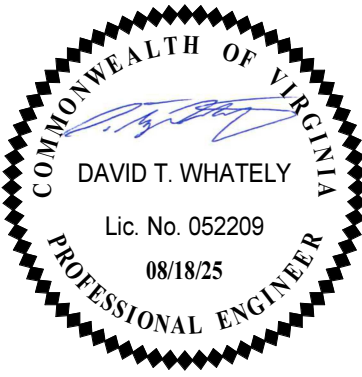

MOSELEYARCHITECTS

5200 NORFOLK STREET, RICHMOND, VA 23230
PHONE (804) 784-7555 FAX (804) 355-5690
MOSELEYARCHITECTS.COM

P2.0

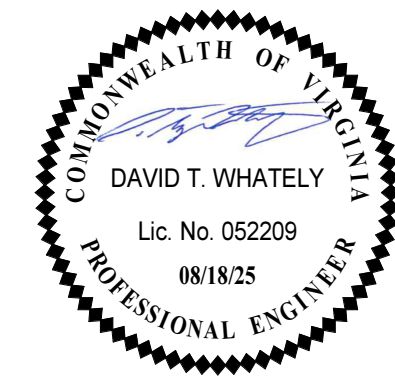


HENRICO COUNTY ANIMAL SHELTER RENOVATION

10421 WOODMAN ROAD, GLEN ALLEN, VA 23060
HENRICO COUNTY


PROJECT NO: 615225	
DATE: AUGUST 18, 2025	
REVISIONS	
DATE	DESCRIPTION

**FIRST FLOOR PLAN -
SANITARY**

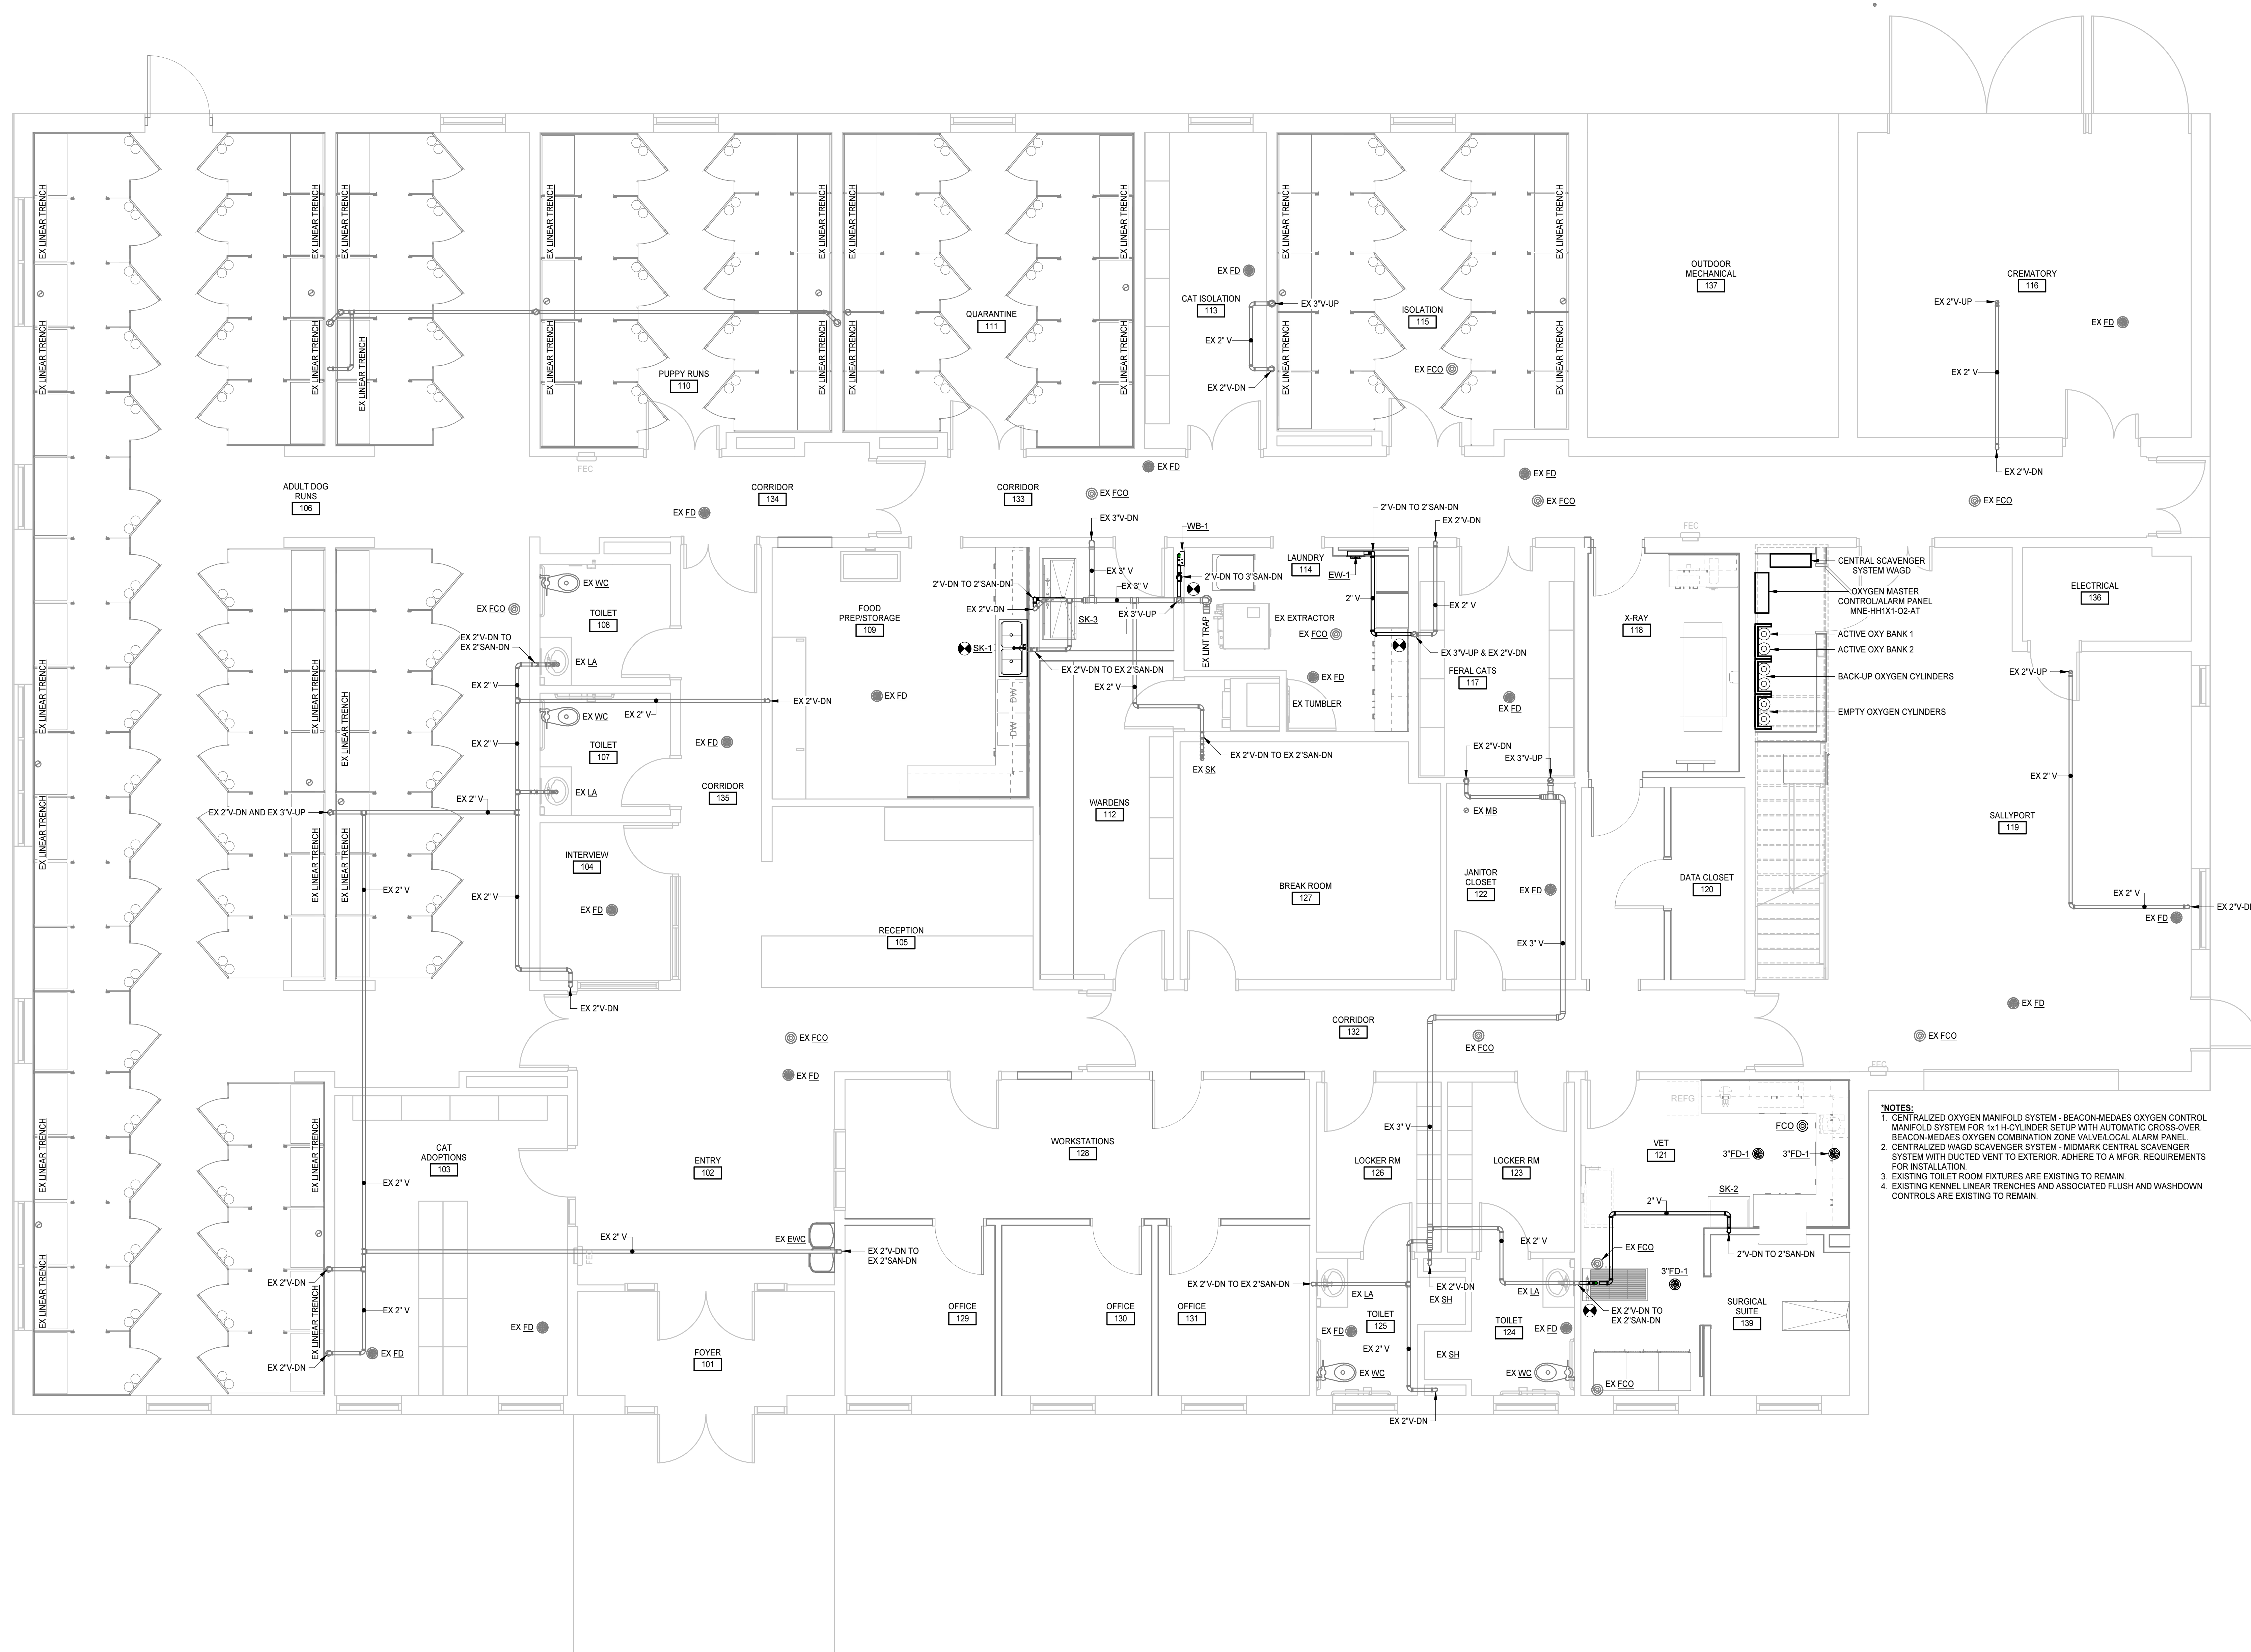

***NOTES:**


1. CENTRALIZED OXYGEN MANIFOLD SYSTEM - BEACON-MEDAES OXYGEN CONTROL MANIFOLD SYSTEM FOR 1x1 H-CYLINDER SETUP WITH AUTOMATIC CROSS-OVER. BEACON-MEDAES OXYGEN COMBINATION ZONE VALVE/LOCAL ALARM PANEL.
2. CENTRALIZED WAGD SCAVENGER SYSTEM - MIDMARK CENTRAL SCAVENGER SYSTEM WITH DUCTED VENT TO EXTERIOR. ADHERE TO A MFR. REQUIREMENTS FOR INSTALLATION.
3. EXISTING TOILET ROOM FIXTURES ARE EXISTING TO REMAIN.
4. EXISTING KENNEL LINEAR TRENCHES AND ASSOCIATED FLUSH AND WASHDOWN CONTROLS ARE EXISTING TO REMAIN.

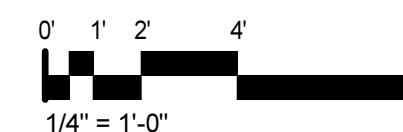




FIRST FLOOR PLAN - DOMESTIC

1/4" = 1'-0"

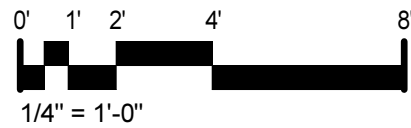

1/4" = 1'-0"

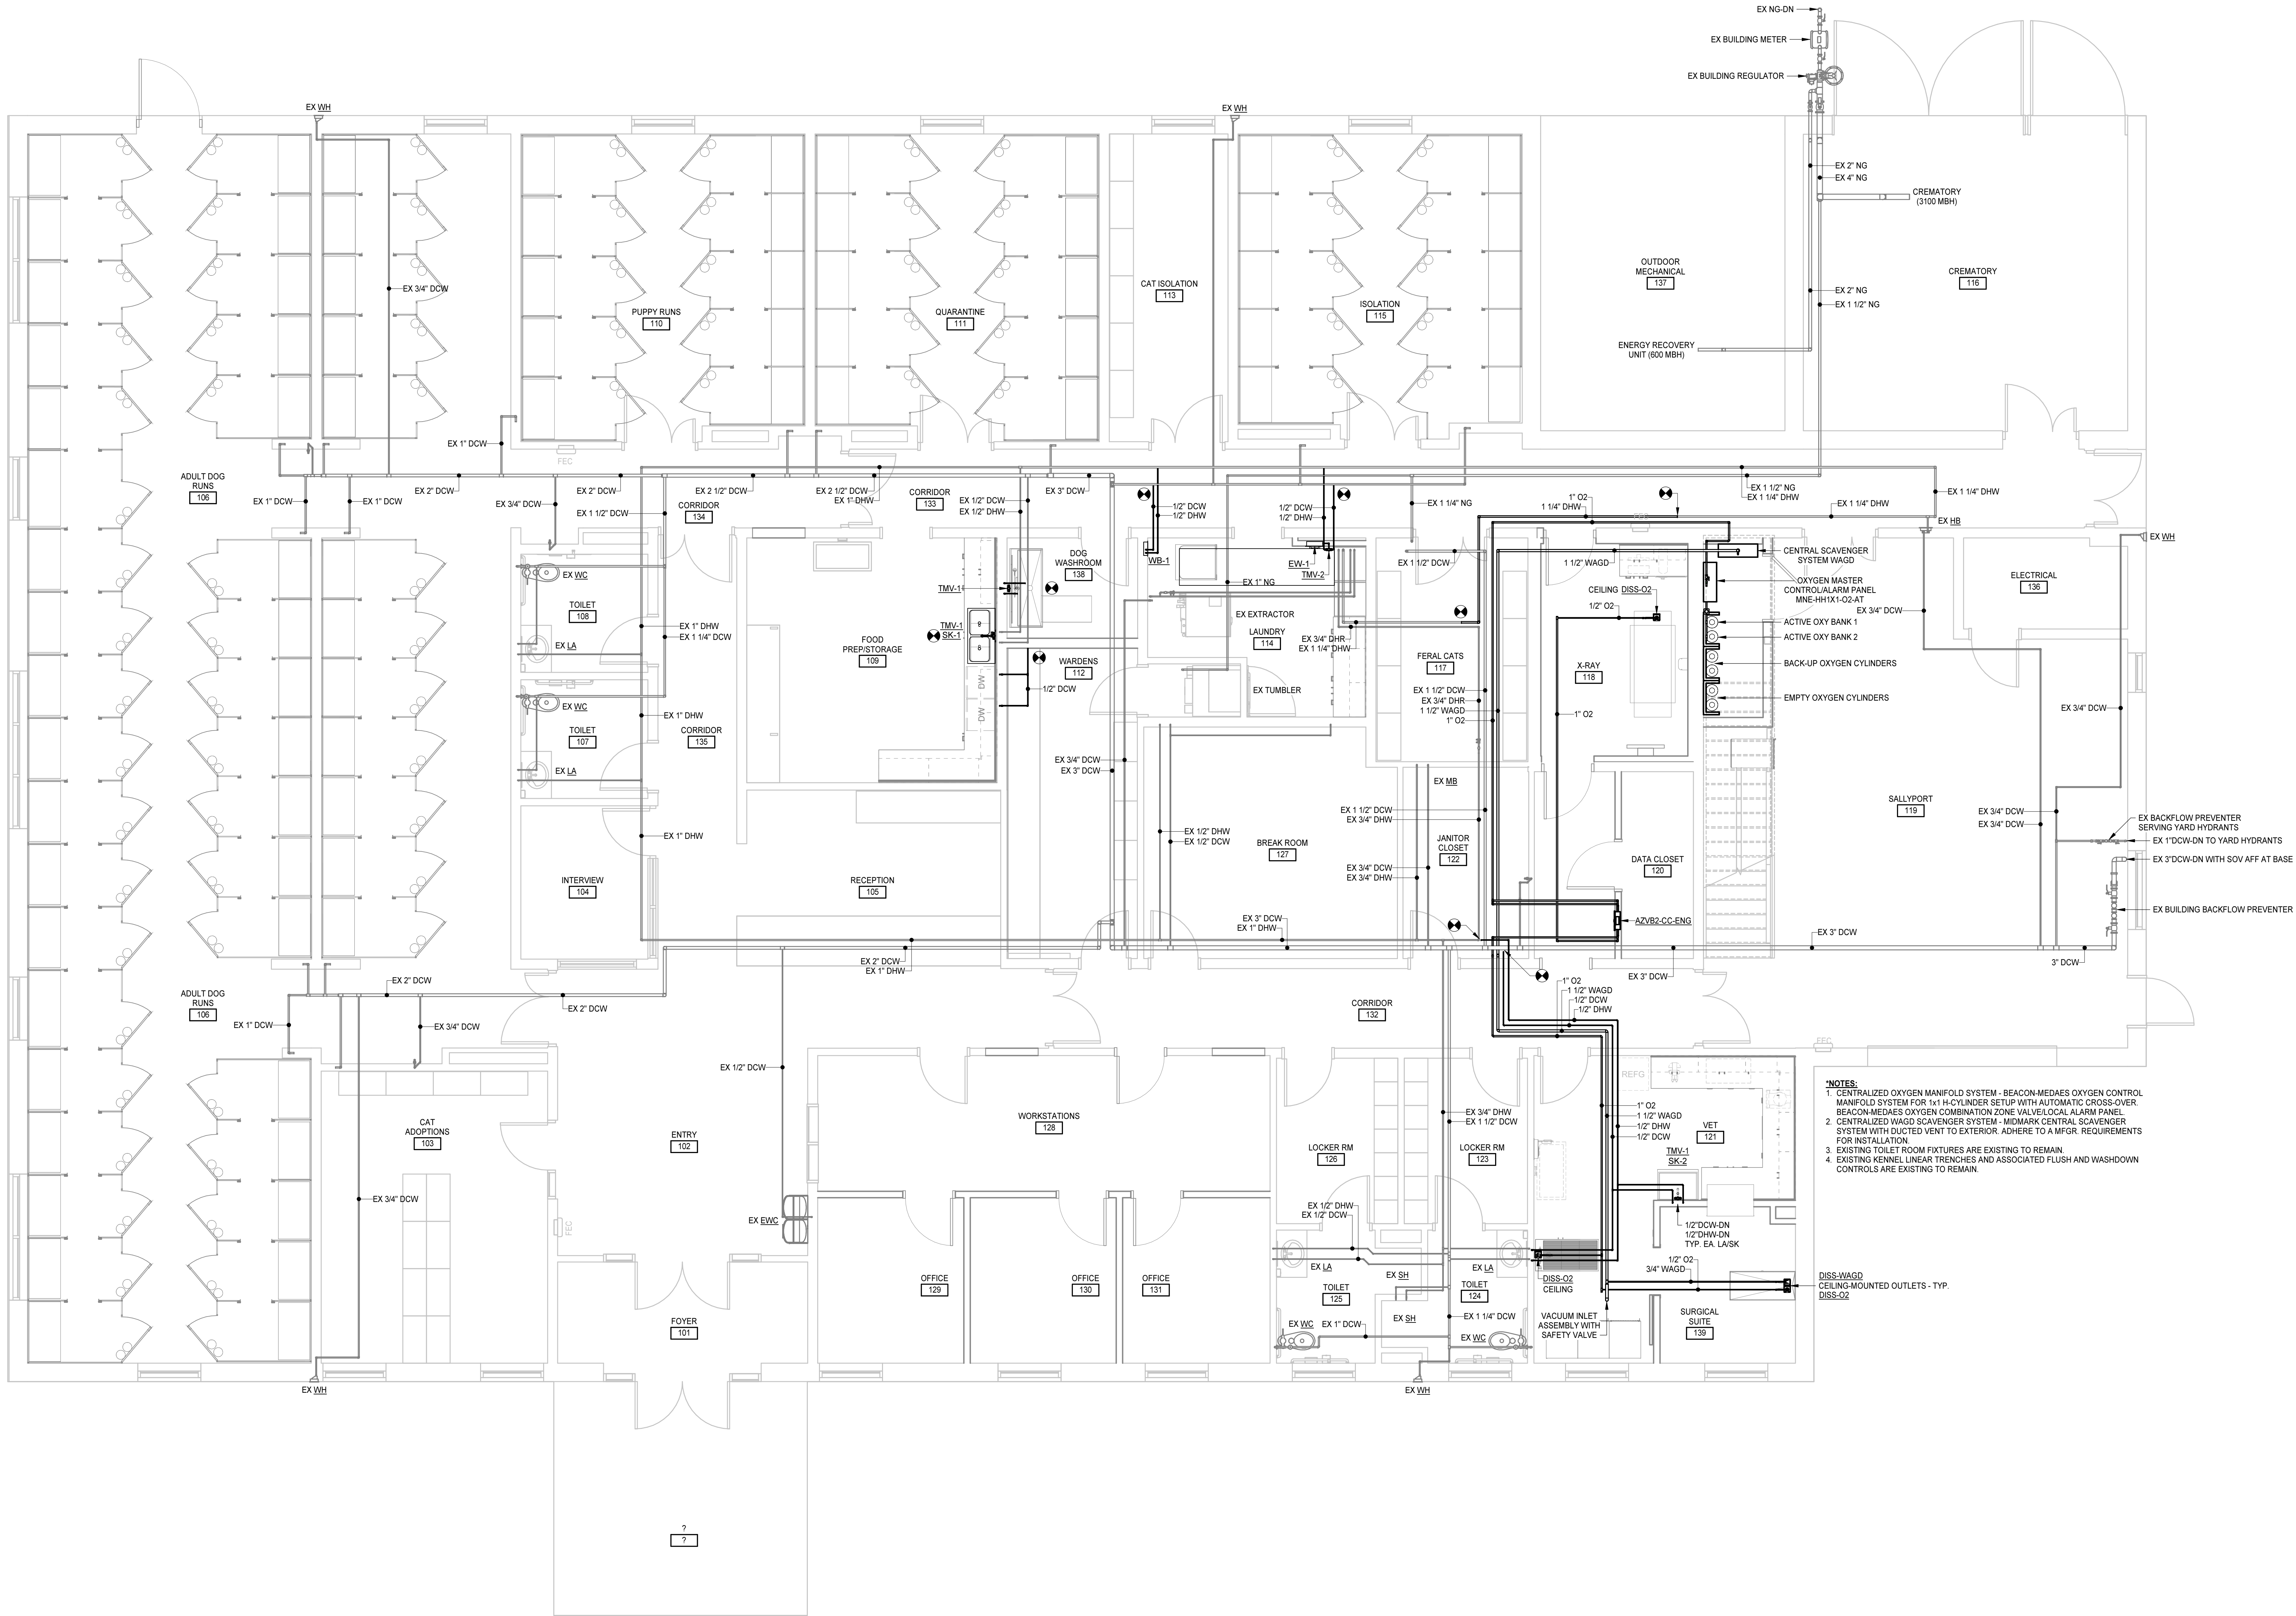

- NOTES:**
- CENTRALIZED OXYGEN MANIFOLD SYSTEM - BEACON-MEDAE'S OXYGEN CONTROL MANIFOLD SYSTEM FOR 1x1 H-CYLINDER SETUP WITH AUTOMATIC CROSS-OVER. BEACON-MEDAE'S OXYGEN COMBINATION ZONE VALVE/LOCAL ALARM PANEL
 - CENTRALIZED WAGD SCAVENGER SYSTEM - MIDMARK CENTRAL SCAVENGER SYSTEM WITH DUCTED VENT TO EXTERIOR. ADHERE TO A MFG. REQUIREMENTS FOR INSTALLATION
 - EXISTING TOILET ROOM FIXTURES ARE EXISTING TO REMAIN.
 - EXISTING KENNEL LINEAR TRENCHES AND ASSOCIATED FLUSH AND WASHDOWN CONTROLS ARE EXISTING TO REMAIN.

DISS-WAGD
CEILING-MOUNTED OUTLETS - TYP.
DISS-02


HENRICO COUNTY ANIMAL SHELTER RENOVATION

10421 WOODMAN ROAD, GLEN ALLEN, VA 23060

HENRICO COUNTY


PROJECT NO:	615225
DATE:	AUGUST 18, 2025
REVISIONS	
DATE	DESCRIPTION

FIRST FLOOR PLAN -
DOMESTIC

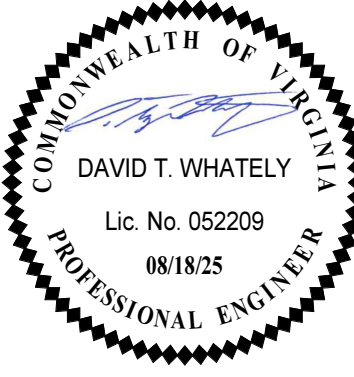



MOSELEYARCHITECTS

3200 NORFOLK STREET, RICHMOND, VA 23230
PHONE (804) 784-7555 FAX (804) 355-5690
MOSELEYARCHITECTS.COM

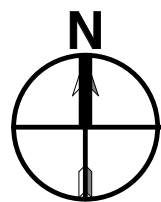


MEZZANINE PLAN - SANITARY

1/4" = 1'-0"

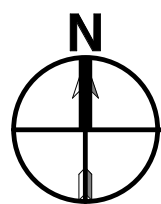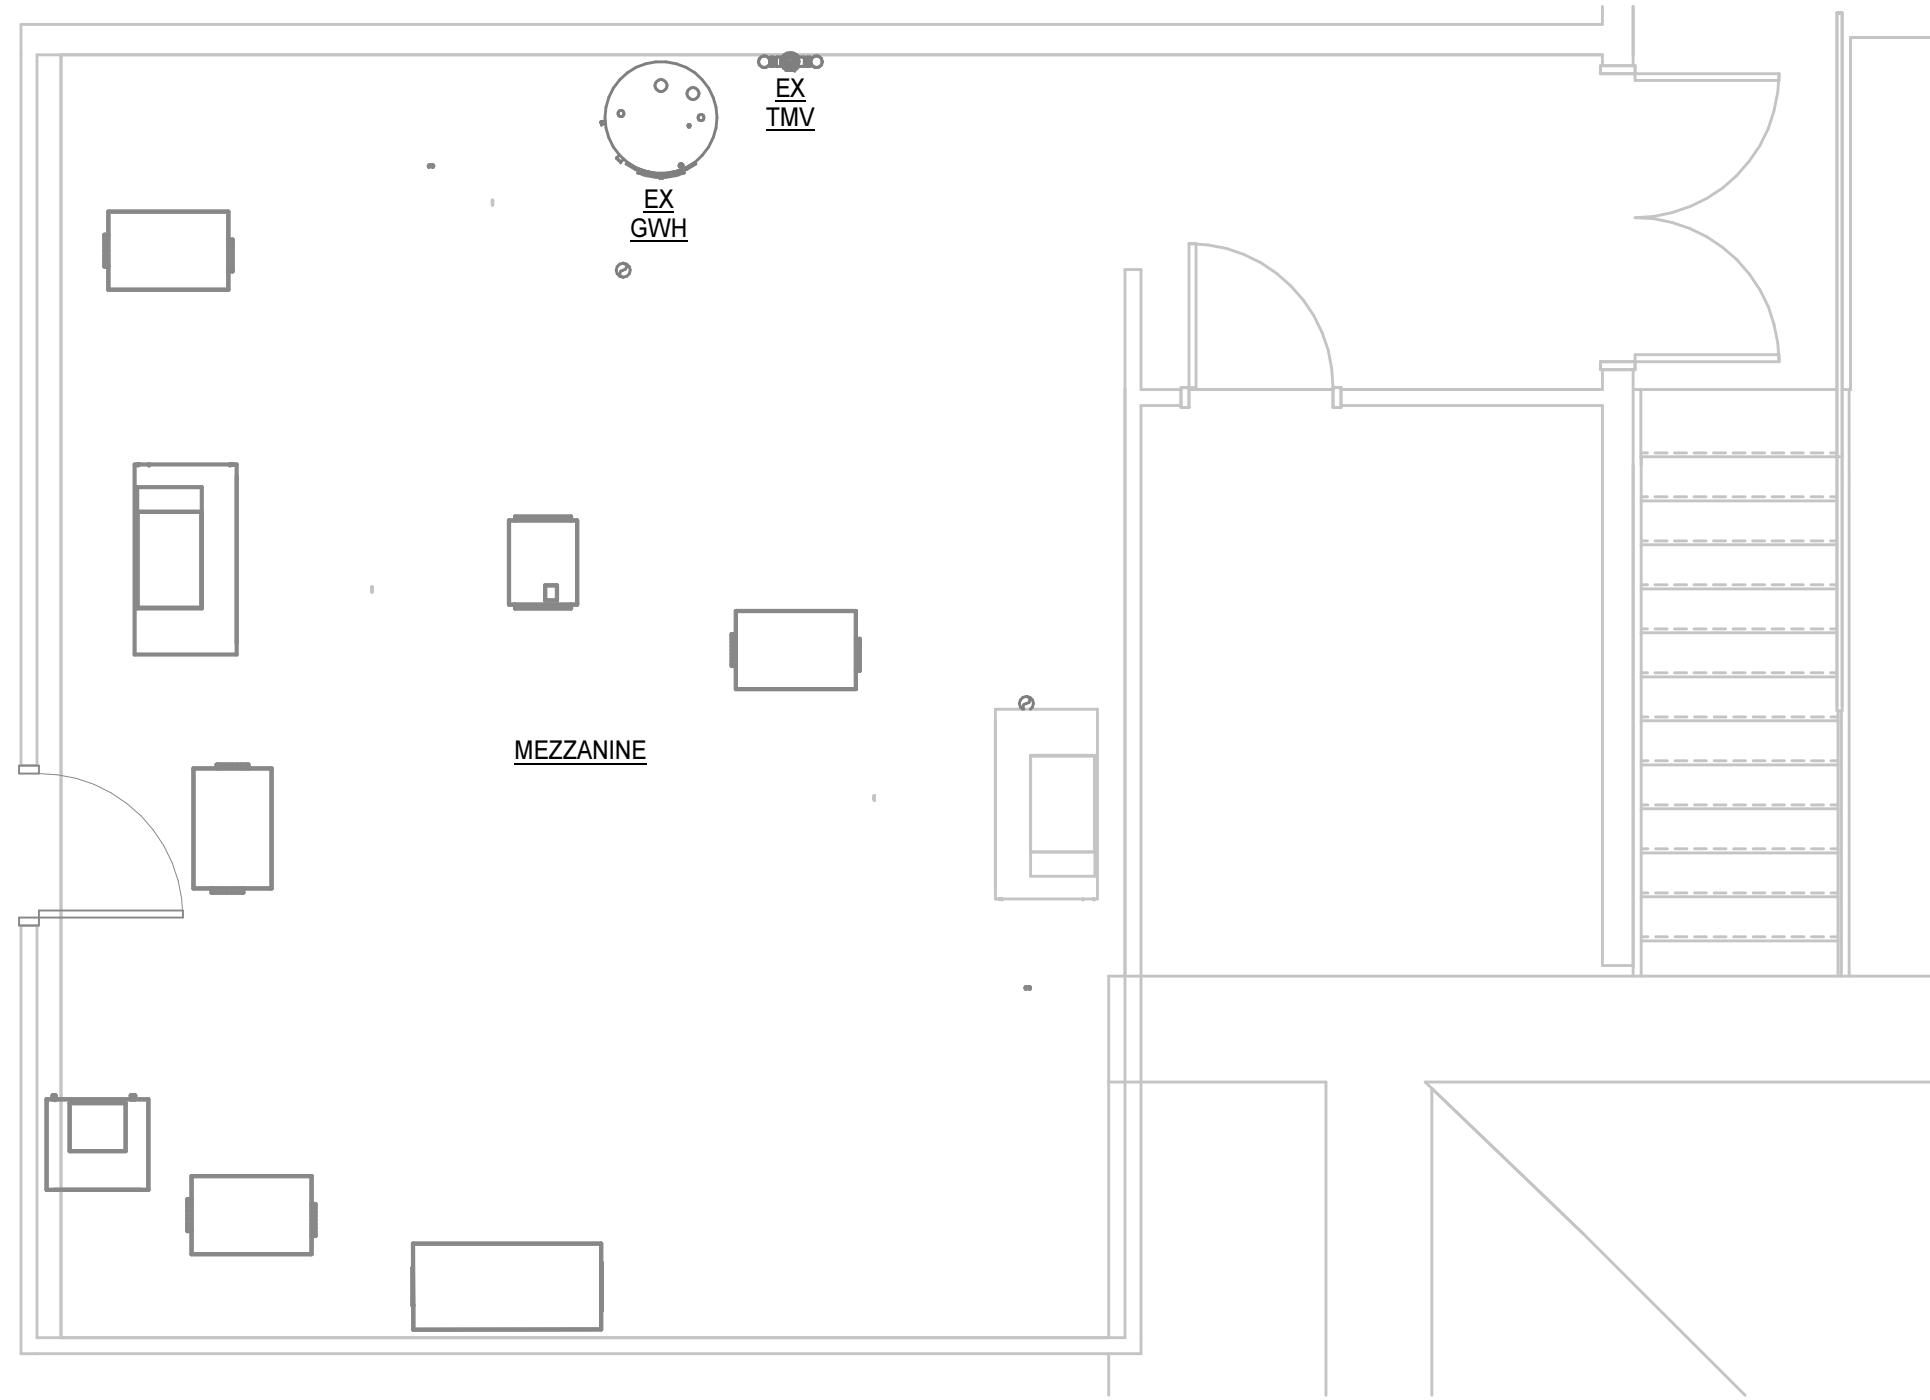


MEZZANINE PLAN - DOMESTIC


1/4" = 1'-0"

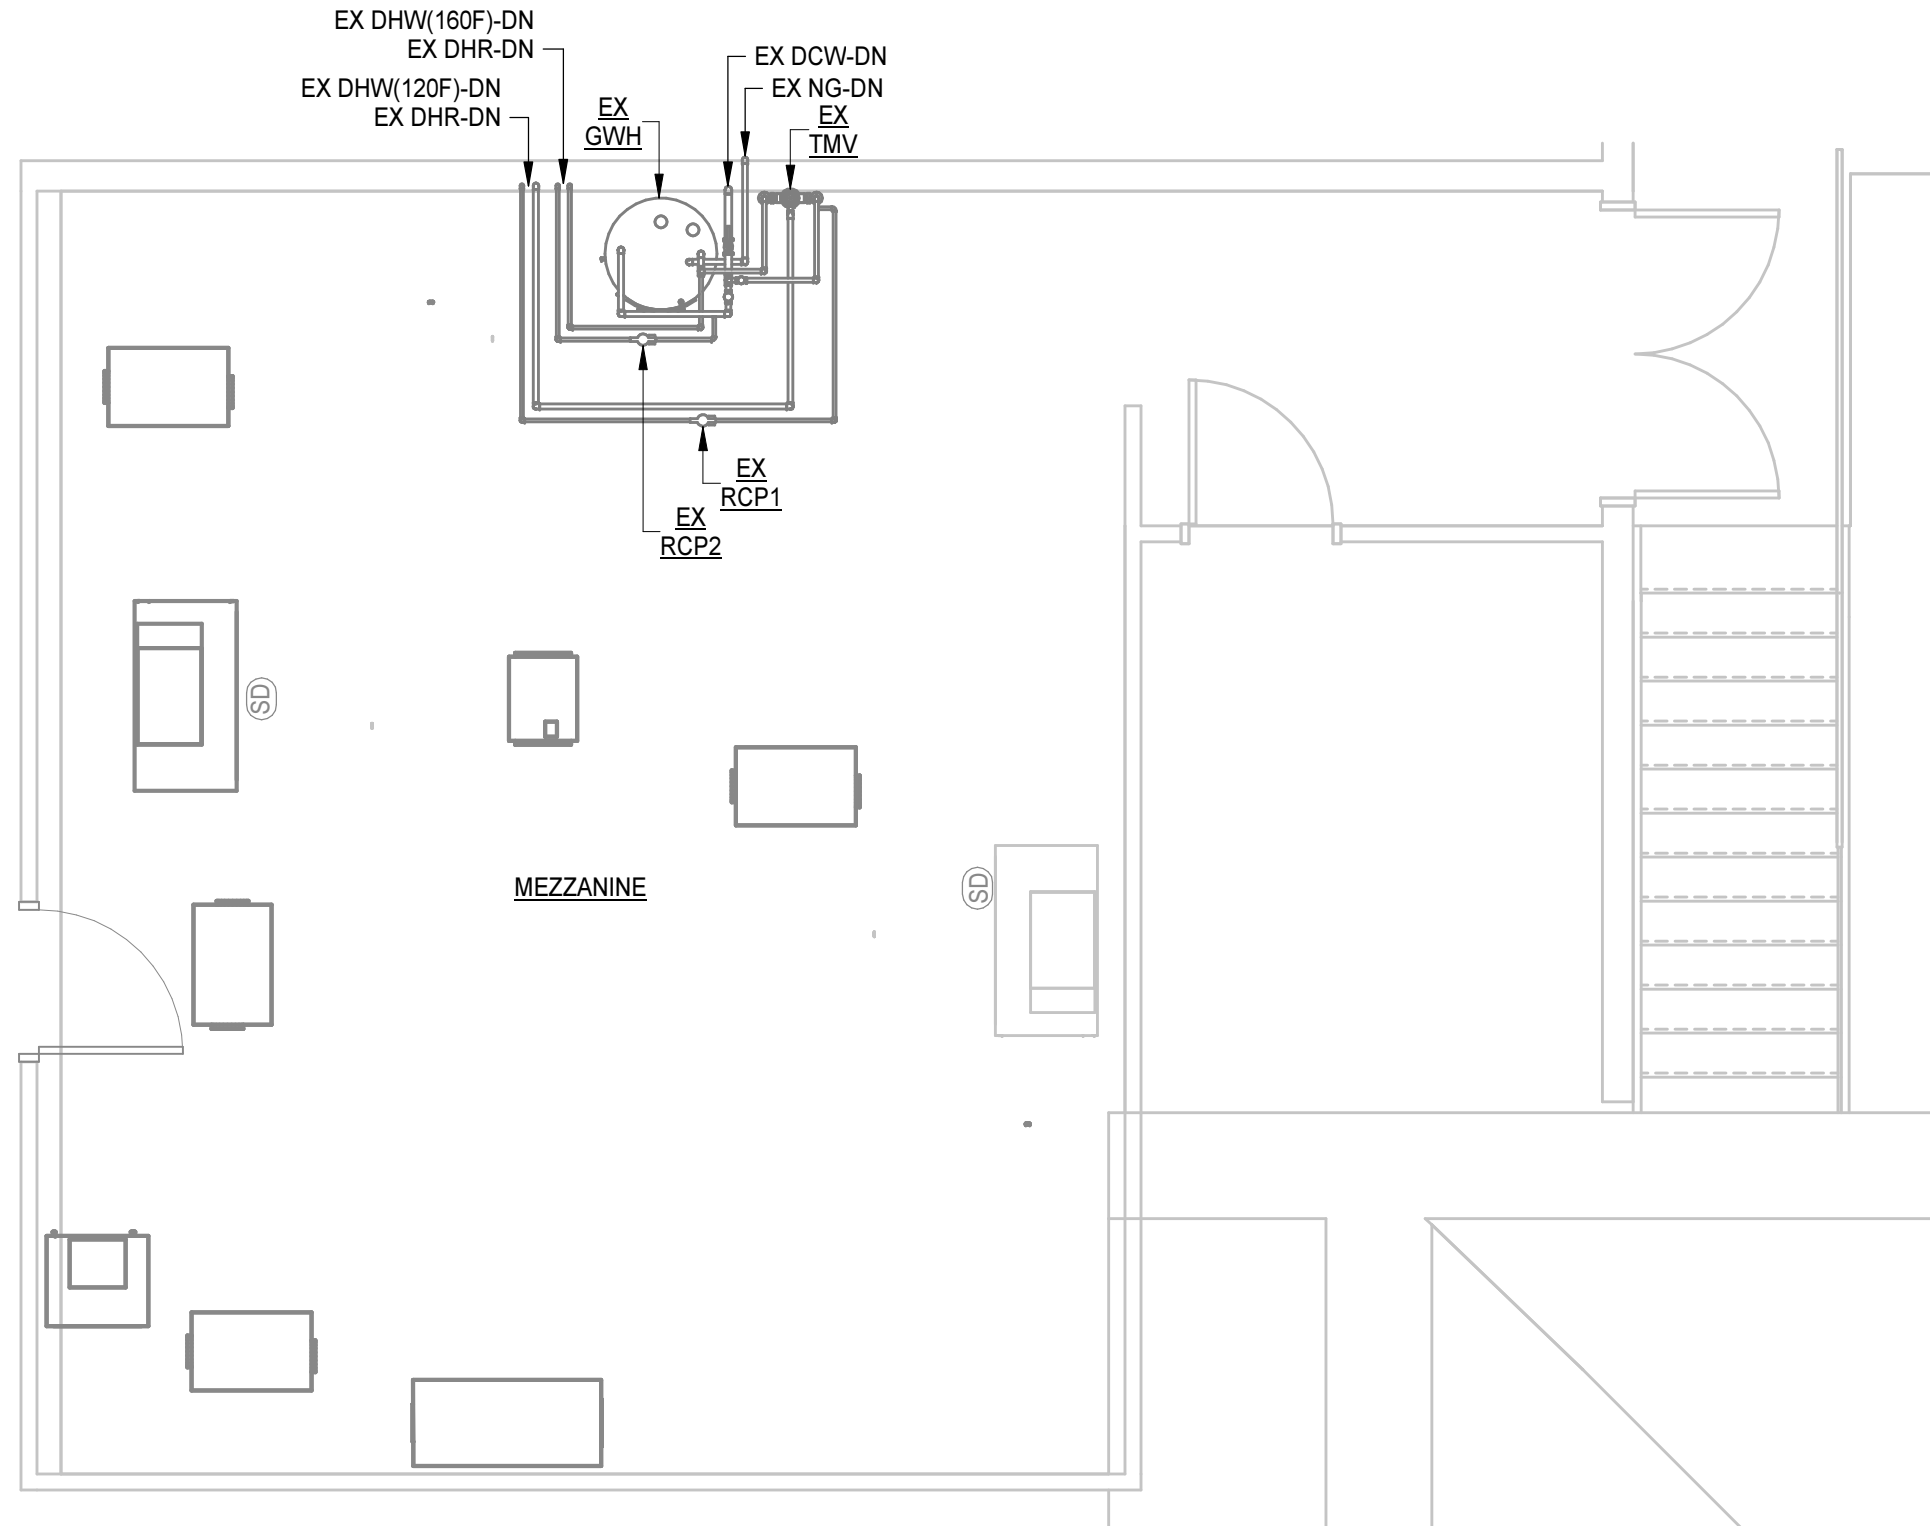

PROJECT NO:	615225
DATE:	AUGUST 18, 2025
REVISIONS	
DATE	DESCRIPTION


HENRICO COUNTY ANIMAL SHELTER RENOVATION
10421 WOODMAN ROAD, GLEN ALLEN, VA 23060
HENRICO COUNTY

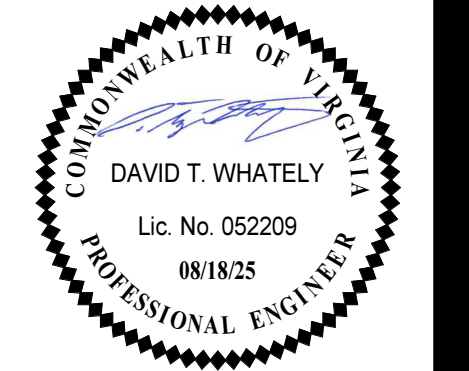

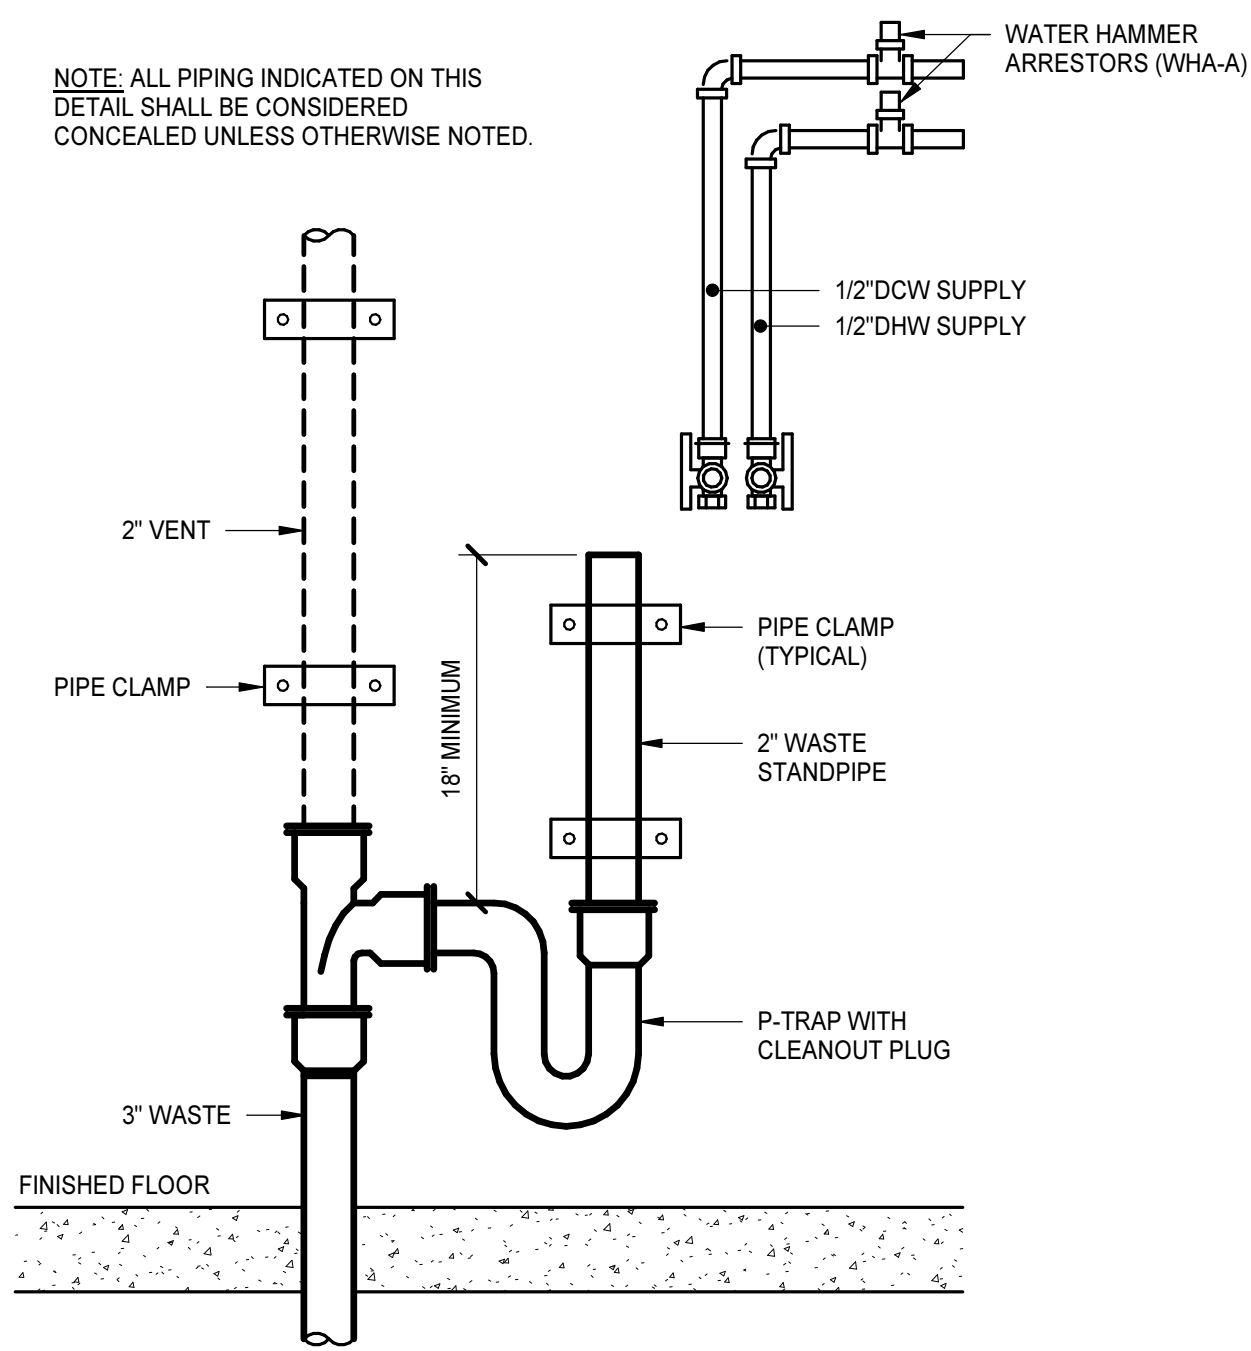


WASHING MACHINE STANDPIPE DRAIN DETAIL

NO SCALE

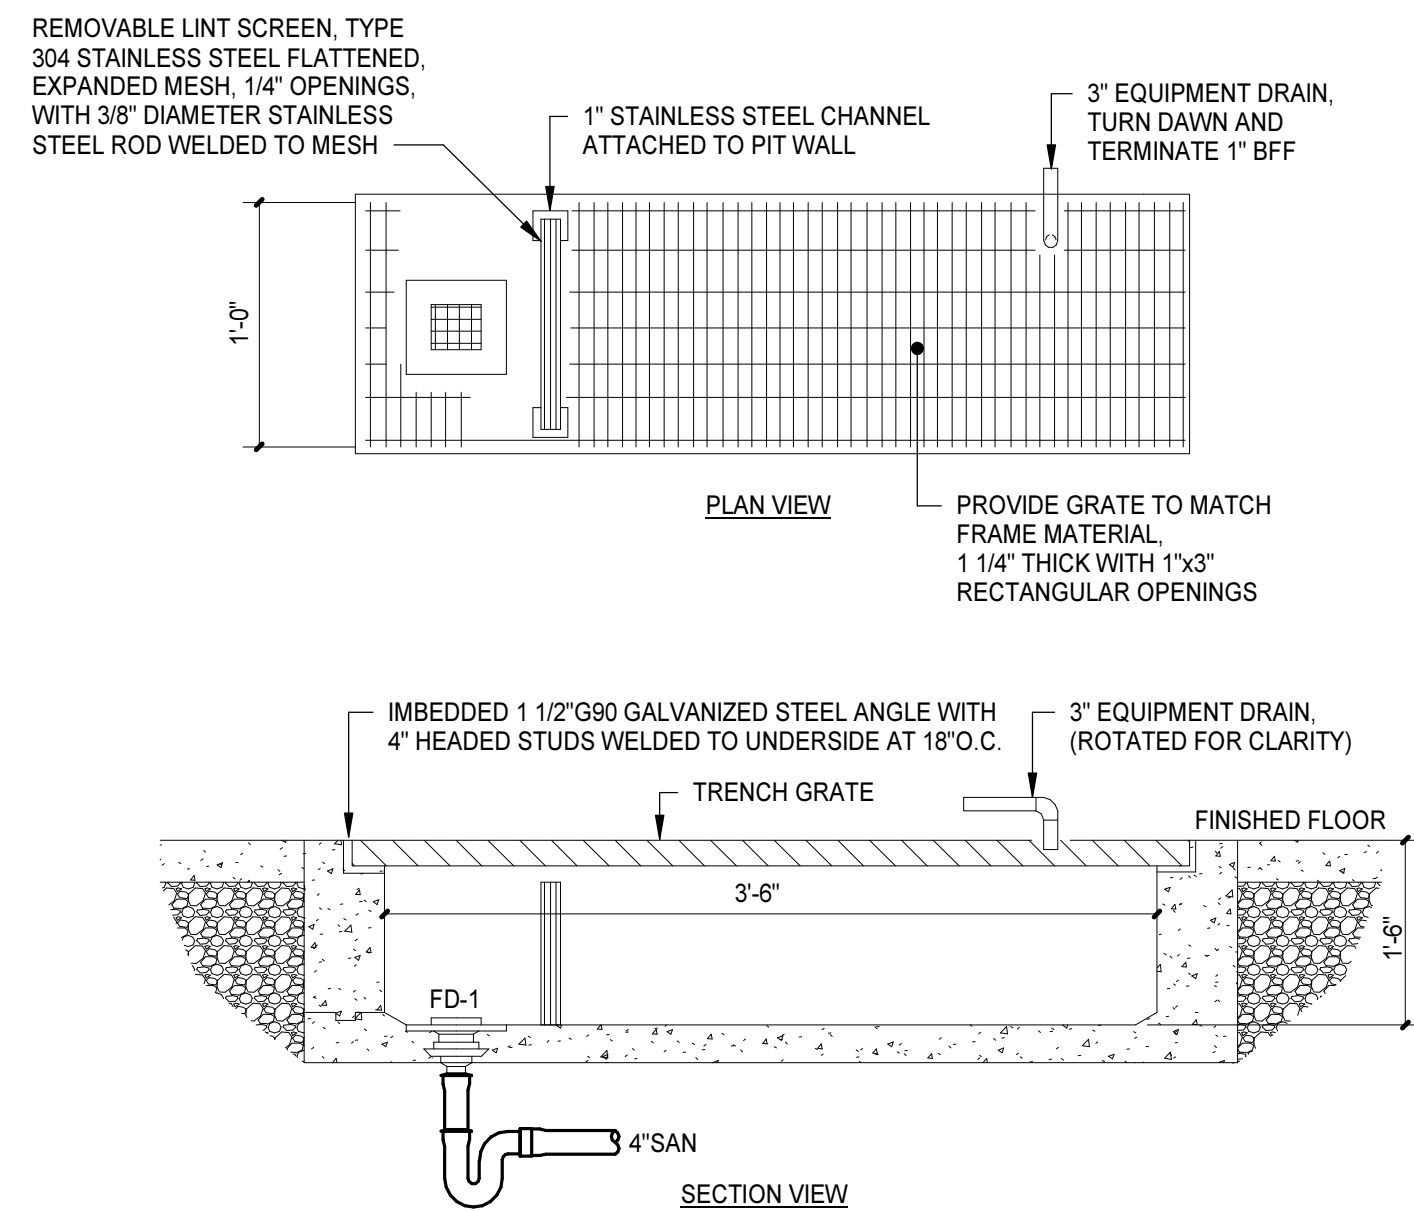

LAUNDRY EXTRACTOR TRENCH DRAIN DETAIL (TD-2)


NO SCALE

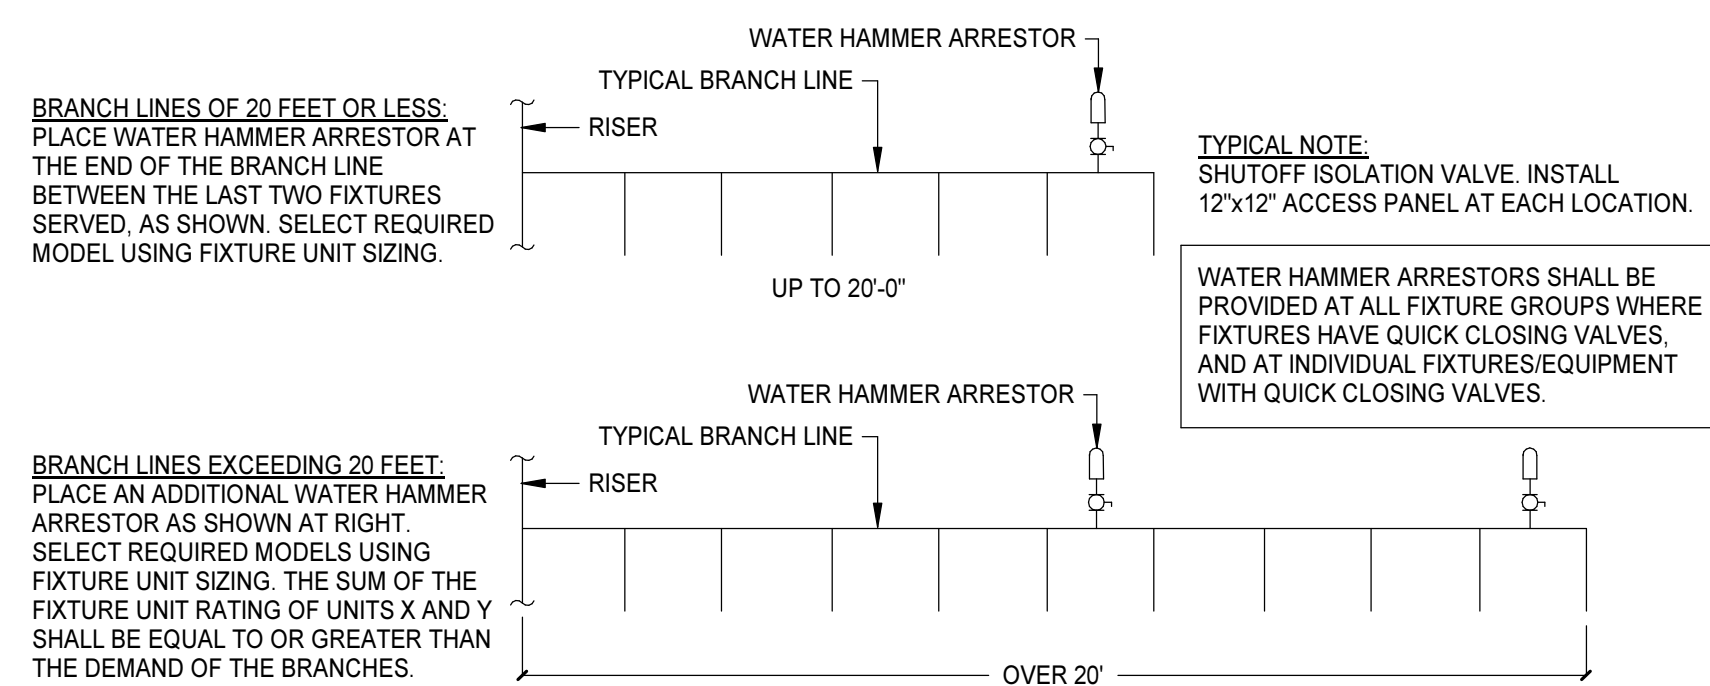

P.D.I. WATER HAMMER ARRESTORS							
LENGTH OF PIPE	NOMINAL PIPE DIAMETERS						
	1/2"	3/4"	1"	1-1/4"	1-1/2"	2"	
25'	A	A	B	C	D	E	
50'	A	B	C	D	E	F	
75'	B	C	D	AE	F	EF	
100'	C	D	E	F	CF	FF	
125'	C	D	F	AF	EF	EFF	
150'	D	E	F	DF	FF	FFF	

WHEN LONG RUNS OF PIPING ARE EMPLOYED TO SERVE REMOTE EQUIPMENT, WATER HAMMER ARRESTOR SHOULD BE LOCATED AS CLOSE AS POSSIBLE TO THE POINT OF QUICK CLOSURE OR HAMMER SOURCE.

THE SIZE AND QUANTITY OF WATER HAMMER ARRESTORS TO BE INSTALLED IN BRANCH LINES IS SHOWN IN TABLE. WHEN FLOR PRESSURE OF 65 PSIG TO 85 PSIG ARE USED, THE NEXT LARGER SIZE SHOULD BE SELECTED.

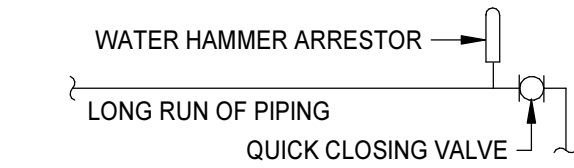

WATER HAMMER ARRESTOR CAPACITIES			
CONN. SIZE	PDI SIZE	FIXTURE UNIT CAPACITY	CUBIC INCH VOLUME
1/2"	A	1 TO 11	5
3/4"	B	12 TO 32	7
1"	C	33 TO 60	11
1"	D	61 TO 113	20
1"	E	114 TO 154	29
1"	F	155 TO 330	34


NOTE: MATCH TOTAL FIXTURE UNITS OF BRANCH LINE TO CORRECT SIZE OF WATER HAMMER ARRESTOR.

SHOCK ABSORBER SELECTION		
CODE	PDI SIZE	FIXTURE UNITS
SA-1	A	1-11
SA-2	B	12-32
SA-3	C	33-60
SA-4	D	61-113
SA-5	E	114-154
SA-6	F	155-330

SHOCK ABSORBER SELECTION TABLE


WATER HAMMER ARRESTOR INSTALLATION & SIZING DETAIL

NO SCALE

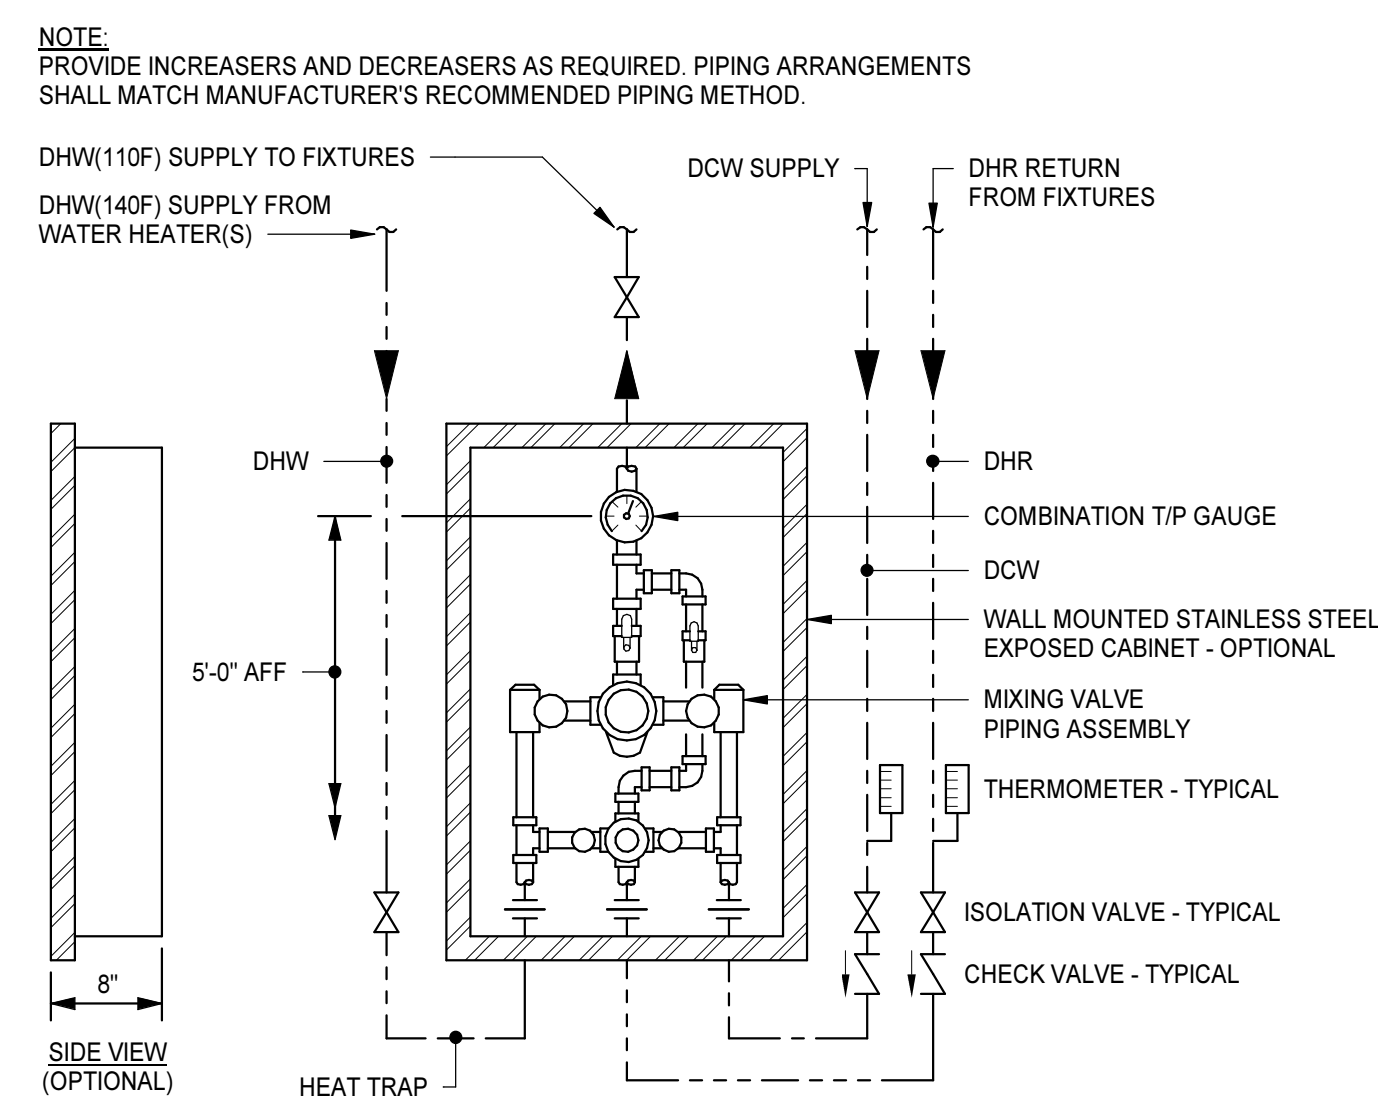


THERMOSTATIC MIXING VALVE DETAIL

NO SCALE

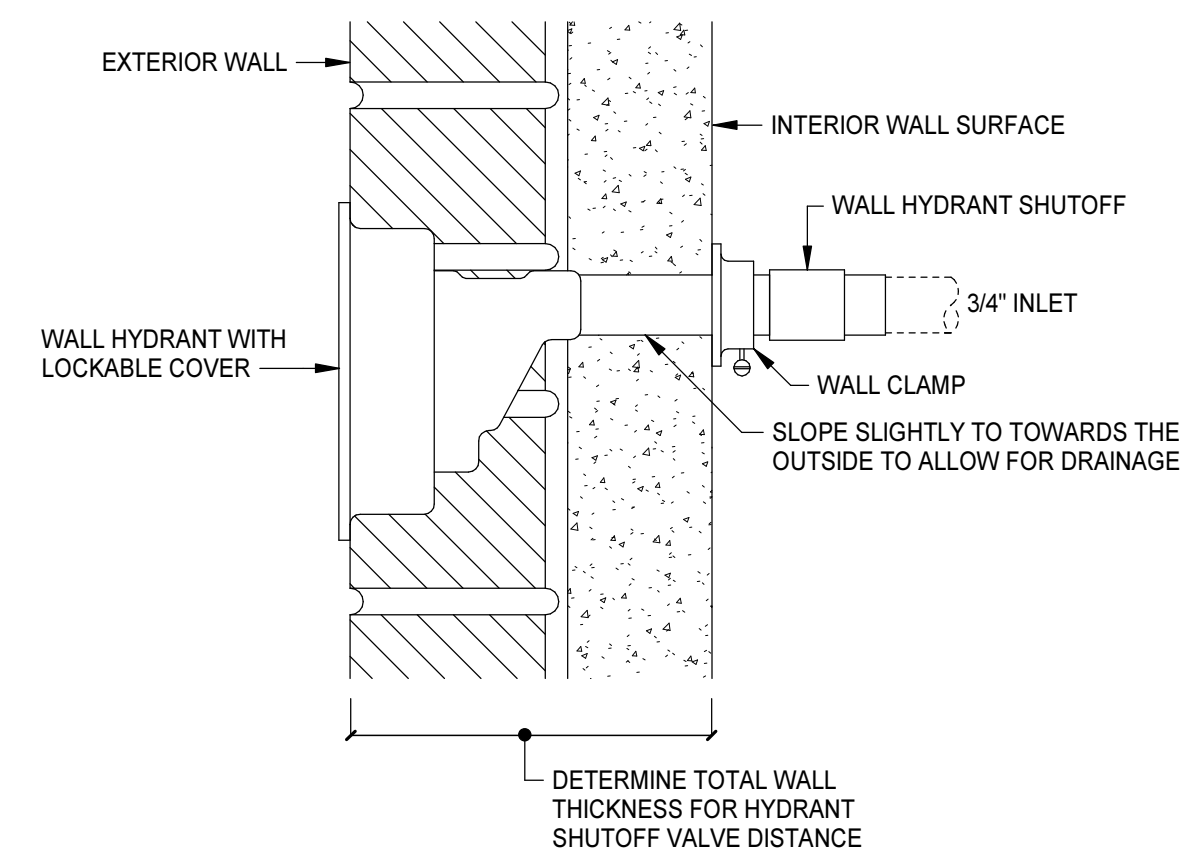


EXTERIOR WALL HYDRANT DETAIL

NO SCALE

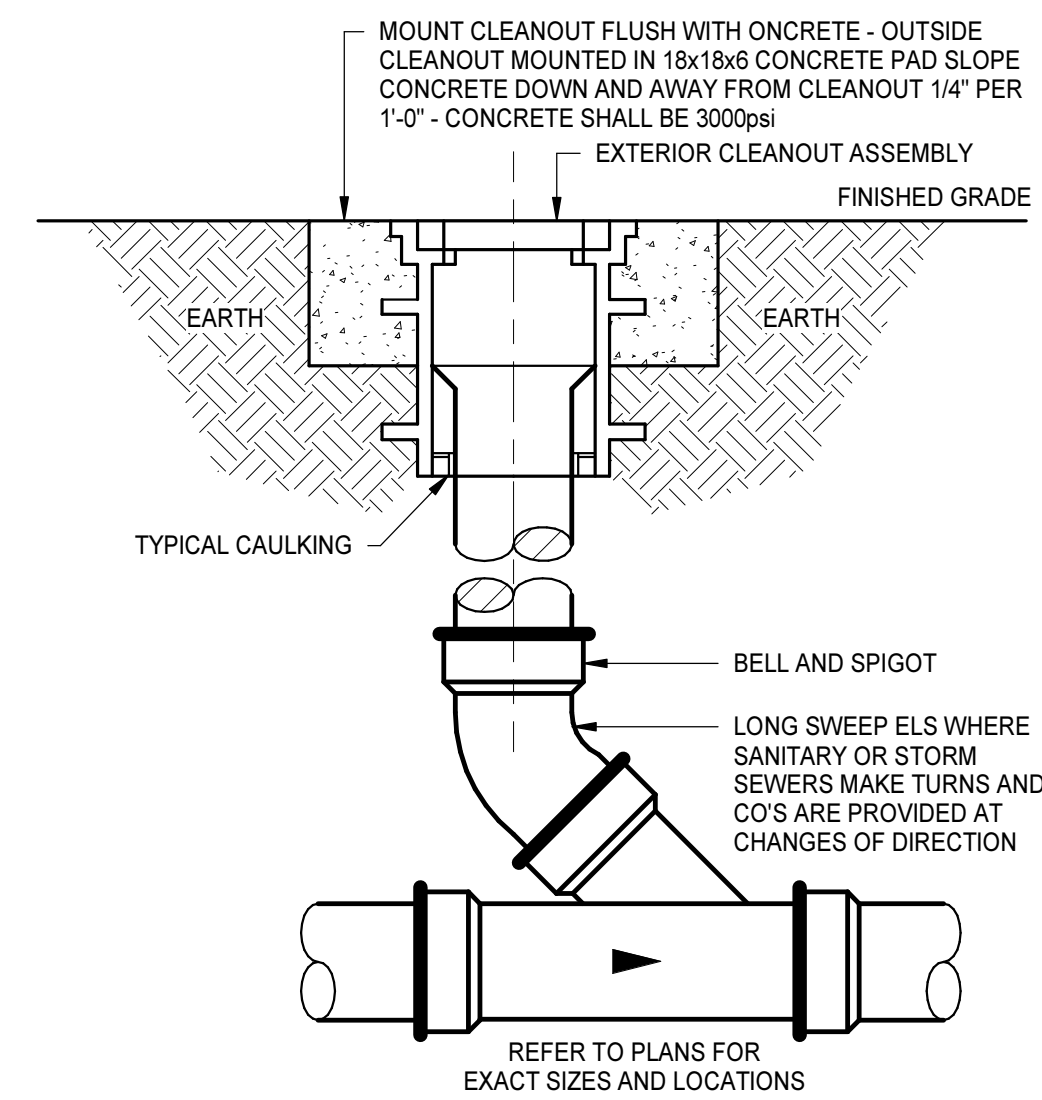

EXTERIOR YARD CLEANOUT DETAIL


NO SCALE

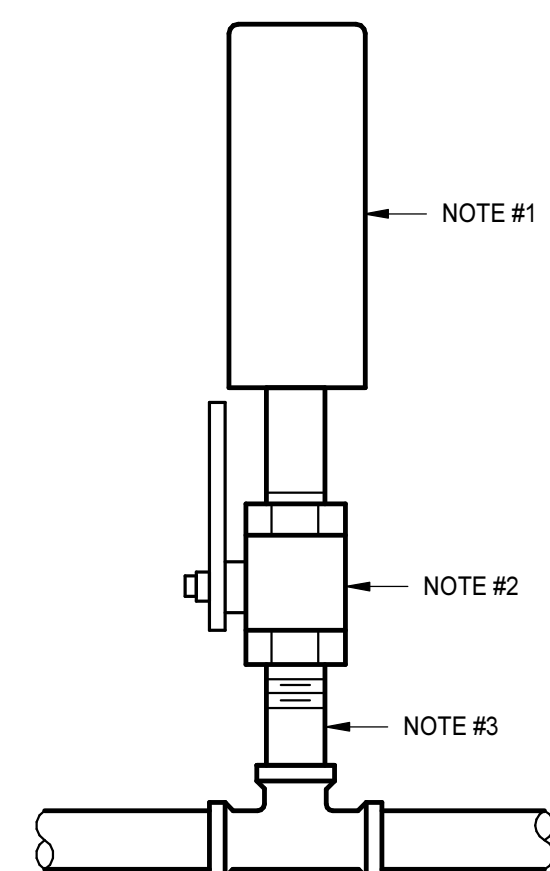

NOTES:
1. WATER HAMMER ARRESTOR
2. BALL VALVE, VALVE SIZE SHALL BE EQUAL TO NOMINAL SIZE OF ARRESTOR OUTLET (MINIMUM 1/2").
3. BRANCH PIPE EQUAL TO NOMINAL SIZE OF ARRESTOR OUTLET (MINIMUM 1/2").


WATER HAMMER ARRESTOR DETAIL

NO SCALE

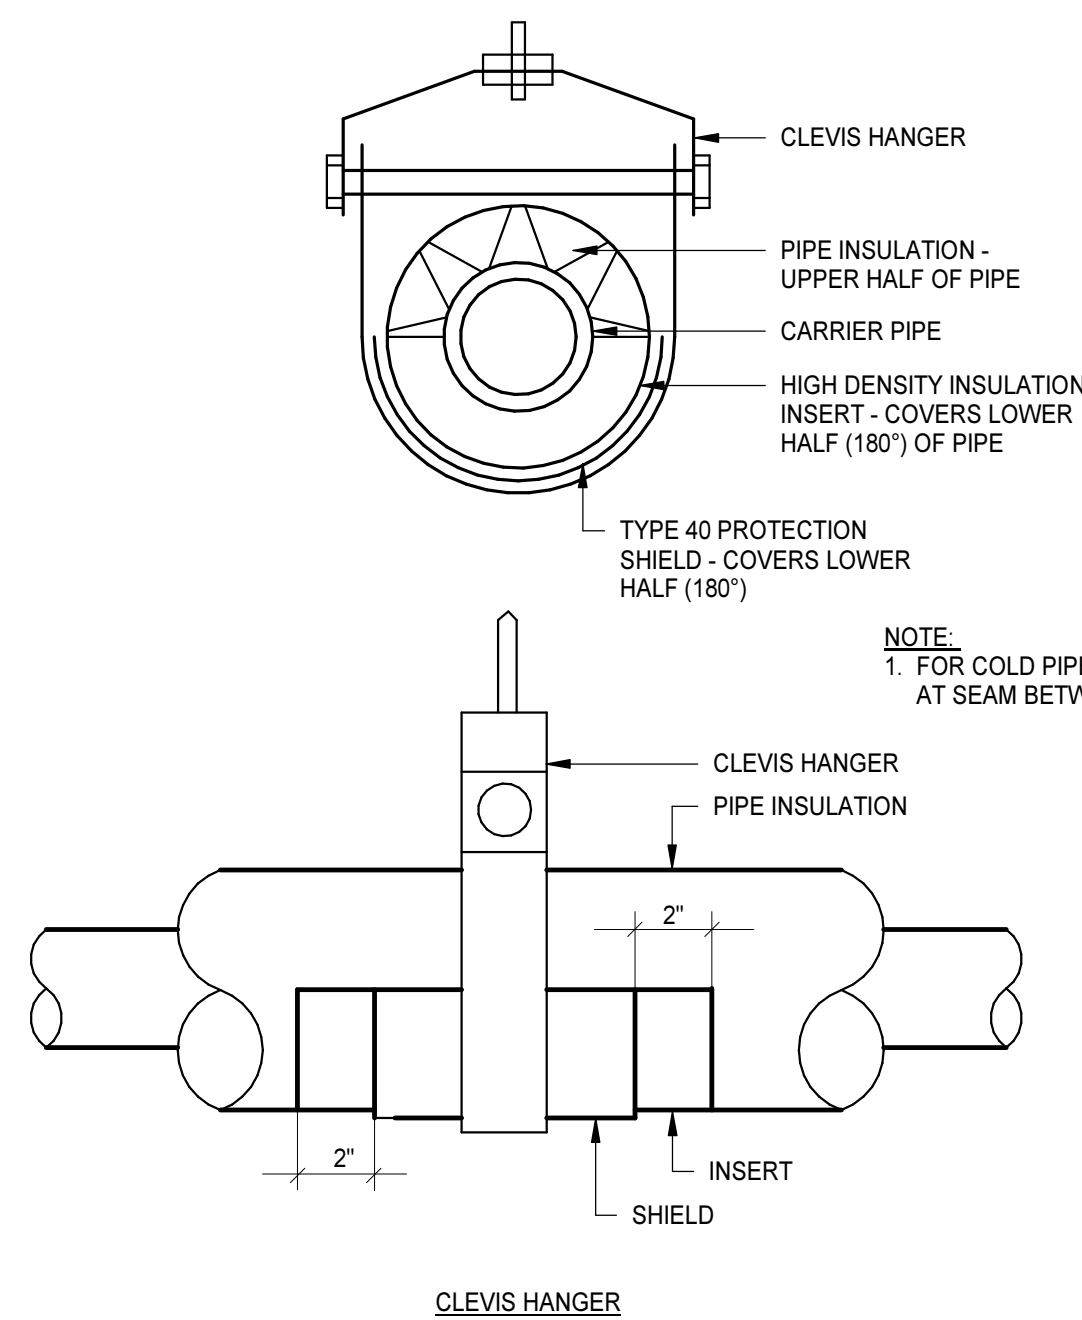


PIPE SUPPORT AND THERMAL SHIELD DETAILS

NO SCALE

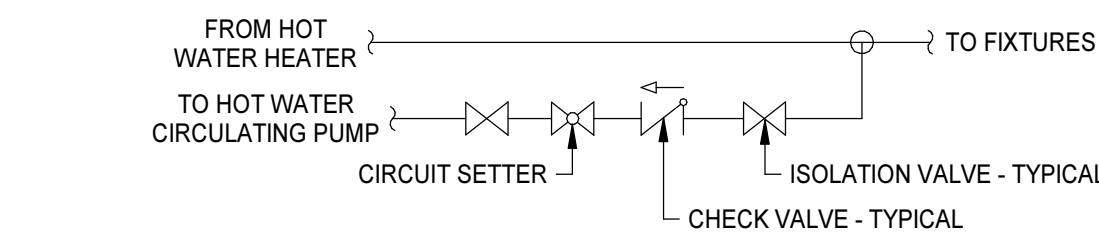

HOT WATER RECIRCULATION BRANCH CONNECTION DETAIL


NO SCALE

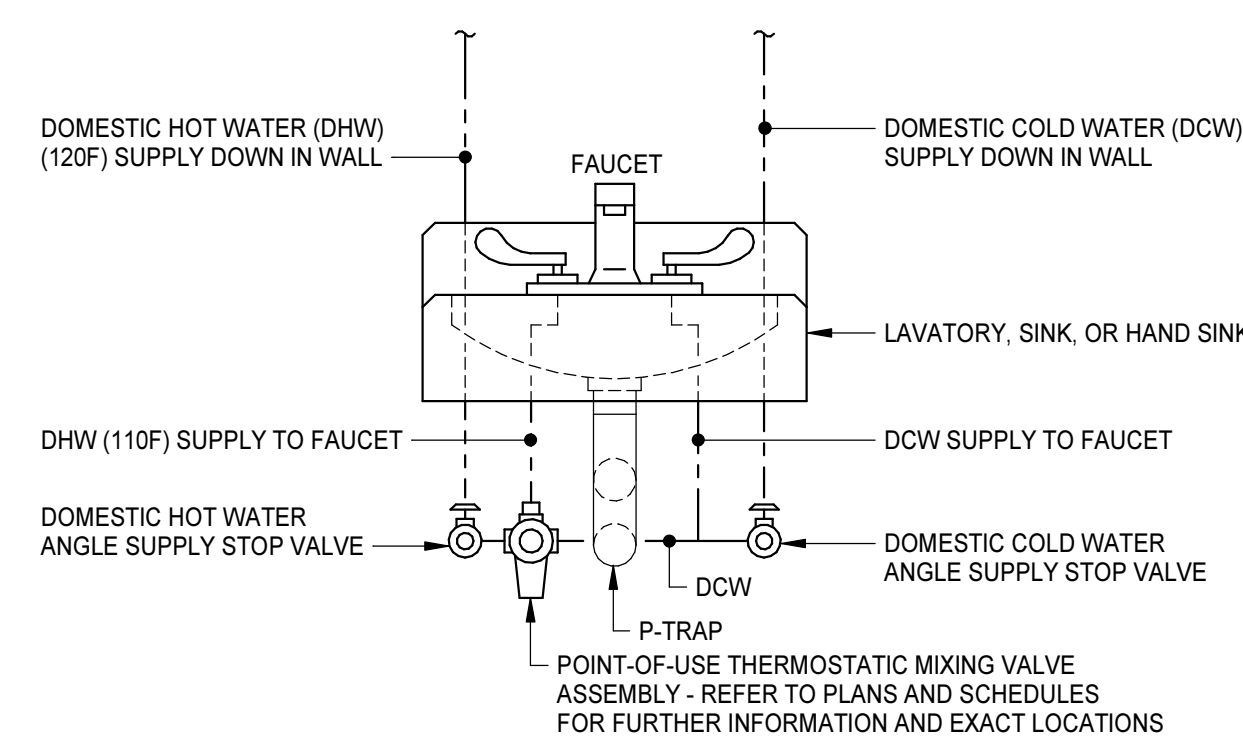

FINISHED FLOOR


LAVATORY, SINK, OR HAND SINK DETAIL

NO SCALE

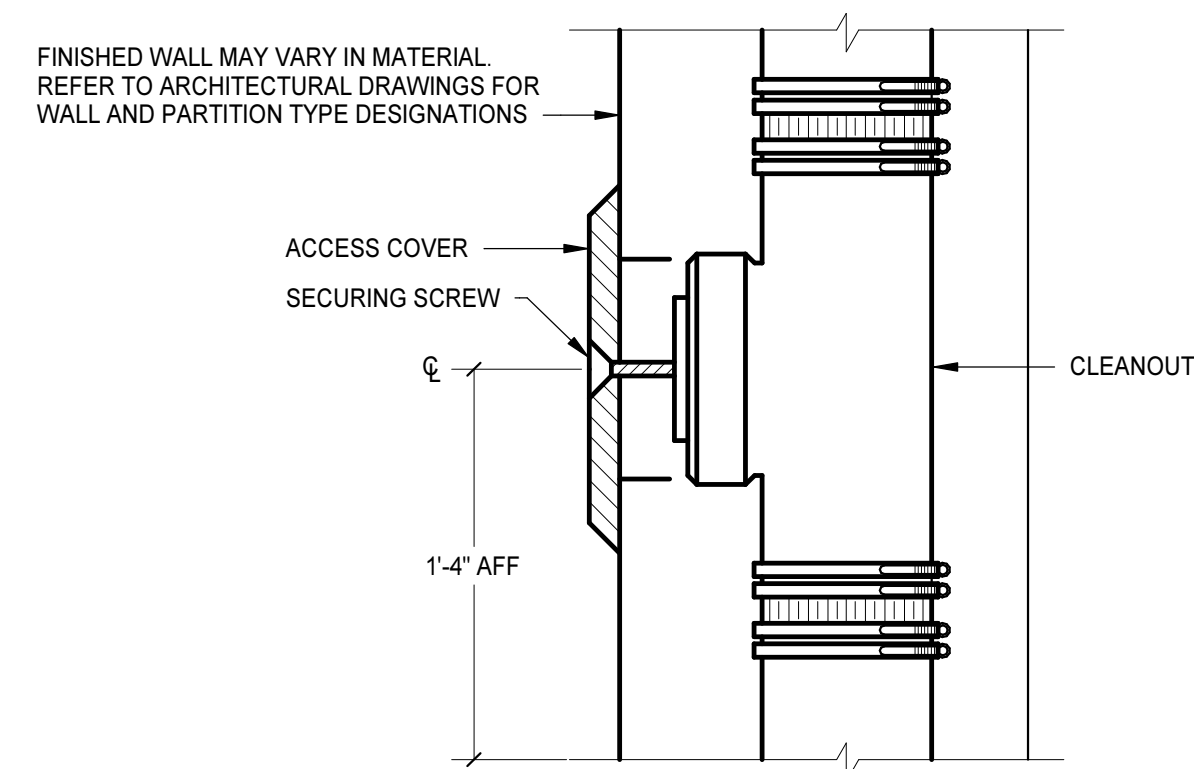


WALL CLEANOUT DETAIL

NO SCALE

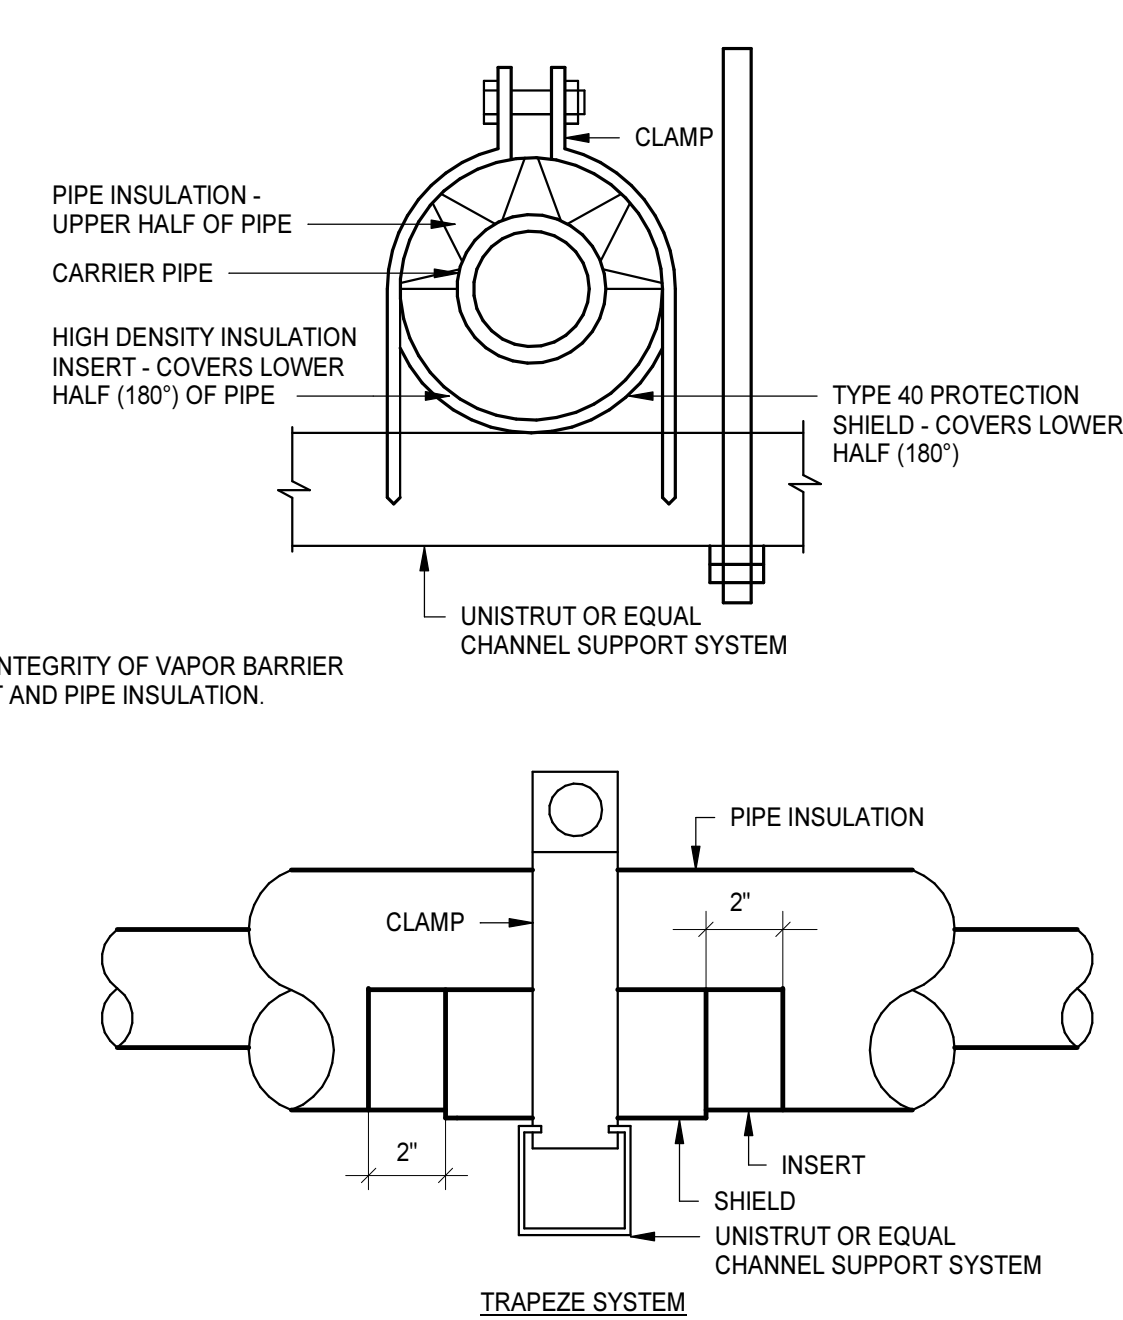


NOTE:
1. FOR COLD PIPE MAINTAIN INTEGRITY OF VAPOR BARRIER AT SEAM BETWEEN INSERT AND PIPE INSULATION.

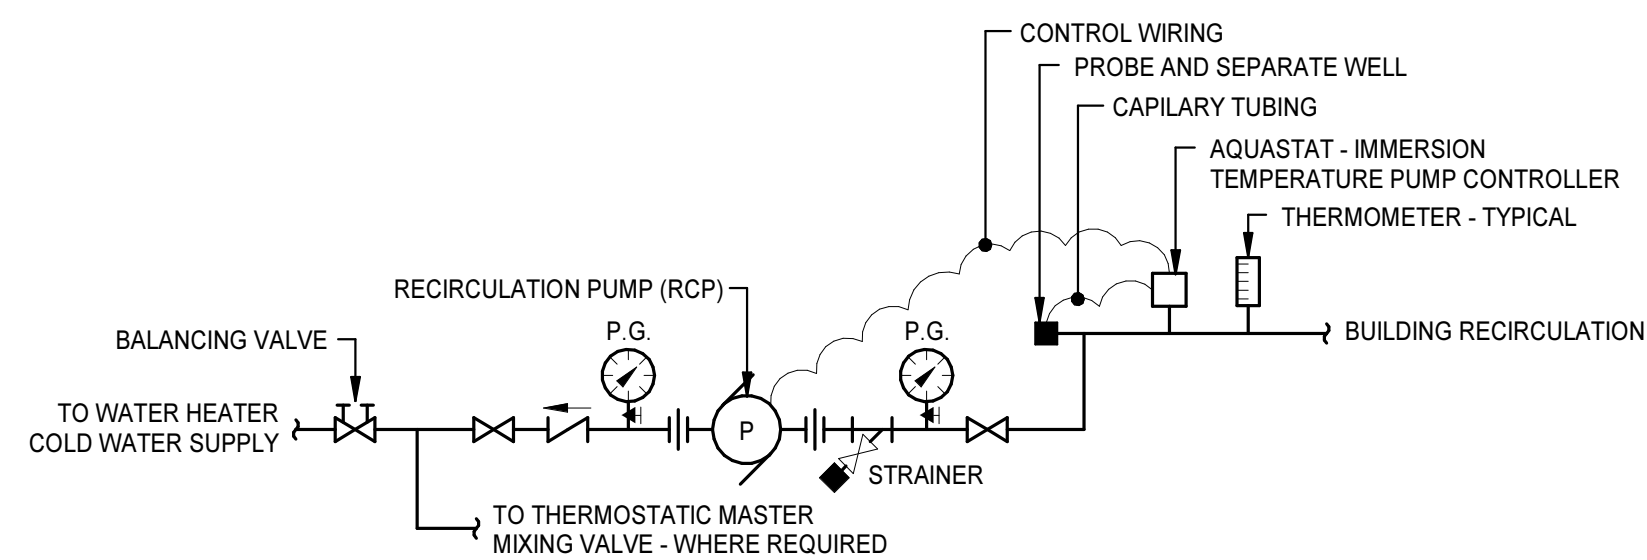


CIRCULATION PUMP DETAIL

NO SCALE

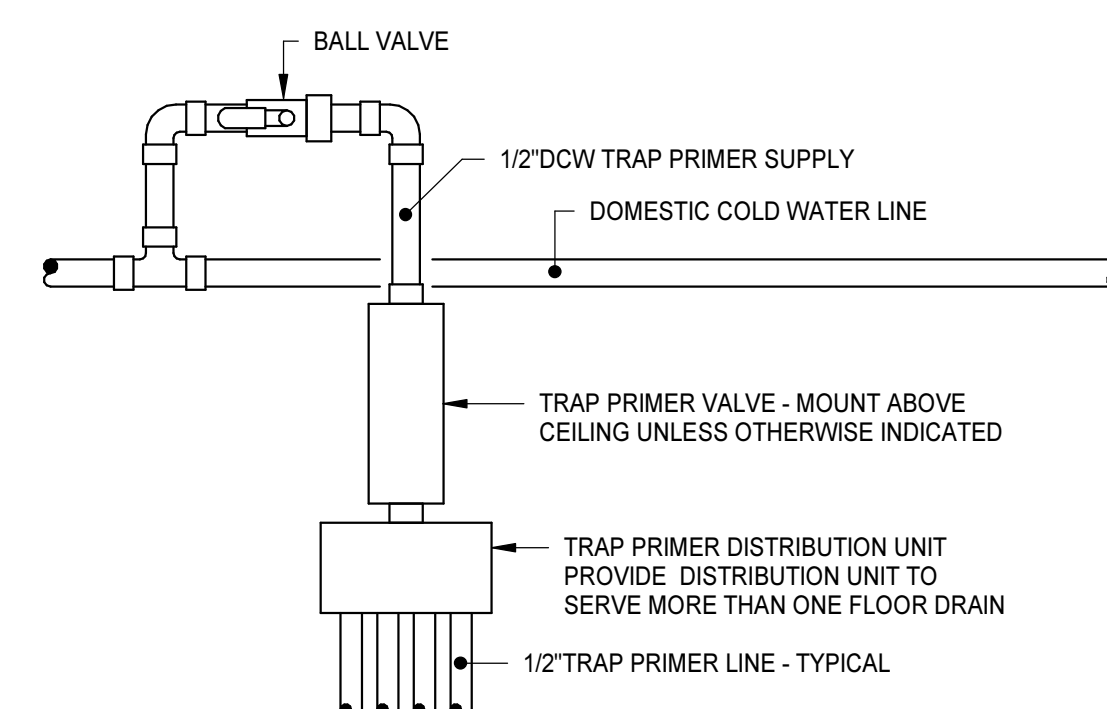


NOTES:
1. PRIMERS, VALVES, AND ASSOCIATED PIPING SHALL BE INSTALLED IN ACCESSIBLE LOCATIONS.
2. PROVIDE DISTRIBUTION UNIT SIZED FOR NUMBER OF DRAINS TO BE SERVED BY EACH INDIVIDUAL PRIMER.
3. DISTRIBUTION UNIT SHALL BE INSTALLED PER MANUFACTURER'S INSTRUCTIONS AND RECOMMENDATIONS.

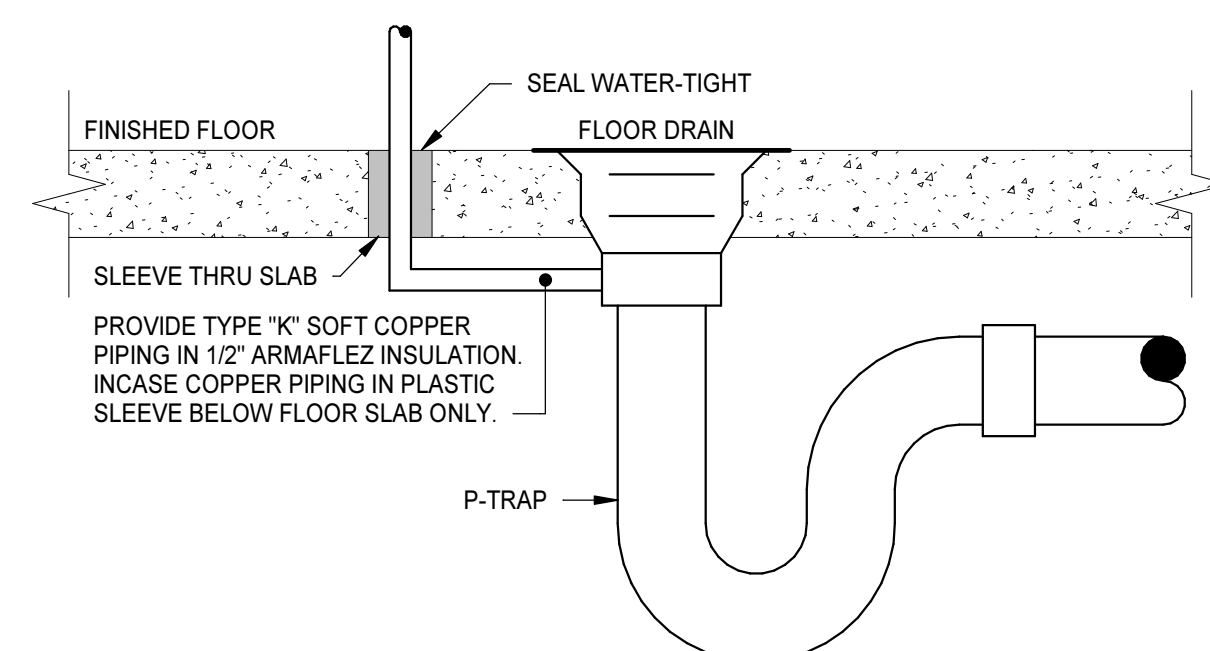

MECHANICAL PRIMER DETAIL


TRAP PRIMER ASSEMBLY DETAILS

NO SCALE

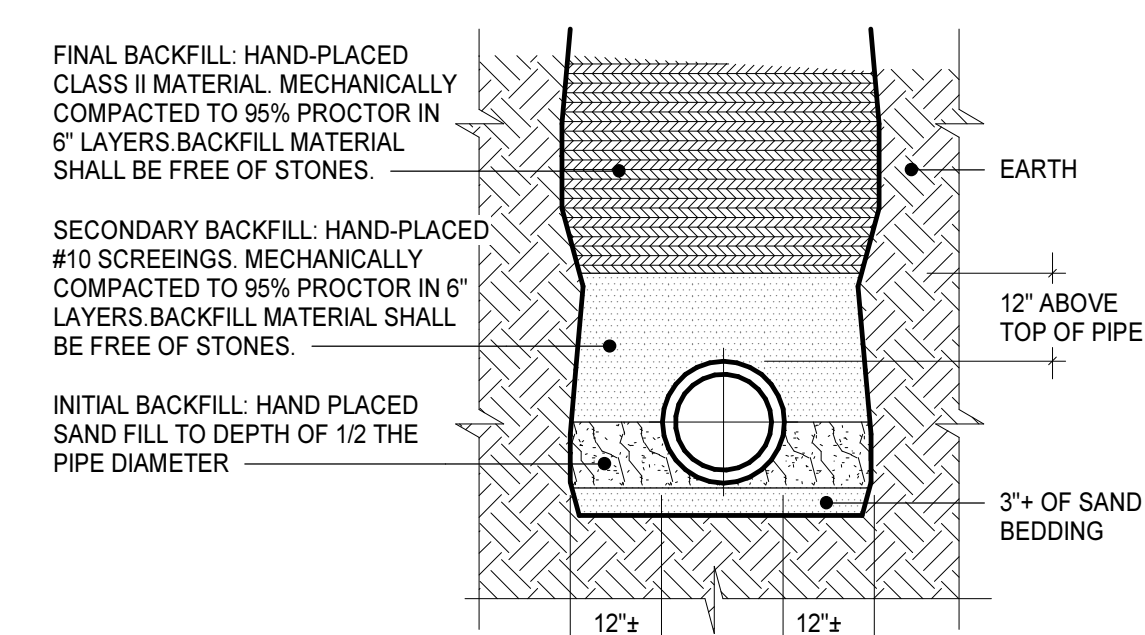

PVC PIPE BEDDING DETAIL

NO SCALE

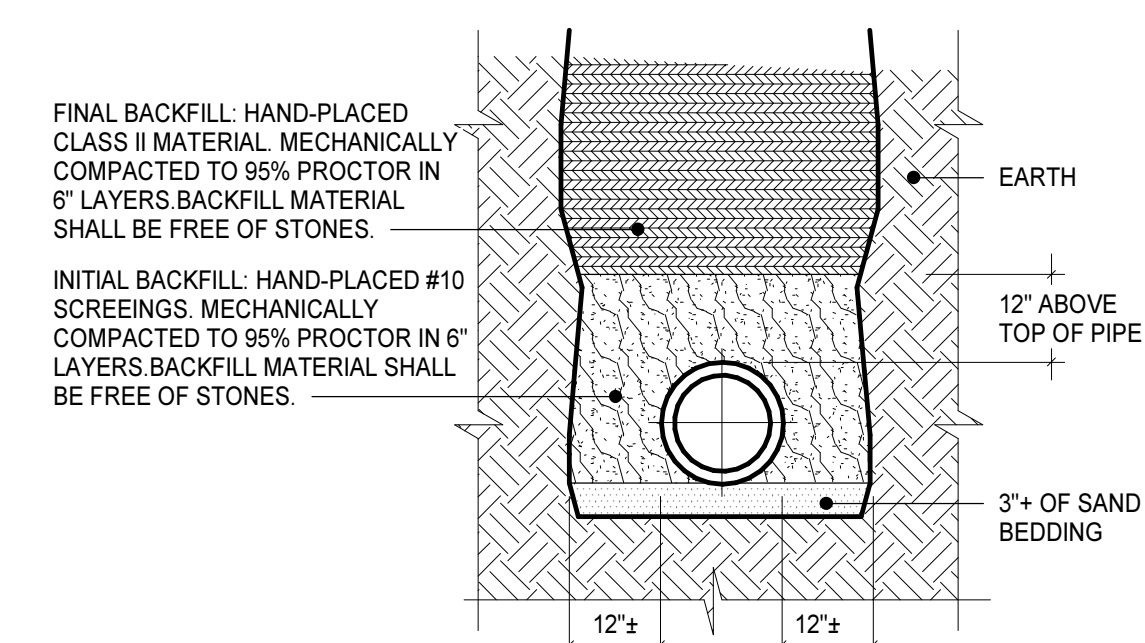

CAST IRON PIPE BEDDING DETAIL

NO SCALE

PLUMBING FIXTURE SCHEDULE										
TAG	FIXTURE	HEIGHT A.F.F.	BASIS OF DESIGN	PIPE SIZE					LEED USAGE DATA	NOTES
				COLD WATER	TEPID WATER	HOT WATER	VENT	SOIL WASTE		
EW-1	EMERGENCY EYEWASH - RECESSED WALL-MOUNTED	34" TO EYEWASH HEADS	FIXTURE: HAWS 7656WCC		1/2"		1 1/2"	1 1/2"		1, 3
SK-1	KITCHENETTE SINK - DOUBLE BOWL (ACCESSIBLE)	COUNTER MOUNTED REFER TO ARCH DWGS	FIXTURE: ELKAY LRADQ331855 FAUCET: ELKAY LKAV1061	1/2"		1/2"	1 1/2"	1 1/2"	1.80 GPM	1, 2, 4
SK-2	SCRUB SINK WITH FOOT CONTROL	RIM AT 36"	FIXTURE: ELKAY EW53120FC FAUCET: LK395A FOOT VALVE: LK398C	1/2"		1/2"	1 1/2"	1 1/2"	2.20 GPM	2
SK-3	ANIMAL GROOMING SINK WITH RAMP AND HAIR TRAP	FLOOR-MOUNTED INTEGRAL SUPPORT LEGS	FIXTURE: SHOR-LINE ELITE 904 0702 40 FAUCET: T&S BRASS B-2278	1/2"		1/2"	1 1/2"	2"	1.15 GPM	2, 5
WB-1	WASHER BOX WITH INTEGRAL HAMMER ARRESTORS	CENTER AT 42"	FIXTURE: GUTGRAY WB200HATM	1/2"		1/2"	2"	2"		

1. THIS ACCESSIBLE FIXTURE, ACCESSORIES, AND INSTALLATION SHALL CONFORM TO THE USBC AND ASAD ADA STANDARDS FOR ACCESSIBLE DESIGN.
2. PROVIDE ASSE-1070 CERTIFIED MIXING VALVE BELOW FIXTURE ACCESSIBLE BUT CONCEALED FROM VIEW.
3. PROVIDE ASSE-1071 CERTIFIED EMERGENCY MIXING VALVE IN CEILING CONCEALED FROM VIEW DIRECTLY ABOVE FIXTURE BEING SERVED.
4. PROVIDE DISHWASHER HOOK-UP WHERE DISHWASHER IS PRESENT. CONNECT HW IN SINK BASE AND CONNECT SANITARY THRU HIGH LOOP HOSE DRAIN INTO DISHWASHER TAIL PIECE SINK DRAIN.
5. PROVIDE ANIMAL GROOMING TUB WITH RAMP ACCESS, HAIR TRAP, AND COMPLETE WASH/SPRAY FAUCET ASSEMBLY.

THERMOSTATIC MIXING VALVE SCHEDULE										
TAG	BASIS OF DESIGN		DESIGN FLOW (GPM)	FLOW RANGE (GPM)	MAX P.D. AT DESIGN FLOW (PSI)	HW SYSTEM TEMPERATURES		CONNECTION SIZE		NOTES
	MANUFACTURER	MODEL				INLET (°F)	OUTLET (°F)	INLET (IN)	OUTLET (IN)	
TMV-1	MGI CONTROLS	OMEGA ST7017	1.50	0.25 - 9.00	5.00	120	105	1/2"	1/2"	1
TMV-2	HAWS	TWBS-EVE	4.20	1.00 - 7.00	5.00	120	80	1/2"	1/2"	2

1. PROVIDE ASSE-1070 POINT OF USE THERMOSTATIC MIXING VALVE FOR ALL PUBLIC LAVATORIES AND SINKS. UNIT SHALL BE MOUNTED CONCEALED FROM VIEW BELOW FIXTURE.
2. PROVIDE ASSE-1071 EMERGENCY THERMOSTATIC MIXING VALVE LOCATED IN CEILING DIRECTLY ABOVE FIXTURE SERVED.

DRAIN AND CLEANOUT SCHEDULE				
TAG	BASIS OF DESIGN		STRAINER/GRATE	NOTES
	MANUFACTURER	MODEL		
FCO	JOSAM	55000	FLOOR CLEANOUT	
FD-1	JOSAM	30000-6A-VP	6" ROUND	1

1. PROVIDE TRAP PRIMER CONNECTION AND EXTENSION. SEE DETAIL.



PROJECT NO: 615225	
DATE: AUGUST 18, 2025	
REVISIONS	
DATE	DESCRIPTION

ABBREVIATIONS

@	AT
ABV	ABOVE
AFB	ABOVE FINISHED FLOOR
AFG	ABOVE FINISHED GRADE
AHU	AIR HANDLING UNIT
BLDG	BUILDING
CL	CENTERLINE
CLG	CEILING
COL	COLUMN
CONC	CONCRETE
CONT	CONTINUATION
CORR	CORRIDOR
CR	CLASSROOM
CU	CUBIC
CU FT	CUBIC FEET
DCW	DOMESTIC COLD WATER
DEG	DEGREES(S)
DEMO	DEMOLISH OR DEMOLITION
DIA	DIAMETER
DIP	DUCTILE IRON PIPE
DN	DOWN
DP	DRY PIPE
DS	DOWNSPOUT
DTL	DETAIL
DWG	DRAWING
E	EAST
ECOH	ELECTRIC CEILING HEATER
EF	EXHAUST FAN
EH-1	EXTRA HAZARD GROUP 1
EH-2	EXTRA HAZARD GROUP 2
ELEC	ELECTRICAL
EQ	EQUAL
EQUIP	EQUIPMENT
ET	EXPANSION TANK
ETR	EXISTING TO REMAIN
EWH	ELECTRIC WATER HEATER
EX	EXISTING
EXP	EXPANSION
F	FARENHEIT
FD	FIRE DAMPER
FDC	FIRE DEPARTMENT CONNECTION
FG	FINISHED GRADE
FH	FIRE HYDRANT
FHC	FIRE HOSE CABINET
FHS	FIRE HOSE STATION
FHVC	FIRE HOSE VALVE CABINET
FLR	FLOOR
FP	FIRE PROTECTION
FT	FOOT OR FEET
FVC	FIRE VALVE CABINET
GAL	GALLONS(S)
GPM	GALLONS PER MINUTE
GUH	GAS-FIRED UNIT HEATER
HB	HOSE BIB
HD	HEAD
HORIZ	HORIZONTAL
HP	HORSEPOWER
HW	HOT WATER
ID	INSIDE DIAMETER
IN	INCH
INSUL	INSULATE OR INSULATION
JAN	JANITOR
KIT	KITCHEN
KW	KILOWATT(S)
LAB	LABORATORY
LAV	LAVATORY
LBS	POUNDS
LF	LINEAR FOOT (FEET)
LH	LIGHT HAZARD
MATL	MATERIAL
MAX	MAXIMUM
MECH	MECHANICAL
MFR	MANUFACTURER
MH	MANHOLE
MIN	MINIMUM
MISC	MISCELLANEOUS
MTD	MOUNTED
N	NORTH
NA	NOT APPLICABLE/AVAILABLE
NC	NORMALLY CLOSED
NIC	NOT IN CONTRACT
NO	NORMALLY OPEN
NO. OR #	NUMBER
OC	ON CENTER
OD	OUTSIDE DIAMETER
OFCI	OWNER FURNISHED CONTRACTOR INSTALLED
OFF	OFFICE
OH-1	ORDINARY HAZARD GROUP 1
OH-2	ORDINARY HAZARD GROUP 2
P	PUMP
PC	PRECAST
PV	POST INDICATOR VALVE
POLY	POLYETHYLENE
PREFAB	PREFABRICATE(D)
PROJ	PROJECT
PSF	POUNDS PER SQUARE FOOT
PSI	POUNDS PER SQUARE INCH
PSIG	POUNDS PER SQUARE INCH GAUGE
PVC	POLYVINYL CHLORIDE
R	RISER
REF	REFERENCE
REQ	REQUIRED
RM	ROOM
RPM	REVOLUTIONS PER MINUTE
RTU	ROOF TOP UNIT
S	SOUTH
SAN	SANITARY
SCH	SCHEDULE
SD	SMOKE DAMPER
SHT	SHEET
SIM	SIMILAR
SP	STATIC PRESSURE
SPEC	SPECIFICATION
SPR	SPRINKLER
SQ	SQUARE
STD	STANDARD
STL	STEEL
STOR	STORAGE
SW	SWITCH
T	TEMPERATURE
THK	THICKNESS
TLT	TOILET
TOSL	TOP OF SLAB
TYP	TYPICAL
UG	UNDERGROUND
UH	UNIT HEATER
UI	UNLESS UNDCATED
UNO	UNLESS NOTED (INDICATED) OTHERWISE
V	VOLTS
VERT	VERTICAL
VF	VERIFY IN FIELD
W	WEST
WI	WITH
W/O	WITHOUT
WH	WATER HEATER

GRAPHICS SYMBOLS LEGEND

	INDICATES AREAS OF THE BUILDING IN WHICH THE SPACING OF HEADS IS BASED ON LIGHT HAZARD CLASSIFICATION PROVIDING A DENSITY OF 0.10 GPM PER SQUARE FOOT OVER 1500 SQUARE FEET.
	INDICATES AREAS OF THE BUILDING IN WHICH THE SPACING OF HEADS IS BASED ON ORDINARY HAZARD GROUP 1 CLASSIFICATION PROVIDING A DENSITY OF 0.15 GPM PER SQUARE FOOT OVER 1500 SQUARE FEET.
	INDICATES AREAS OF THE BUILDING IN WHICH THE SPACING OF HEADS IS BASED ON ORDINARY HAZARD GROUP 2 CLASSIFICATION PROVIDING A DENSITY OF 0.20 GPM PER SQUARE FOOT OVER 1500 SQUARE FEET.
	INDICATES AREAS OF THE BUILDING IN WHICH THE SPACING OF DRY SPRINKLER HEADS IS BASED ON ORDINARY HAZARD GROUP 2 CLASSIFICATION PROVIDING A DENSITY OF 0.20GPM PER SQUARE FOOT OVER 1500 SQUARE FEET.
	INDICATES AREAS OF THE BUILDING THAT WILL REQUIRE ORDINARY HAZARD GROUP 1 PRE-ACTION PROTECTION, BRANCHING FROM THE LINE THAT SERVES THE AREA.
	INDICATES AREAS OF THE BUILDING IN WHICH THE SPACING OF HEADS IS BASED ON EXTRA HAZARD GROUP 1 CLASSIFICATION PROVIDING A DENSITY OF 0.30 GPM PER SQUARE FOOT OVER 2500 SQUARE FEET.
	INDICATES AREAS OF THE BUILDING IN WHICH THE SPACING OF HEADS IS BASED ON EXTRA HAZARD GROUP 2 CLASSIFICATION PROVIDING A DENSITY OF 0.40 GPM PER SQUARE FOOT OVER 2500 SQUARE FEET.
	POINT OF CONNECTION TO EXISTING
	LIMIT OF DEMOLITION
	KEYNOTE
	SPACE IDENTIFICATION TAG SPACE NUMBER BUILDING AREA (WHEN USED)
	EQUIPMENT IDENTIFICATION TAG EQUIPMENT NUMBER UNIT DESIGNATION
	STRUCTURAL GRID LINE WITH DESIGNATION
	SECTION WHERE CUT SECTION LETTER DRAWING WHERE SECTION IS INDICATED
	ENLARGED PLAN WHERE CUT ENLARGED PLAN NUMBER DRAWING WHERE ENLARGED PLAN IS INDICATED
	DETAIL TAG DETAIL NUMBER DRAWING WHERE DETAIL IS INDICATED
	DETAIL TITLE 1'-0" x 1'-0" DETAIL NUMBER DRAWING WHERE DETAIL IS INDICATED DRAWING WHERE DETAIL IS CUT ADDITIONAL DRAWING REFERENCES
	SECTION TITLE 1'-0" x 1'-0" SECTION LETTER DRAWING WHERE SECTION IS INDICATED DRAWING WHERE SECTION IS CUT ADDITIONAL DRAWING REFERENCES

GENERAL NOTES

THE CONTRACT DOCUMENTS ARE COMPLEMENTARY AND WHAT IS REQUIRED BY ONE SHALL BE AS BINDING AS IF REQUIRED BY ALL. IN THE CASE OF A CONFLICT, DISAGREEMENT, OR AMBIGUITY, PROVIDE THE BETTER QUALITY. IN THE CASE OF A CONFLICT, DISAGREEMENT, OR AMBIGUITY, PROVIDE THE GREATER QUANTITY OF WORK.

COORDINATE THE LOCATION OF ALL SPRINKLER PIPING WITH THE WORK OF OTHER TRADES. SPRINKLER PIPING SHALL NOT BE INSTALLED WHERE ITS LOCATION INHIBITS ACCESS TO EQUIPMENT ABOVE THE CEILING, FILTER ACCESS OR INFRINGES UPON CLEARANCES DICTATED BY THE NATIONAL ELECTRIC CODE.

VERIFY DIMENSIONS AND ROUTING IN FIELD BEFORE FABRICATION OF PIPING AND FIXTURES.

REFER TO THE LIFE SAFETY PLAN FOR LOCATIONS OF FIRE AND SMOKE SEPARATION ASSEMBLIES.

REFER TO STRUCTURAL DRAWINGS FOR DETAILS AND MAXIMUM SPACING REQUIREMENTS REGARDING HANGER ATTACHMENTS TO STEEL BAR JOISTS.

ADD/ RELOCATE FIRE SPRINKLERS THROUGHOUT THE SPACE BEING RENOVATED IN ACCORDANCE WITH 2021 VIRGINIA BUILDING CODE, 2019 NFPA 13 AND ALL OTHER REQUIREMENTS SET FORTH BY LOCAL AUTHORITY HAVING JURISDICTION. INSTALLATION DRAWINGS SHALL BE PREPARED BY A PROFESSIONAL ENGINEER LICENSED TO PRACTICE IN THE COMMONWEALTH OF VIRGINIA OR BY A NICET LEVEL III OR IV DESIGNER CERTIFIED IN THE FIELD OF WATER BASED SYSTEMS LAYOUT.

PIPE ALL SYSTEM DRAINS TO AN APPROVED LOCATION ON THE OUTSIDE PERIMETER OF BUILDING. DO NOT DISCHARGE DRAIN INTO A JANITORS SINK WITHOUT APPROVAL FROM PLUMBING ENGINEER.

SPRINKLER HEADS


IN SUSPENDED ACOUSTICAL CEILINGS: PROVIDE NEW FIRE SPRINKLERS AND ESCUTCHEONS THAT MATCH THE EXISTING TYPES USED IN ADJACENT SPACES.

IN CLEAN ROOM ENVIRONMENTS: INSTALL A CLEAN ROOM TYPE CONCEALED SPRINKLER IN CEILING PER MANUFACTURERS REQUIREMENTS AND RECOMMENDATIONS.

INSTALL SPRINKLERS IN CENTER OF ACOUSTICAL TILE CEILING PANELS.


8/15/2025 3:10:51 AM

A B C D E F G H I J

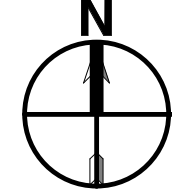

FIRST FLOOR PLAN - DEMOLITION - FIRE PROTECTION'


1/4" = 1'-0"

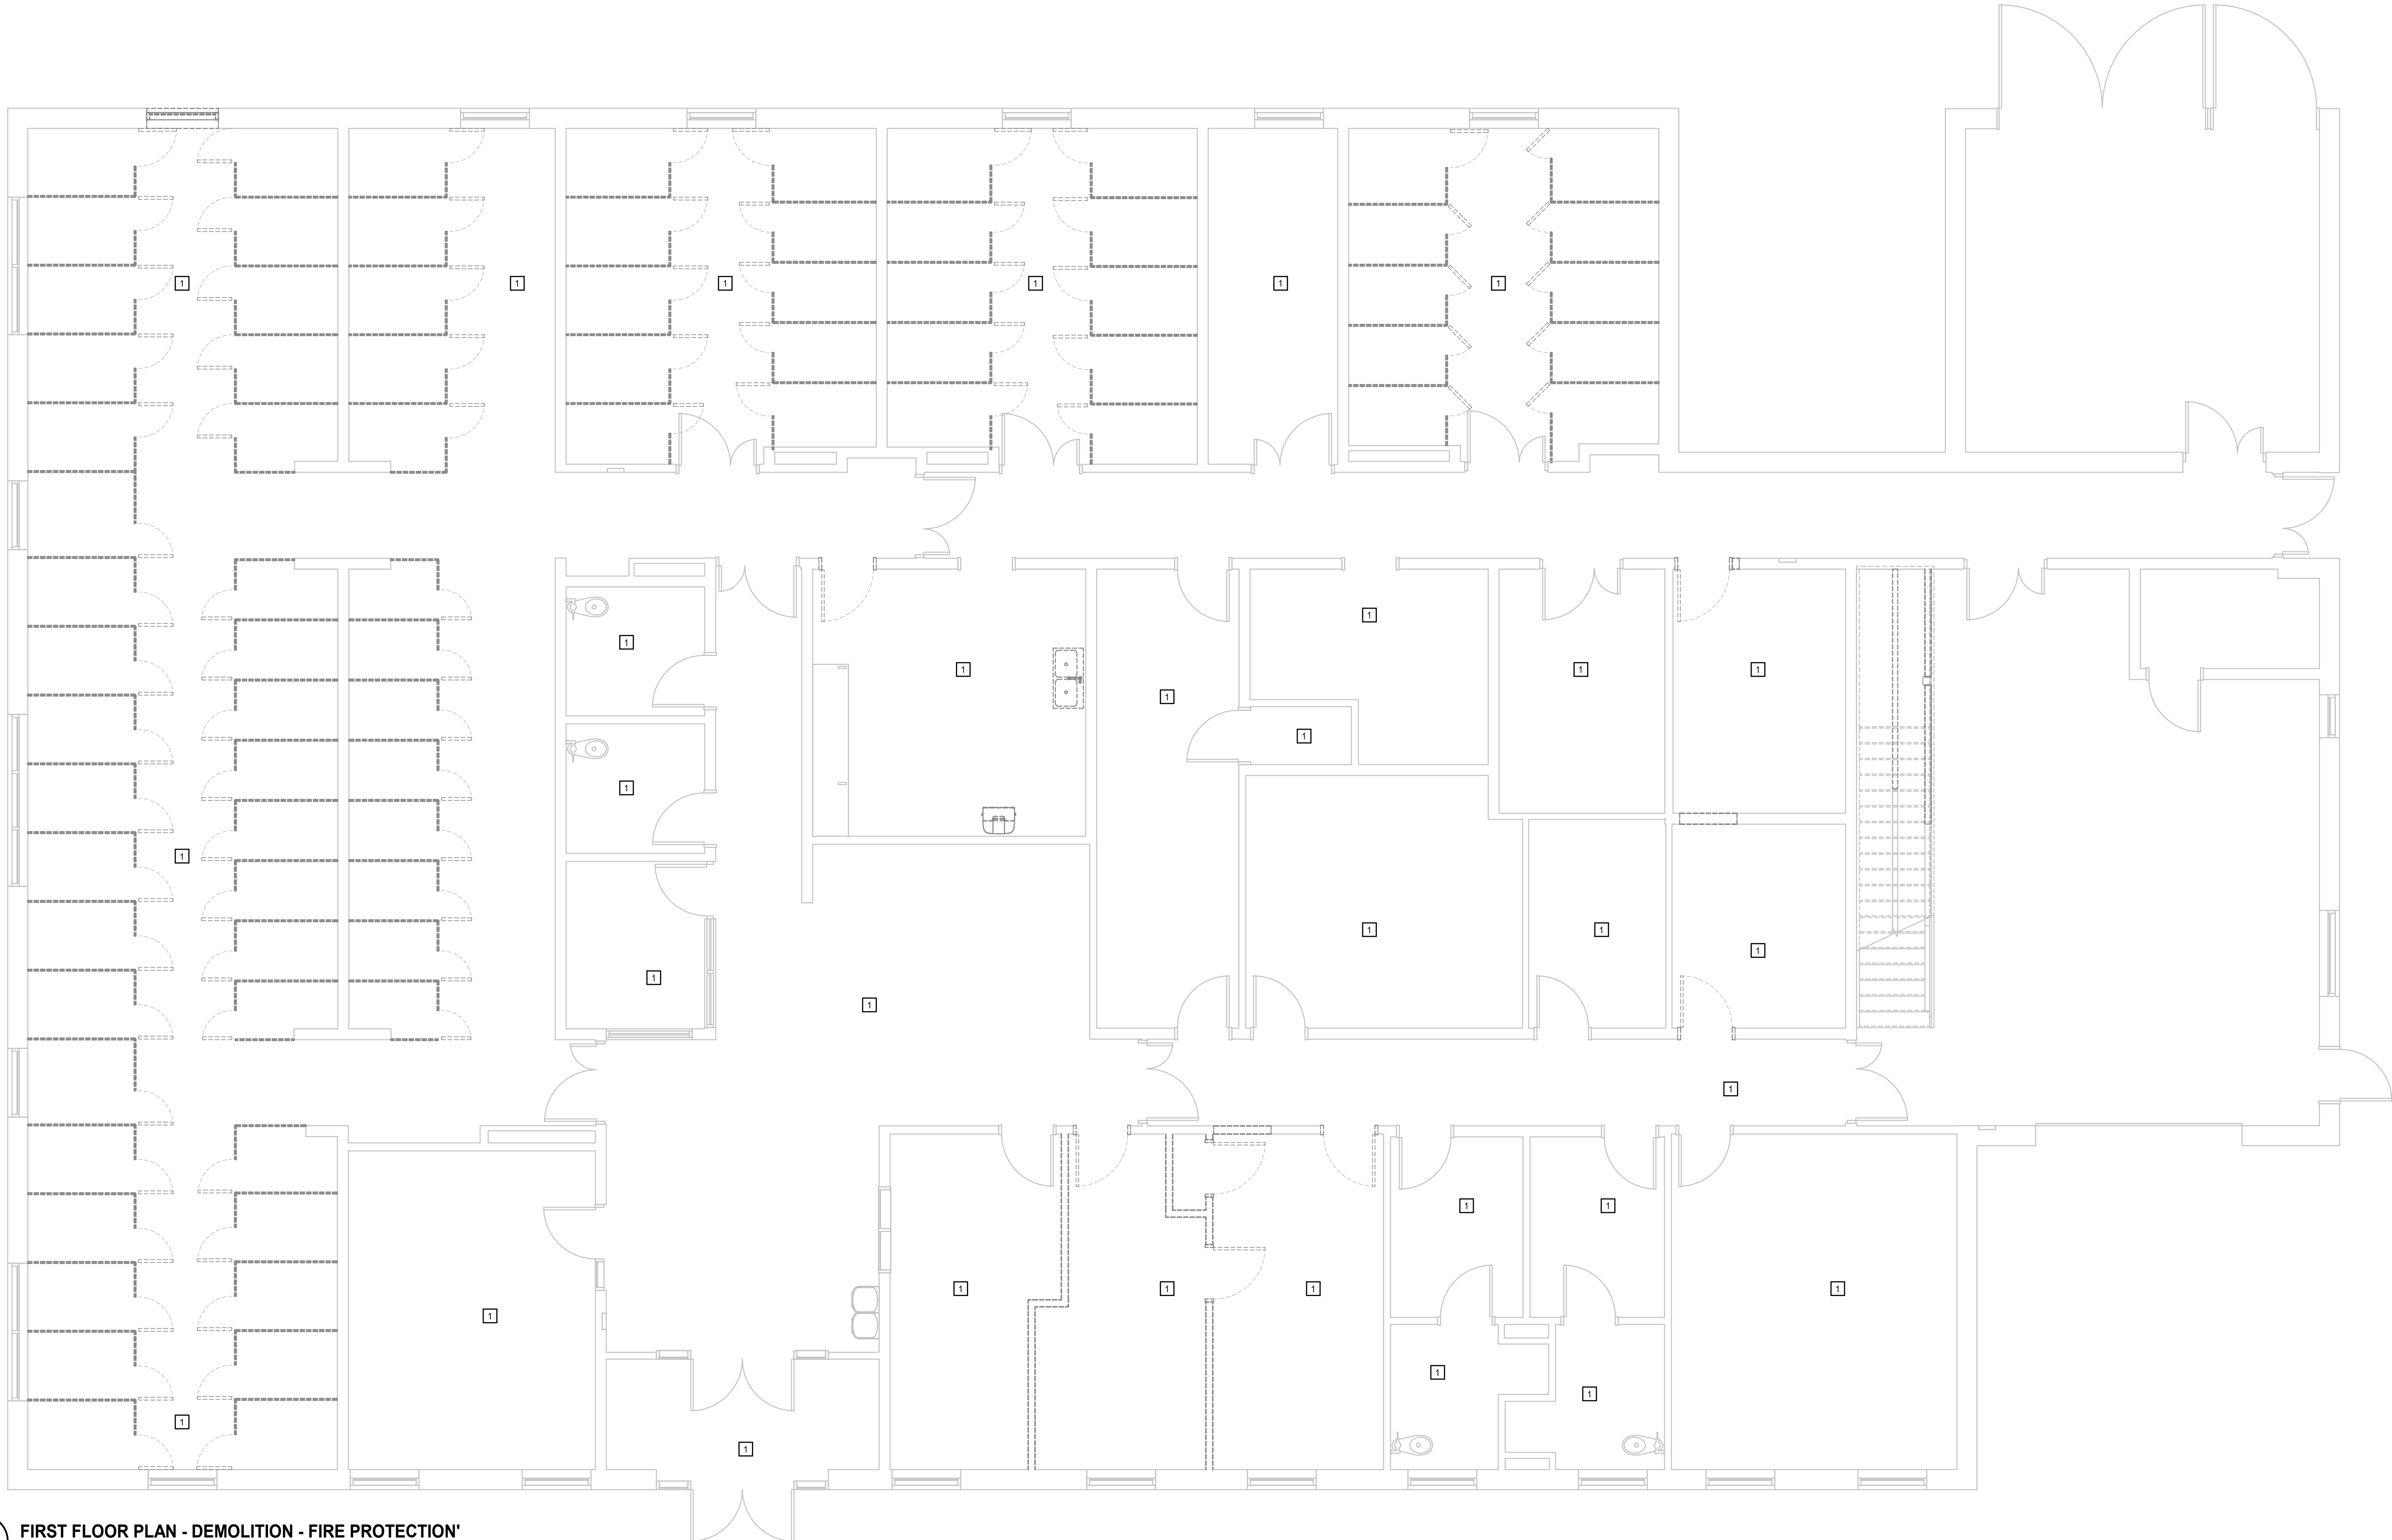

FIRE PROTECTION DEMOLITION KEYNOTES

APPLIES TO DRAWINGS FP1.1
REPRESENTED BY [1]

1. REMOVE EXISTING FIRE SPRINKLERS IN THIS SPACE TO ACCOMMODATE THE REMOVAL OF CEILING.

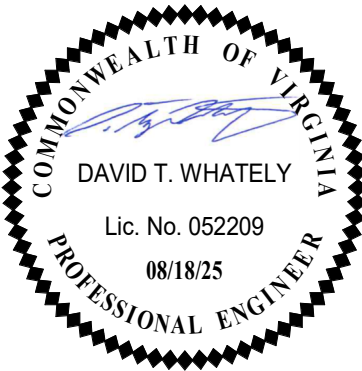

HENRICO COUNTY ANIMAL SHELTER RENOVATION

10421 WOODMAN ROAD, GLEN ALLEN, VA 23060
HENRICO COUNTY

PROJECT NO: 615225
DATE: AUGUST 18, 2025

REVISIONS	
DATE	DESCRIPTION

FIRST FLOOR PLAN -
DEMOLITION - FIRE
PROTECTION

FP1.1

MOSELEYARCHITECTS

5200 NORFOLK STREET, RICHMOND, VA 23230
PHONE (804) 784-7555 FAX (804) 355-5690
MOSELEYARCHITECTS.COM

8/15/2025 3:10:52 AM



FIRST FLOOR PLAN - FIRE PROTECTION


1/4" = 1'-0"



FIRE PROTECTION KEYNOTES

APPLIES TO DRAWINGS FP2.1
REPRESENTED BY [7]

1. ADD/ RELOCATE FIRE SPRINKLERS IN THIS SPACE TO ACCOMMODATE THE RENOVATIONS TO CEILING AND/OR WALLS IN ACCORDANCE W/ NFPA 13 REQUIREMENTS AND REGULATIONS.
2. PROVIDE CLEAN ROOM STYLE CONCEALED SPRINKLERS IN THIS SPACE.
3. PROVIDE EXTRA HAZARD COVERAGE FOR OXYGEN STORAGE ROOM UNDER STAIRS.
4. INSTALL NEW FIRE SPRINKLERS IN THIS SPACE TO ACCOMMODATE THE INSTALLATION OF NEW CEILING.

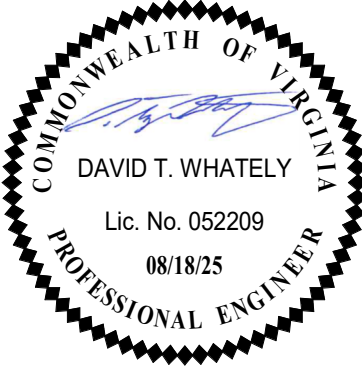

HENRICO COUNTY ANIMAL SHELTER RENOVATION

10421 WOODMAN ROAD, GLEN ALLEN, VA 23060
HENRICO COUNTY

PROJECT NO:	615225
DATE:	AUGUST 18, 2025
REVISIONS	
DATE	DESCRIPTION

FIRST FLOOR PLAN -
FIRE PROTECTION

FP2.1

MOSELEYARCHITECTS

5200 NORFOLK STREET, RICHMOND, VA 23230
PHONE (804) 784-7557 FAX (804) 355-5690
MOSELEYARCHITECTS.COM

EQUIPMENT ABBREVIATIONS	
AHU	AIR-HANDLING UNIT
AS	AIR SEPARATOR
B	BOILER
BCU	BLOWER COIL UNIT
CCC	CLOSED-CIRCUIT COOLING TOWER
CH	CHILLER
CHWP	CHILLED WATER PUMP
CRAC	COMPUTER ROOM AIR CONDITIONER
CT	COOLING TOWER
CUH	CABINET UNIT HEATER
CWP	CONDENSER WATER PUMP
ECU	ELECTRIC CEILING HEATER
ERU	ENERGY RECOVERY UNIT
ERV	ENERGY RECOVERY VENTILATOR
ET	EXPANSION TANK
EUH	ELECTRIC UNIT HEATER
F	FAN
FCU	FAN COIL UNIT
HP	HEAT PUMP
HWP	HOT WATER PUMP
HX	HEAT EXCHANGER
MAU	MAKEUP AIR UNIT
OAU	OUTDOOR AIR UNIT
P	PUMP
PTAC	PACKAGED TERMINAL AIR CONDITIONER
PTHP	PACKAGED TERMINAL HEAT PUMP
RTU	ROOFTOP UNIT
SSI	SPLIT-SYSTEM INDOOR UNIT
SSO	SPLIT-SYSTEM OUTDOOR UNIT
TU	TERMINAL UNIT
UH	UNIT HEATER
WSHP	WATER-SOURCE HEAT PUMP

CONTROLS ABBREVIATIONS	
AF	AIRFLOW
AI	ANALOG INPUT TO CONTROLLER
ALM	ALARM
AMS	AIRFLOW MEASURING STATION
AO	ANALOG OUTPUT FROM CONTROLLER
ATS	AVERAGING TEMPERATURE SENSOR
BAS	BUILDING AUTOMATION SYSTEM
BI	BINARY INPUT TO CONTROLLER
BO	BINARY OUTPUT FROM CONTROLLER
CO2	CARBON DIOXIDE SENSOR
CSR	CURRENT-SENSING RELAY
DM	DAMPER MOTOR
DP	DIFFERENTIAL PRESSURE
DPT	DIFFERENTIAL PRESSURE TRANSMITTER
FM	FLOW METER
FZ	FREEZESTAT
HS	HUMIDITY SENSOR
POS	POSITION
R	RELAY
SD	SMOKE DETECTOR
SPD	SPEED
SS	START/STOP
STS	STATUS
TS	TEMPERATURE SENSOR
VFD	VARIABLE-FREQUENCY DRIVE

CONTROL SYMBOL LEGEND			
	CIRCULATOR OR PUMP		NORMALLY OPEN CONTACT
	MOTORIZED 2-WAY VALVE		NORMALLY CLOSED CONTACT
	MOTORIZED 3-WAY VALVE		WIRING OR DEVICE PROVIDED UNDER DIVISION 23
	VARIABLE FREQUENCY DRIVE		WIRING CONNECTION BY DIVISION 23
	DIRECT DIGITAL CONTROLLER		WIRING CONNECTION BY OTHERS
	THERMOSTAT		NUMBER OF CONDUCTORS INDICATED BY SLASH MARKS
	FREEZESTAT		MOTORIZED PARALLEL BLADE DAMPER
	CONTACTOR		MOTORIZED OPPOSED BLADE DAMPER
	RELAY		MOTORIZED BUTTERFLY BLADE DAMPER
	SPACE TEMPERATURE SENSOR		SUPPLY, RETURN, OR EXHAUST FAN
	LINE VOLTAGE THERMOSTAT		AIRFLOW DIRECTION
	HAND-OFF-AUTOMATIC SWITCH		CONTROL POINT INDICATOR INPUT OR OUTPUT (ANALOG INPUT)
	DUCT-MOUNTED SMOKE DETECTOR		CONTROL POINT INDICATOR DEVICE TYPE (AIR TEMPERATURE SENSOR WITH AVERAGING ELEMENT)
	TRANSFORMER		CONTROL POINT INDICATOR INPUT OR OUTPUT (ANALOG INPUT)
	FUSE		CONTROL POINT INDICATOR DEVICE TYPE (WATER TEMPERATURE SENSOR WITH BULB TYPE ELEMENT IN PIPING WELL)
			CONTROL POINT INDICATOR INPUT OR OUTPUT (ANALOG INPUT)
			CONTROL POINT INDICATOR DEVICE TYPE (CURRENT SENSING RELAY)

ABBREVIATIONS	
A	AMPERE(S)
AD	ACCESS DOOR
AFF	ABOVE FINISHED FLOOR
ALT	ALTERNATE
APD	AIR PRESSURE DROP
BHP	BRAKE HORSEPOWER
BTUH	BRITISH THERMAL UNITS PER HOUR
CFM	CUBIC FEET PER MINUTE
CHWR	CHILLED WATER RETURN
CHWS	CHILLED WATER SUPPLY
CLG	COOLING
COM	COMMON
CWR	CONDENSER WATER RETURN
CWS	CONDENSER WATER SUPPLY
D	DRAIN
DB	DRY BULB TEMPERATURE
dBA	A-WEIGHTED DECIBELS
DCW	DOMESTIC COLD WATER
DIA	DIAMETER
DN	DOWN
DWG	DRAWING
EA	EXHAUST AIR
EAT	ENTERING AIR TEMPERATURE
EER	ENERGY EFFICIENCY RATIO
EQUAL	EQUAL
ESP	EXTERNAL STATIC PRESSURE
EWI	ENTERING WATER TEMPERATURE
EX	EXISTING
F	DEGREES FAHRENHEIT
FC	FAIL CLOSED
FD	FIRE DAMPER
FLA	FULL LOAD AMPS
FO	FAIL OPEN
FO	FEET PER MINUTE
FT	FOOT, FEET
GA	GAUGE
GAL	GALLON(S)
GPH	GALLONS PER HOUR
GPM	GALLONS PER MINUTE
HP	HORSEPOWER
HPWR	HEAT PUMP WATER RETURN
HPWS	HEAT PUMP WATER SUPPLY
HTG	HEATING
HWR	HOT WATER RETURN
HWS	HOT WATER SUPPLY
HX	HEAT EXCHANGER
HZ	HERTZ
IN	INCH
INLV	INTEGRATED PART-LOAD VALVE
KW	KILOWATT(S)
LAT	LEAVING AIR TEMPERATURE
LBS	POUNDS
LWT	LEAVING WATER TEMPERATURE
MAX	MAXIMUM
MBH	ONE THOUSAND BTUH
MCA	MINIMUM CIRCUIT AMPACITY
MFR	MANUFACTURER
MIN	MINIMUM
MOCP	MAXIMUM OVERCURRENT PROTECTION
MOD	MOTOR-OPERATED DAMPER
NC	NORMALLY CLOSED (FOR PLANS, DETAILS)
NC	NOISE CRITERIA (FOR SCHEDULES)
NC	NOT IN CONTRACT
NO	NORMALLY OPEN
OA	OUTSIDE AIR
OC	ON CENTER
OFCI	OWNER FURNISHED CONTRACTOR INSTALLED
PH	PHASE
PSIG	POUNDS PER SQUARE INCH GAUGE
RA	RETURN AIR
RD	REFRIGERANT DISCHARGE
RH	RELATIVE HUMIDITY
RL	REFRIGERANT LIQUID
RPM	REVOLUTIONS PER MINUTE
RS	REFRIGERANT SUCTION
SA	SUPPLY AIR
SEER	SEASONAL ENERGY EFFICIENCY RATIO
TD	TRANSFER DUCT
TYP	TYPICAL
UNO	UNLESS NOTED (INDICATED) OTHERWISE
V	VOLTAGE, VOLTS
VD	VOLUME DAMPER
VFD	VARIABLE-FREQUENCY DRIVE
VIF	VERIFY IN FIELD
W	WATT(S)
W	WITH
WO	WITHOUT
WB	WET BULB TEMPERATURE
WC	WATER COLUMN
WPD	WATER PRESSURE DROP
WWM	WELDED WIRE MESH

GRAPHIC SYMBOL LEGEND	
	SPACE TAG SPACE NAME SPACE NUMBER BUILDING "PART" NUMBER IN MULTI-PART BUILDING
	EQUIPMENT TAG EQUIPMENT NUMBER EQUIPMENT ABBREVIATION
	DIFFUSER, GRILLE OR REGISTER TAG TAG, REFER TO DIFFUSER, GRILLE AND REGISTER SCHEDULE
	DETAIL TAG DETAIL NUMBER DRAWING WHERE DETAIL IS INDICATED
	KEYNOTE
	STRUCTURAL GRID LINE WITH DESIGNATION
	EXISTING TO BE REMOVED
	SECTION TITLE SECTION NUMBER DRAWING WHERE SECTION IS INDICATED DRAWING WHERE SECTION IS REFERENCED ADDITIONAL DRAWING REFERENCES
	SECTION CALLOUT SECTION NUMBER DRAWING WHERE SECTION IS INDICATED
	ENLARGED PLAN CALLOUT ENLARGED PLAN NUMBER DRAWING WHERE ENLARGED PLAN IS INDICATED
	MECHANICAL EQUIPMENT WITH REQUIRED SERVICE CLEARANCE INDICATED

DUCTWORK LEGEND	
	RECTANGULAR DUCT (FIRST DIMENSION REFERS TO SIDE VIEWED)
	ROUND DUCT SIZE
	FLAT OVAL DUCT SIZE
	DOUBLE WALL, EXPOSED DUCT
	FABRIC DUCT
	FLEXIBLE DUCTWORK
	FLEXIBLE CONNECTOR
	DUCT-MOUNTED SMOKE DETECTOR
	DUCT WITH DUCT LINER
	DUCT ACCESS DOOR
	DUCT WITH END CAP
	LINEAR SLOT DIFFUSER, LENGTH AS INDICATED
	LINEAR BAR GRILLE, LENGTH AS INDICATED
	SUPPLY DIFFUSER
	RETURN OR EXHAUST GRILLE
	SUPPLY DIFFUSER WITH DIRECTIONAL BLOW, SOLID HATCH INDICATES BLANK OFF PANEL
	POINT OF CONNECTION TO EXISTING
	LIMIT OF DEMOLITION
	SUPPLY AIRFLOW ARROW
	RETURN OR EXHAUST AIRFLOW ARROW
	DOOR UNDERCUT
	DOOR LOUVER
	SENSOR WELL
	MANUAL BALANCING DAMPER IN DUCT
	FIRE DAMPER IN DUCT
	SMOKE DAMPER IN DUCT
	COMBINATION FIRE/SMOKE DAMPER IN DUCT
	FIRE DAMPER WITH SECURITY BARS IN DUCT
	SMOKE DAMPER WITH SECURITY BARS IN DUCT
	COMBINATION FIRE/SMOKE DAMPER WITH SECURITY BARS IN DUCT
	MOTORIZED DAMPER IN DUCT
	SMOKE CONTROL MANUAL BALANCING DAMPER IN DUCT
	SMOKE CONTROL MOTORIZED DAMPER IN DUCT
	SECURITY BARS IN DUCT
	DUCT WITH ACCESS PANEL
	SUPPLY/MAKEUP AIR DUCT SECTIONS
	RETURN AIR DUCT SECTIONS
	EXHAUST AIR DUCT SECTIONS
	SMOKE DETECTOR
	HUMIDITY SENSOR
	THERMOSTAT, LINE VOLTAGE
	THERMOSTAT, LOW VOLTAGE
	TEMPERATURE SENSOR
	CARBON DIOXIDE SENSOR
	CARBON MONOXIDE SENSOR

PIPING LEGEND	
	END OF LINE CLEANOUT PLUG
	CLEANOUT PLUG
	PRESSURE GAUGE WITH GAUGE COCK
	LIQUID FILLED THERMOMETER
	UNION
	STRAINER WITH BLOWDOWN VALVE AND 3/4" HOSE END CONNECTION
	FLEXIBLE PIPE CONNECTOR
	MANUAL AIR VENT
	VALVE
	MANUAL BALANCING VALVE WITH FLOW TAPS
	AUTOMATIC BALANCING VALVE WITH FLOW TAPS
	SWING CHECK VALVE
	PRESSURE REDUCING VALVE
	TRIPLE DUTY VALVE
	GAS COCK
	PRESSURE-RELIEF VALVE
	TWO-WAY CONTROL VALVE
	THREE-WAY CONTROL VALVE
	DIRECTION OF FLOW

GENERAL NOTES	
A. THE CONTRACT DOCUMENTS ARE COMPLEMENTARY AND WHAT IS REQUIRED BY ONE SHALL BE AS BINDING AS IF REQUIRED BY ALL. IN THE CASE OF A CONFLICT, DISAGREEMENT, OR AMBIGUITY, PROVIDE THE BETTER QUALITY. IN THE CASE OF A CONFLICT, DISAGREEMENT, OR AMBIGUITY, PROVIDE THE GREATER QUANTITY OF WORK.	G. PROVIDE TRAPPED DRAIN PIPING FROM DRAIN PANS OF ALL COOLING COILS, FANS AND OTHER ACTIVE DRAINS EXPOSED TO SYSTEM AIRSTREAM. PROVIDE TRAP AT CONNECTION WITH WATER SEAL, DEPTH ONE INCH GREATER THAN UNIT OPERATING PRESSURE. DIRECT DRAINS TO NEAREST FLOOR DRAIN, MOP SINK, OR OTHER LOCATION APPROVED BY THE ARCHITECT.
B. DRAWINGS ARE DIAGRAMMATIC AND INTENDED TO CONVEY SCOPE AND GENERAL ARRANGEMENT ONLY. DO NOT SCALE DRAWINGS. LOCATIONS OF ALL ITEMS INDICATED ON THE DRAWINGS OR CALLED FOR IN THE SPECIFICATIONS THAT ARE NOT DEFINITELY FIXED BY DIMENSIONS ARE APPROXIMATE. COORDINATE CONTRACT DOCUMENTS PROJECT REQUIREMENTS, WORK OF OTHERS, AND EQUIPMENT AND MATERIALS PURCHASED WITH FIELD DIMENSIONS. MANUFACTURER'S REQUIREMENTS FOR INSTALLATION, OPERATION, AND MAINTENANCE. CONTRACTOR'S INTENDED MEANS AND METHODS OF INSTALLATION, AND CONTRACTOR'S FABRICATED ITEMS TO ENSURE A PROPER FIT AND INSTALLATION.	H. INSTALL PIPING, DUCTWORK, AND CONDUIT CONCEALED IN AREAS HAVING CEILINGS AND/OR FURRED SPACES UNLESS OTHERWISE INDICATED.
C. MAINTAIN MAXIMUM HEADROOM AND SPACE CONDITIONS AT ALL POINTS, WHERE HEADROOM AND SPACE CONDITIONS APPEAR INADEQUATE, NOTIFY THE ARCHITECTS PRIOR TO PROCEEDING WITH INSTALLATION. MAINTAIN A MINIMUM OF 7'-0" CLEARANCE ABOVE FINISHED FLOOR TO UNDERSIDE OF PIPES, DUCTS, CONDUITS, SUSPENDED EQUIPMENT, ETC., THROUGHOUT ACCESS ROUTES IN MECHANICAL ROOMS.	I. ALL EQUIPMENT, VALVES, DAMPERS, DAMPER AND VALVE OPERATORS SHALL BE PROVIDED WITH ADEQUATE ACCESS FOR SERVICING, MAINTENANCE, AND REPLACEMENT.
D. FIELD VERIFY AND COORDINATE ALL DUCT AND PIPING DIMENSIONS BEFORE FABRICATION. MAKE MODIFICATIONS IN THE LAYOUT AS NEEDED TO PREVENT CONFLICT WITH WORK OF OTHER TRADES OR FOR PROPER EXECUTION OF THE WORK.	J. SIZE ALL SPLIT-SYSTEM REFRIGERANT PIPING IN ACCORDANCE WITH THE MANUFACTURER'S INSTALLATION INSTRUCTIONS.
E. INSTALL ALL EQUIPMENT AND APPURTENANCES IN ACCORDANCE WITH MANUFACTURER'S RECOMMENDATIONS, CONTRACT DOCUMENTS, AND APPLICABLE CODES AND REGULATIONS.	K. DUCT DIMENSIONS MAY BE MODIFIED ONLY WITH PRIOR APPROVAL FROM ARCHITECT. DUCT DIMENSIONS ARE IN INCHES AND INSIDE CLEAR.
F. COORDINATE LOCATIONS AND SIZES OF ALL FLOOR, WALL, AND ROOF OPENINGS WITH ALL OTHER TRADES. COORDINATE ALL PIPING AND EQUIPMENT SUPPORTED FROM STRUCTURE WITH GENERAL CONSTRUCTION WORK.	L. FOR LOCATION OF REGISTERS, GRILLES, AND DIFFUSERS WITHIN CEILING GRID, REFER TO ARCHITECTURAL REFLECTED CEILING PLANS.
	M. ELEVATION INDICATED FOR RECTANGULAR DUCT, GRILLE AND LOUVER OPENINGS IS TO THE TOP OF ROUGH OPENING UNLESS OTHERWISE INDICATED. ELEVATION INDICATED FOR ROUND DUCTWORK AND PIPING IS TO CENTERLINE.

GRILLE, REGISTER, & DIFFUSER SCHEDULE						
TAG	MANUFACTURER	MODEL NUMBER	MOUNTING STYLE	NECK SIZE	FACE SIZE	MAX NC LEVEL
FFU-1	PRICE	FFU-FTR	LAY-IN	10w	30x24	30
S1	PRICE	ASCD	SURFACE	6w	12x12	30
S2	PRICE	ASCD	LAY-IN	8w	24x24	30
S3	PRICE	ASCD	SURFACE	8w	12x12	30
S4	PRICE	ASCD	LAY-IN	10w	24x24	30
R1	PRICE	635-F	SURFACE	14w6	16w6	30
R2	PRICE	635-TB	LAY-IN	10x10	12x12	30
R2	PRICE	635-F	SURFACE	10x10	12x12	30
E1	PRICE	635	LAY-IN	10x10	14x14	30



8/15/2025 3:58:05 PM

J
I
H
G
F
E
D
C
B
A


1 2 3 4 5 6 7 8 9 10



FIRST FLOOR PLAN - DEMOLITION
1/8" = 1'-0"

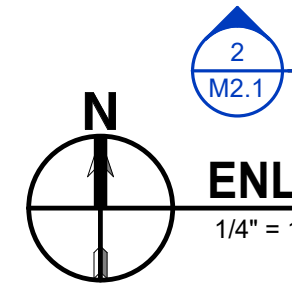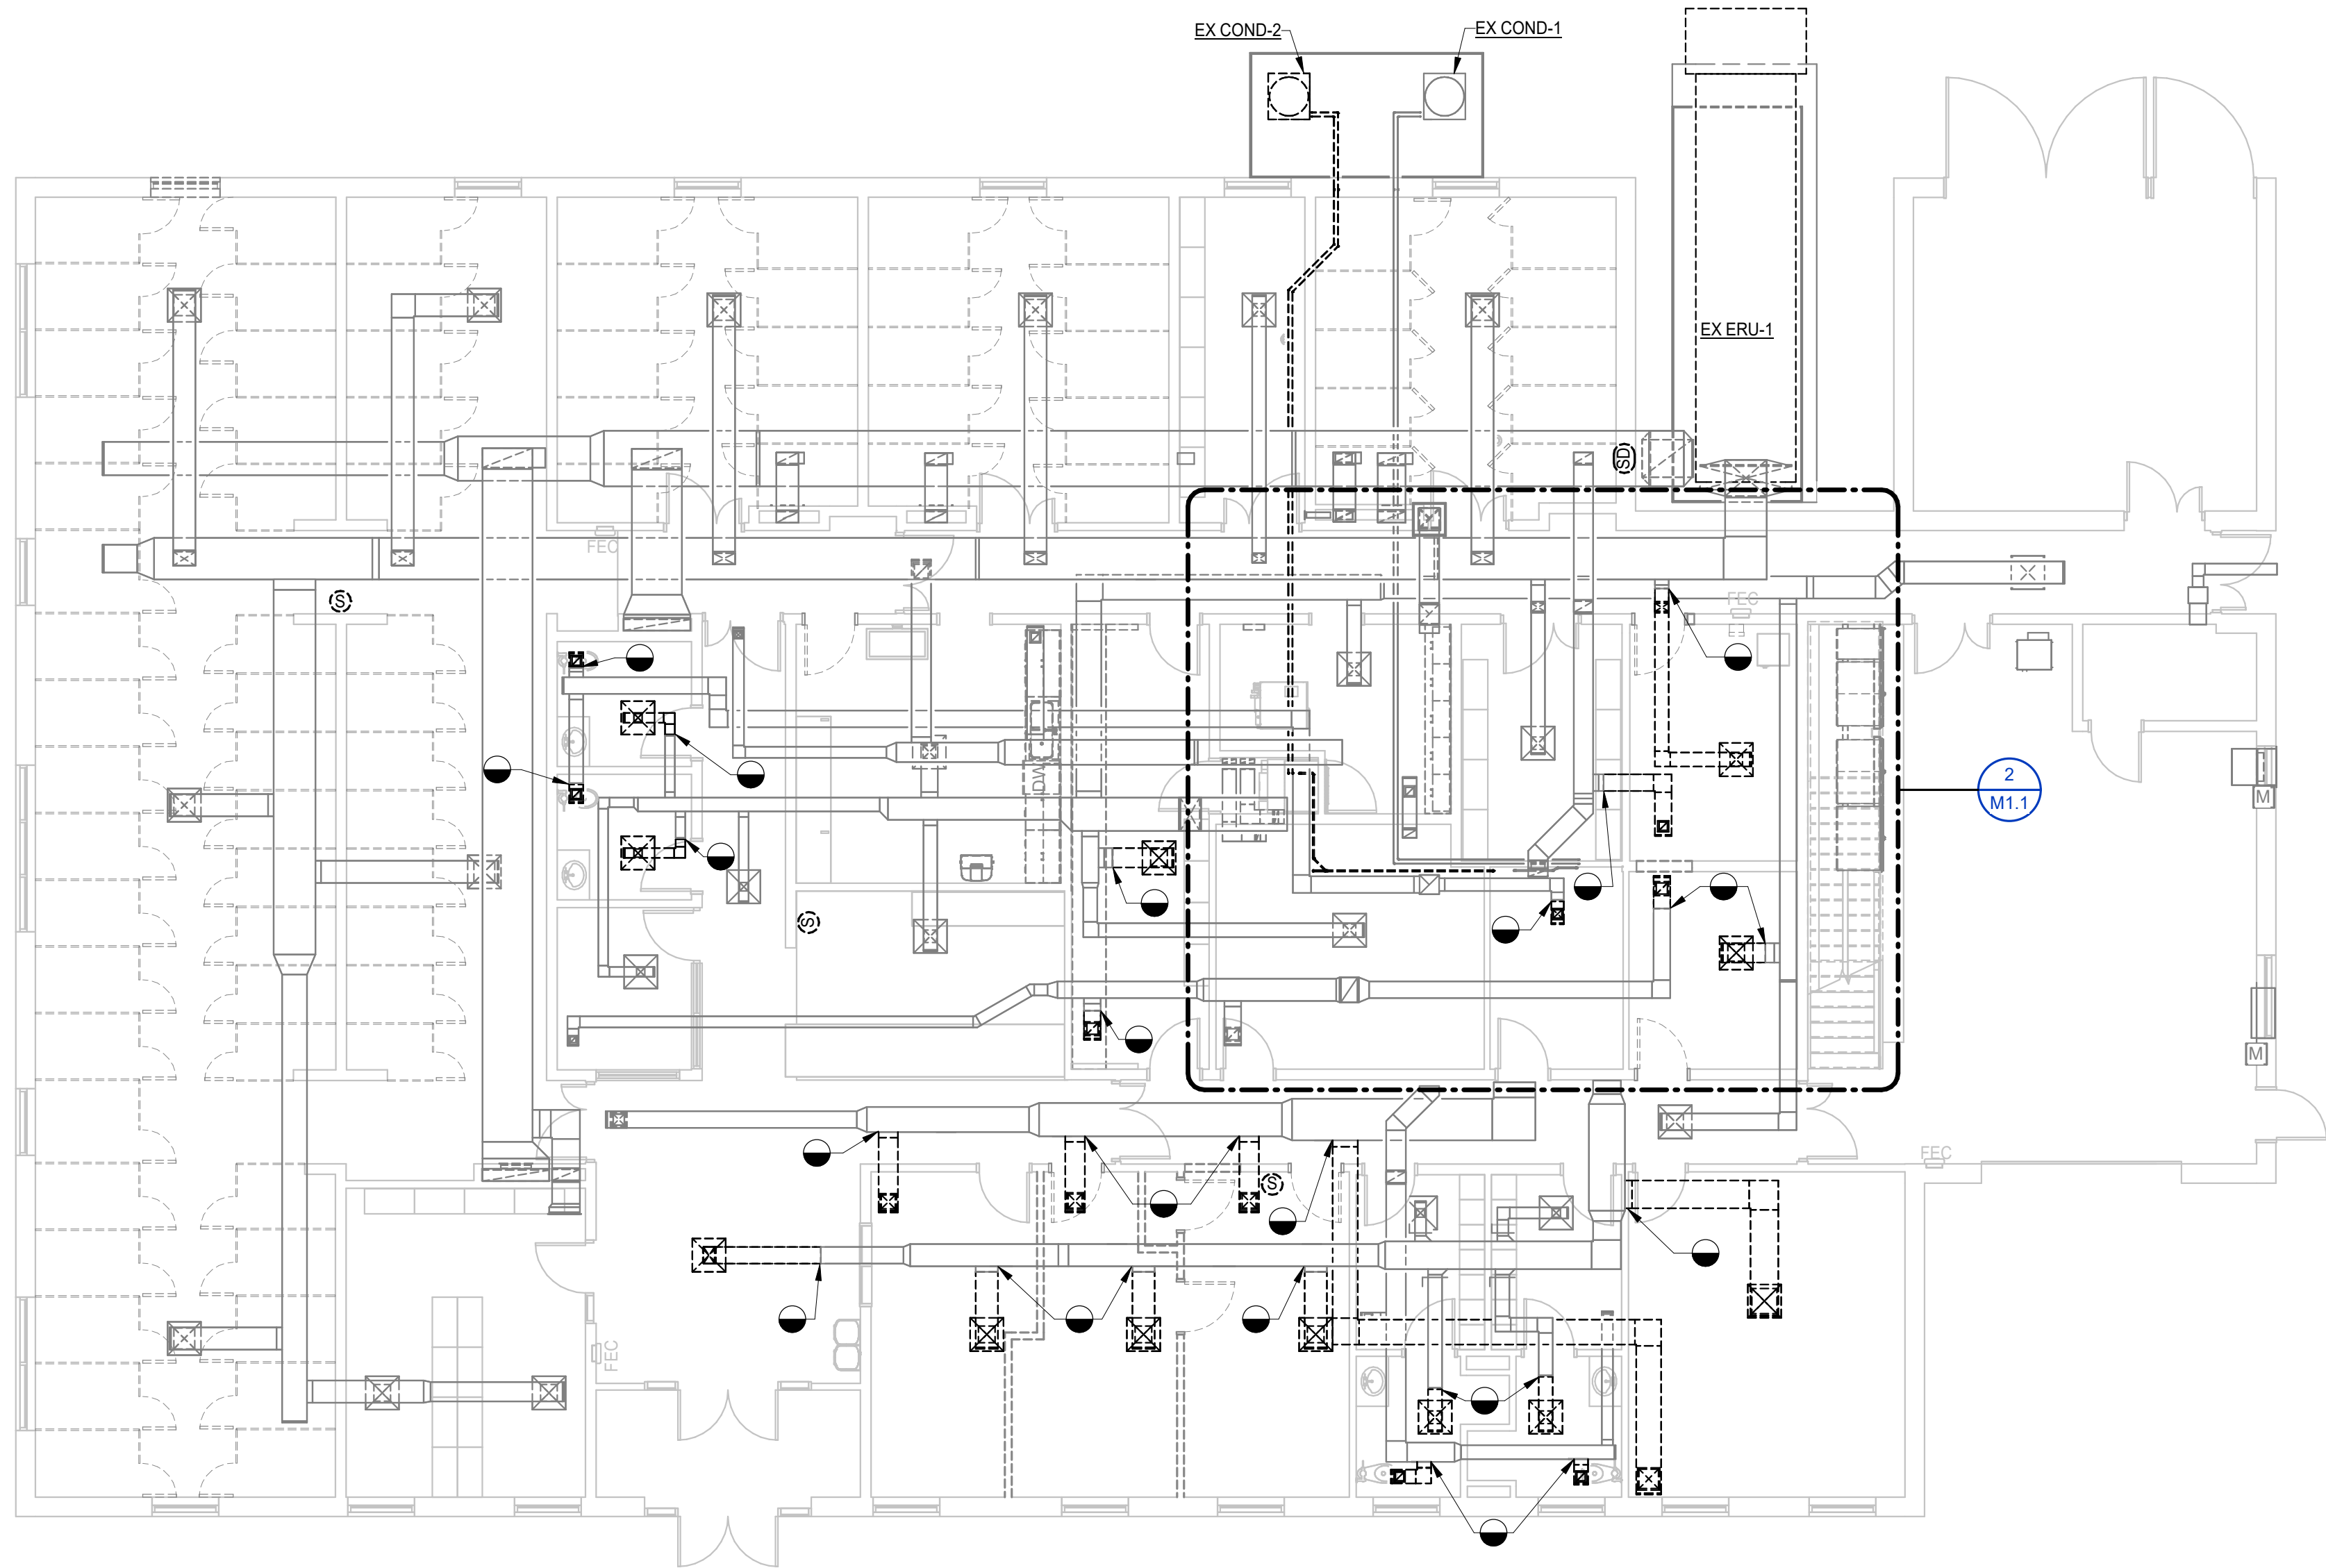


ENLARGED PLAN - MECHANICAL MEZZANINE - DEMOLITION
1/4" = 1'-0"

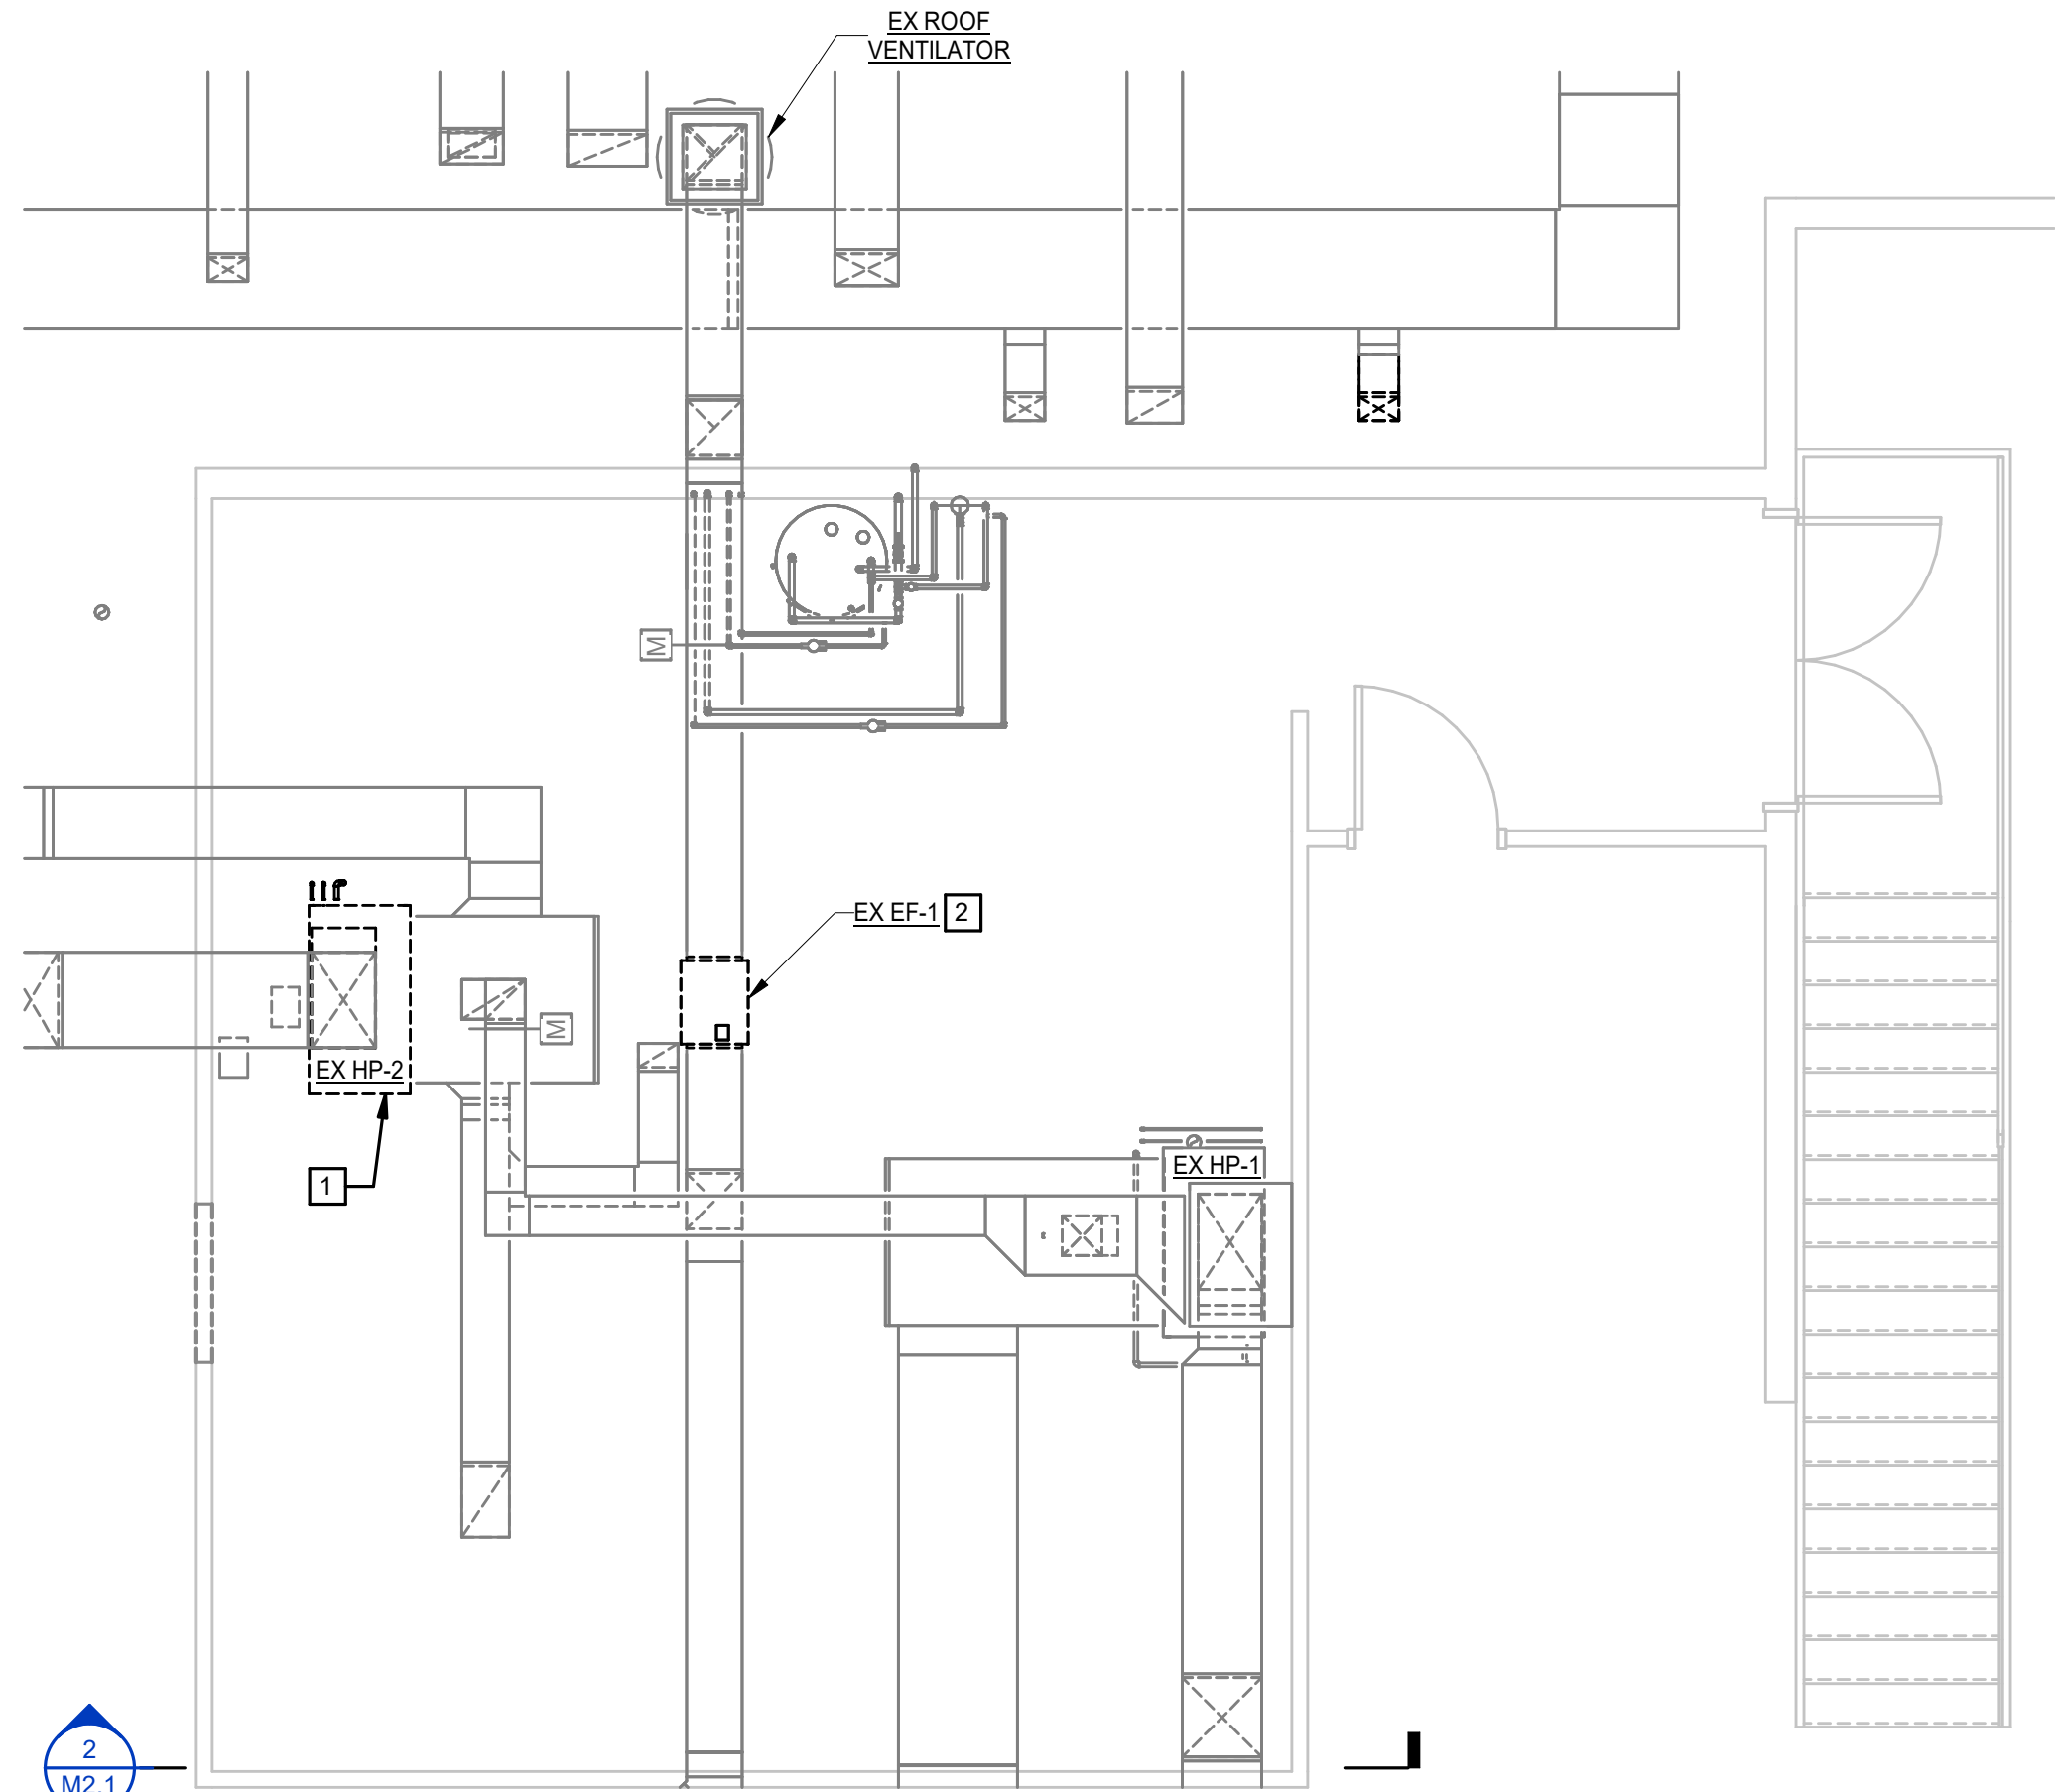

KEYNOTES

APPLIES TO THIS DRAWING

- 1 REMOVE HP-2 AND ALL ASSOCIATED CONTROLS AND PIPING.
- 2 REMOVE EF-1 AND ALL ASSOCIATED CONTROLS.

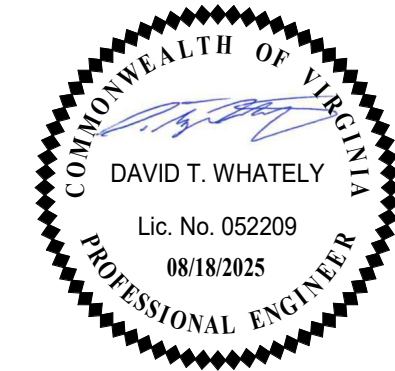


HENRICO ANIMAL SHELTER

10421 WOODMAN ROAD, GLEN ALLEN, VA 23060
HENRICO COUNTY, VA
615225

PROJECT NO:	615225
DATE:	AUGUST 18, 2025
REVISIONS	
DATE	DESCRIPTION

FIRST FLOOR PLAN -
DEMOLITION

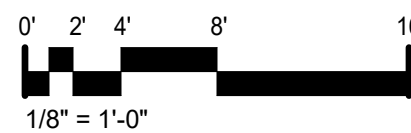


M1.1

MOSELEYARCHITECTS


520 NORFOLK STREET, RICHMOND, VA 23230
PHONE (804) 784-7555 FAX (804) 355-5690
MOSELEYARCHITECTS.COM

FIRST FLOOR PLAN - DUCTWORK
1/8" = 1'-0"

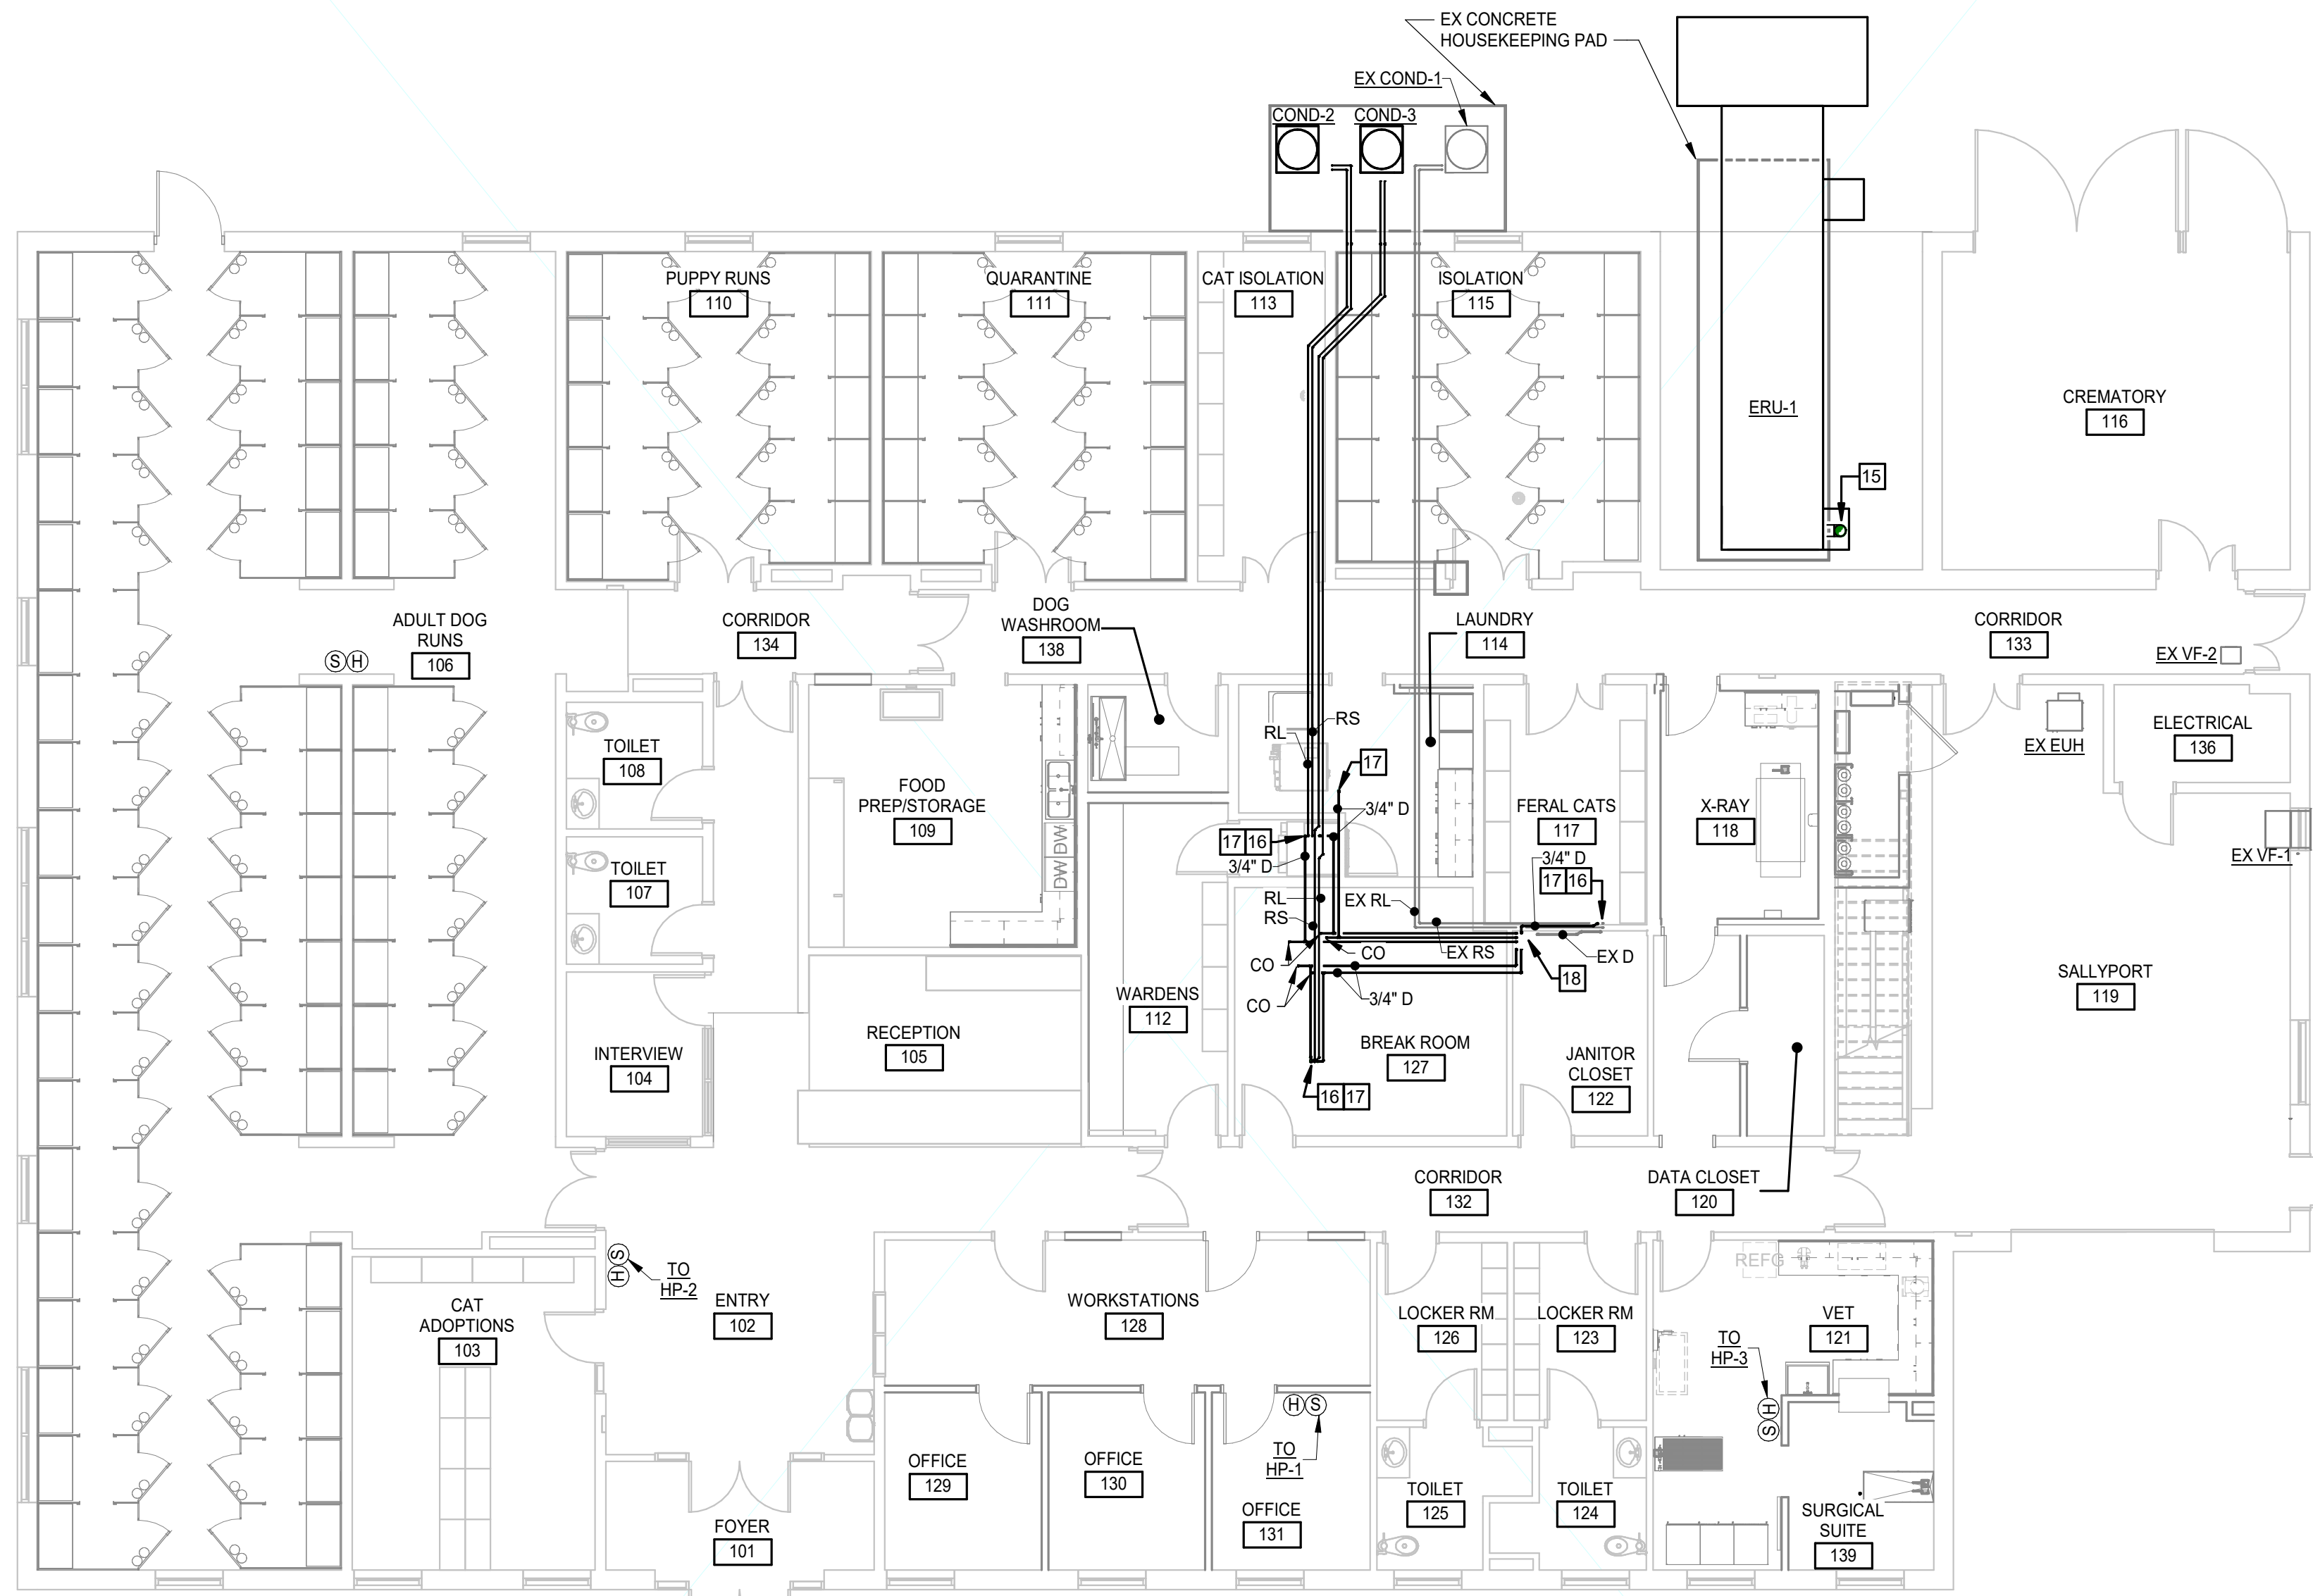


FIRST FLOOR PLAN - PIPING
1/8" = 1'-0"

2 SECTION
1/2" = 1'-0"

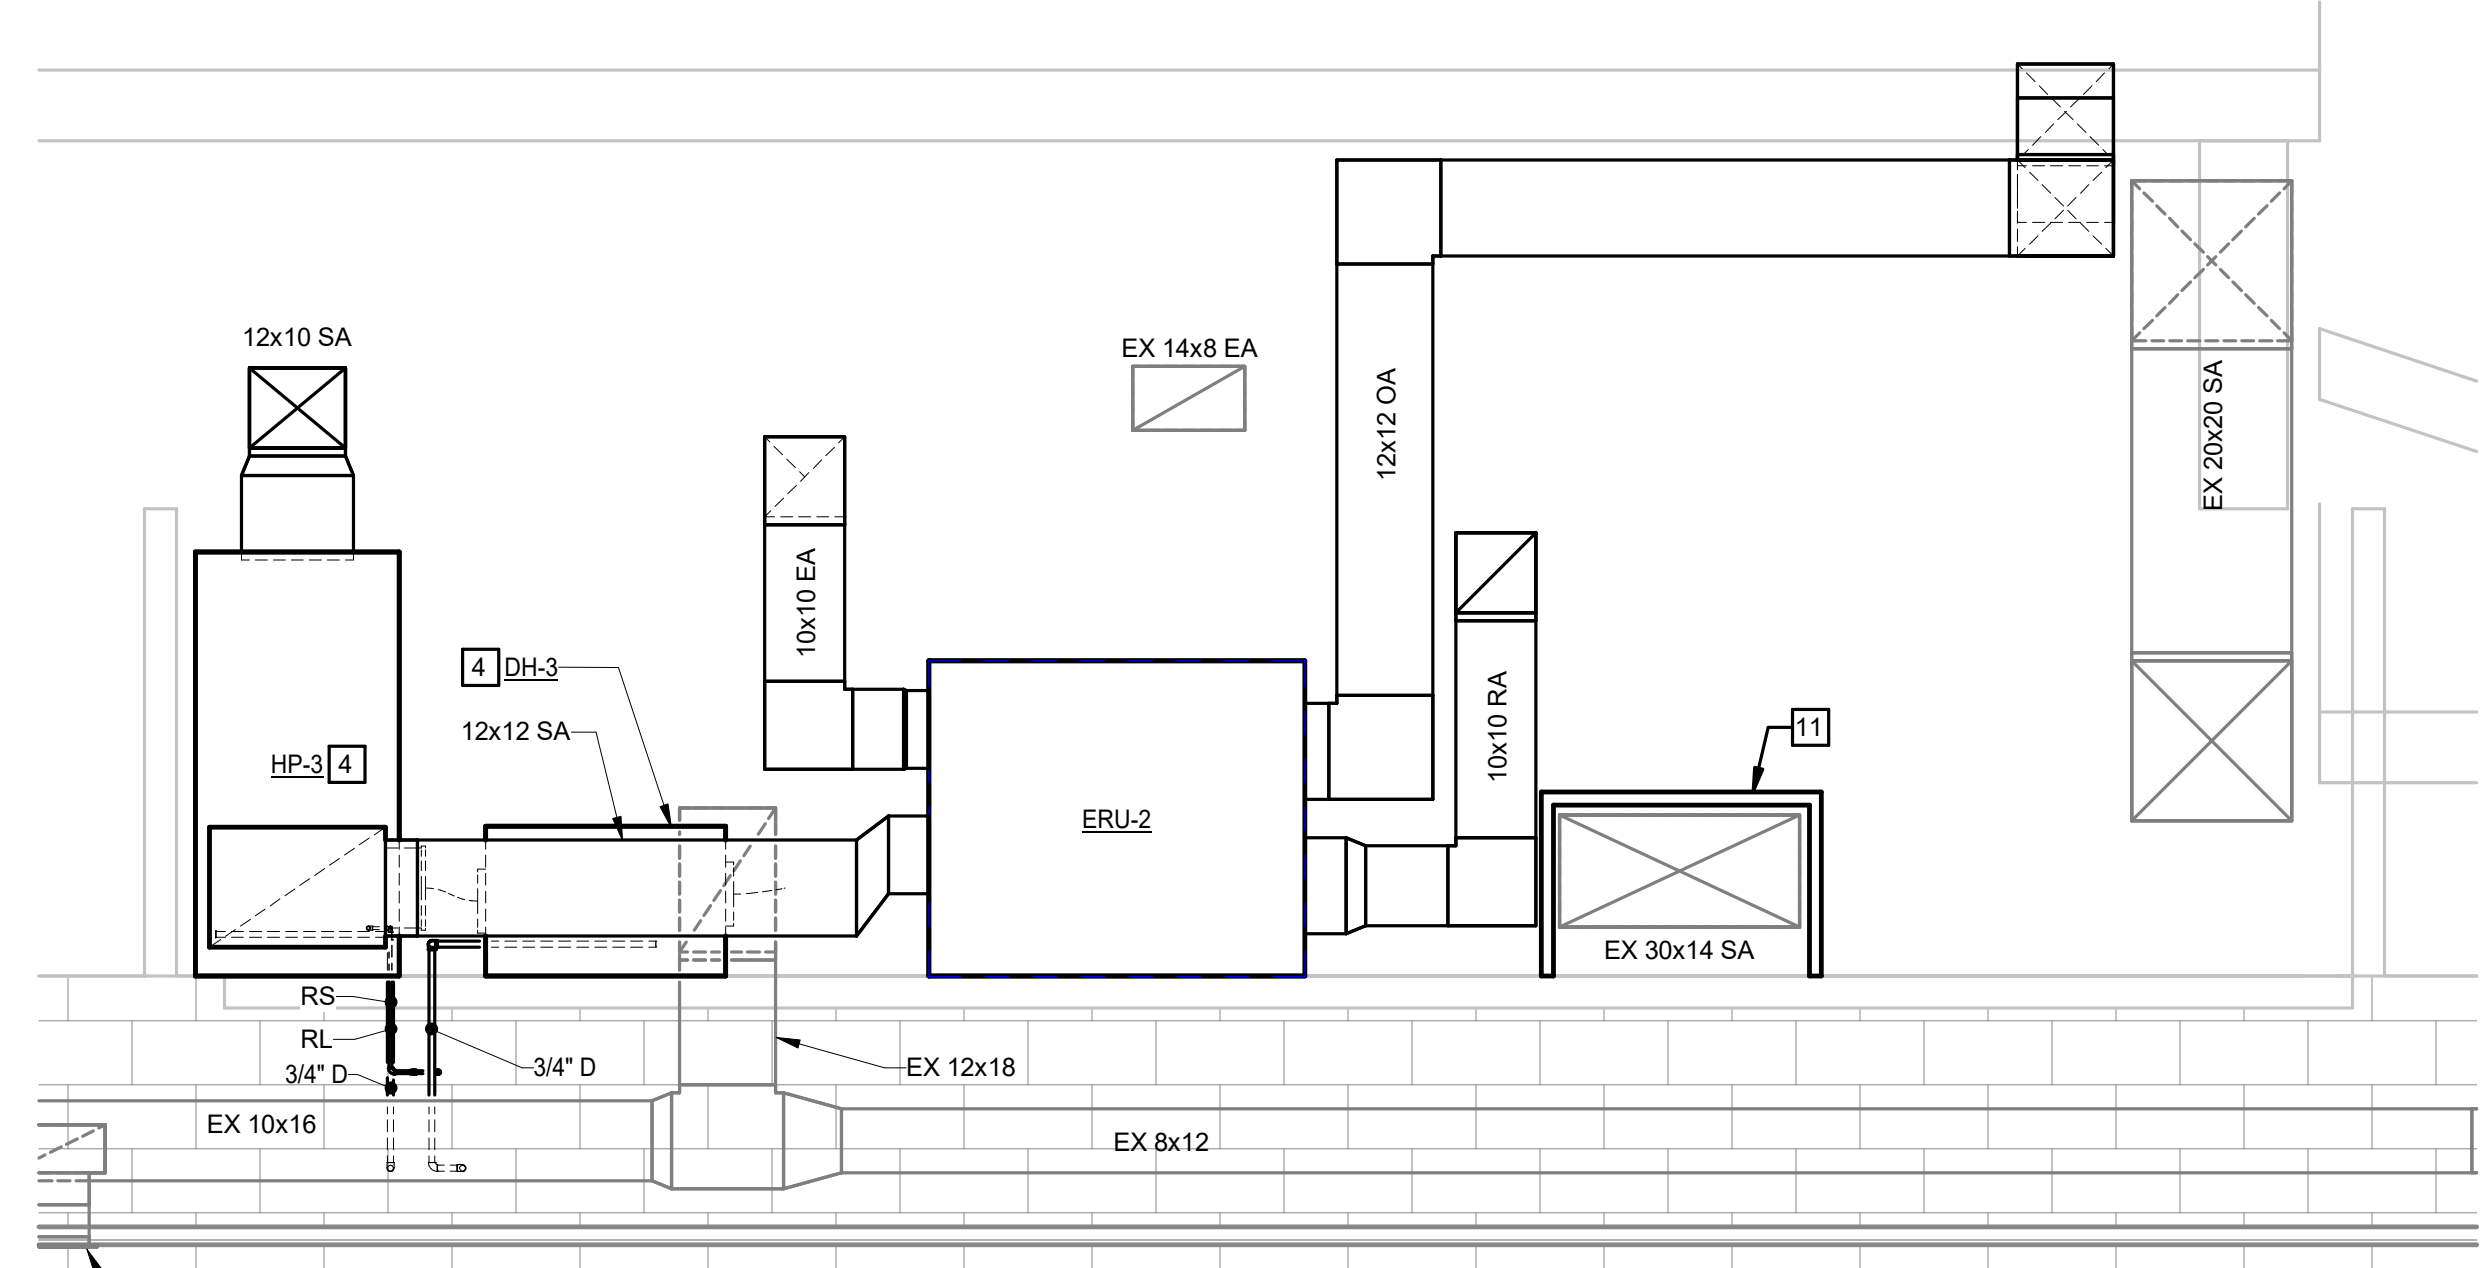

1 ENLARGED PLAN - MECHANICAL MEZZANINE
1/4" = 1'-0"

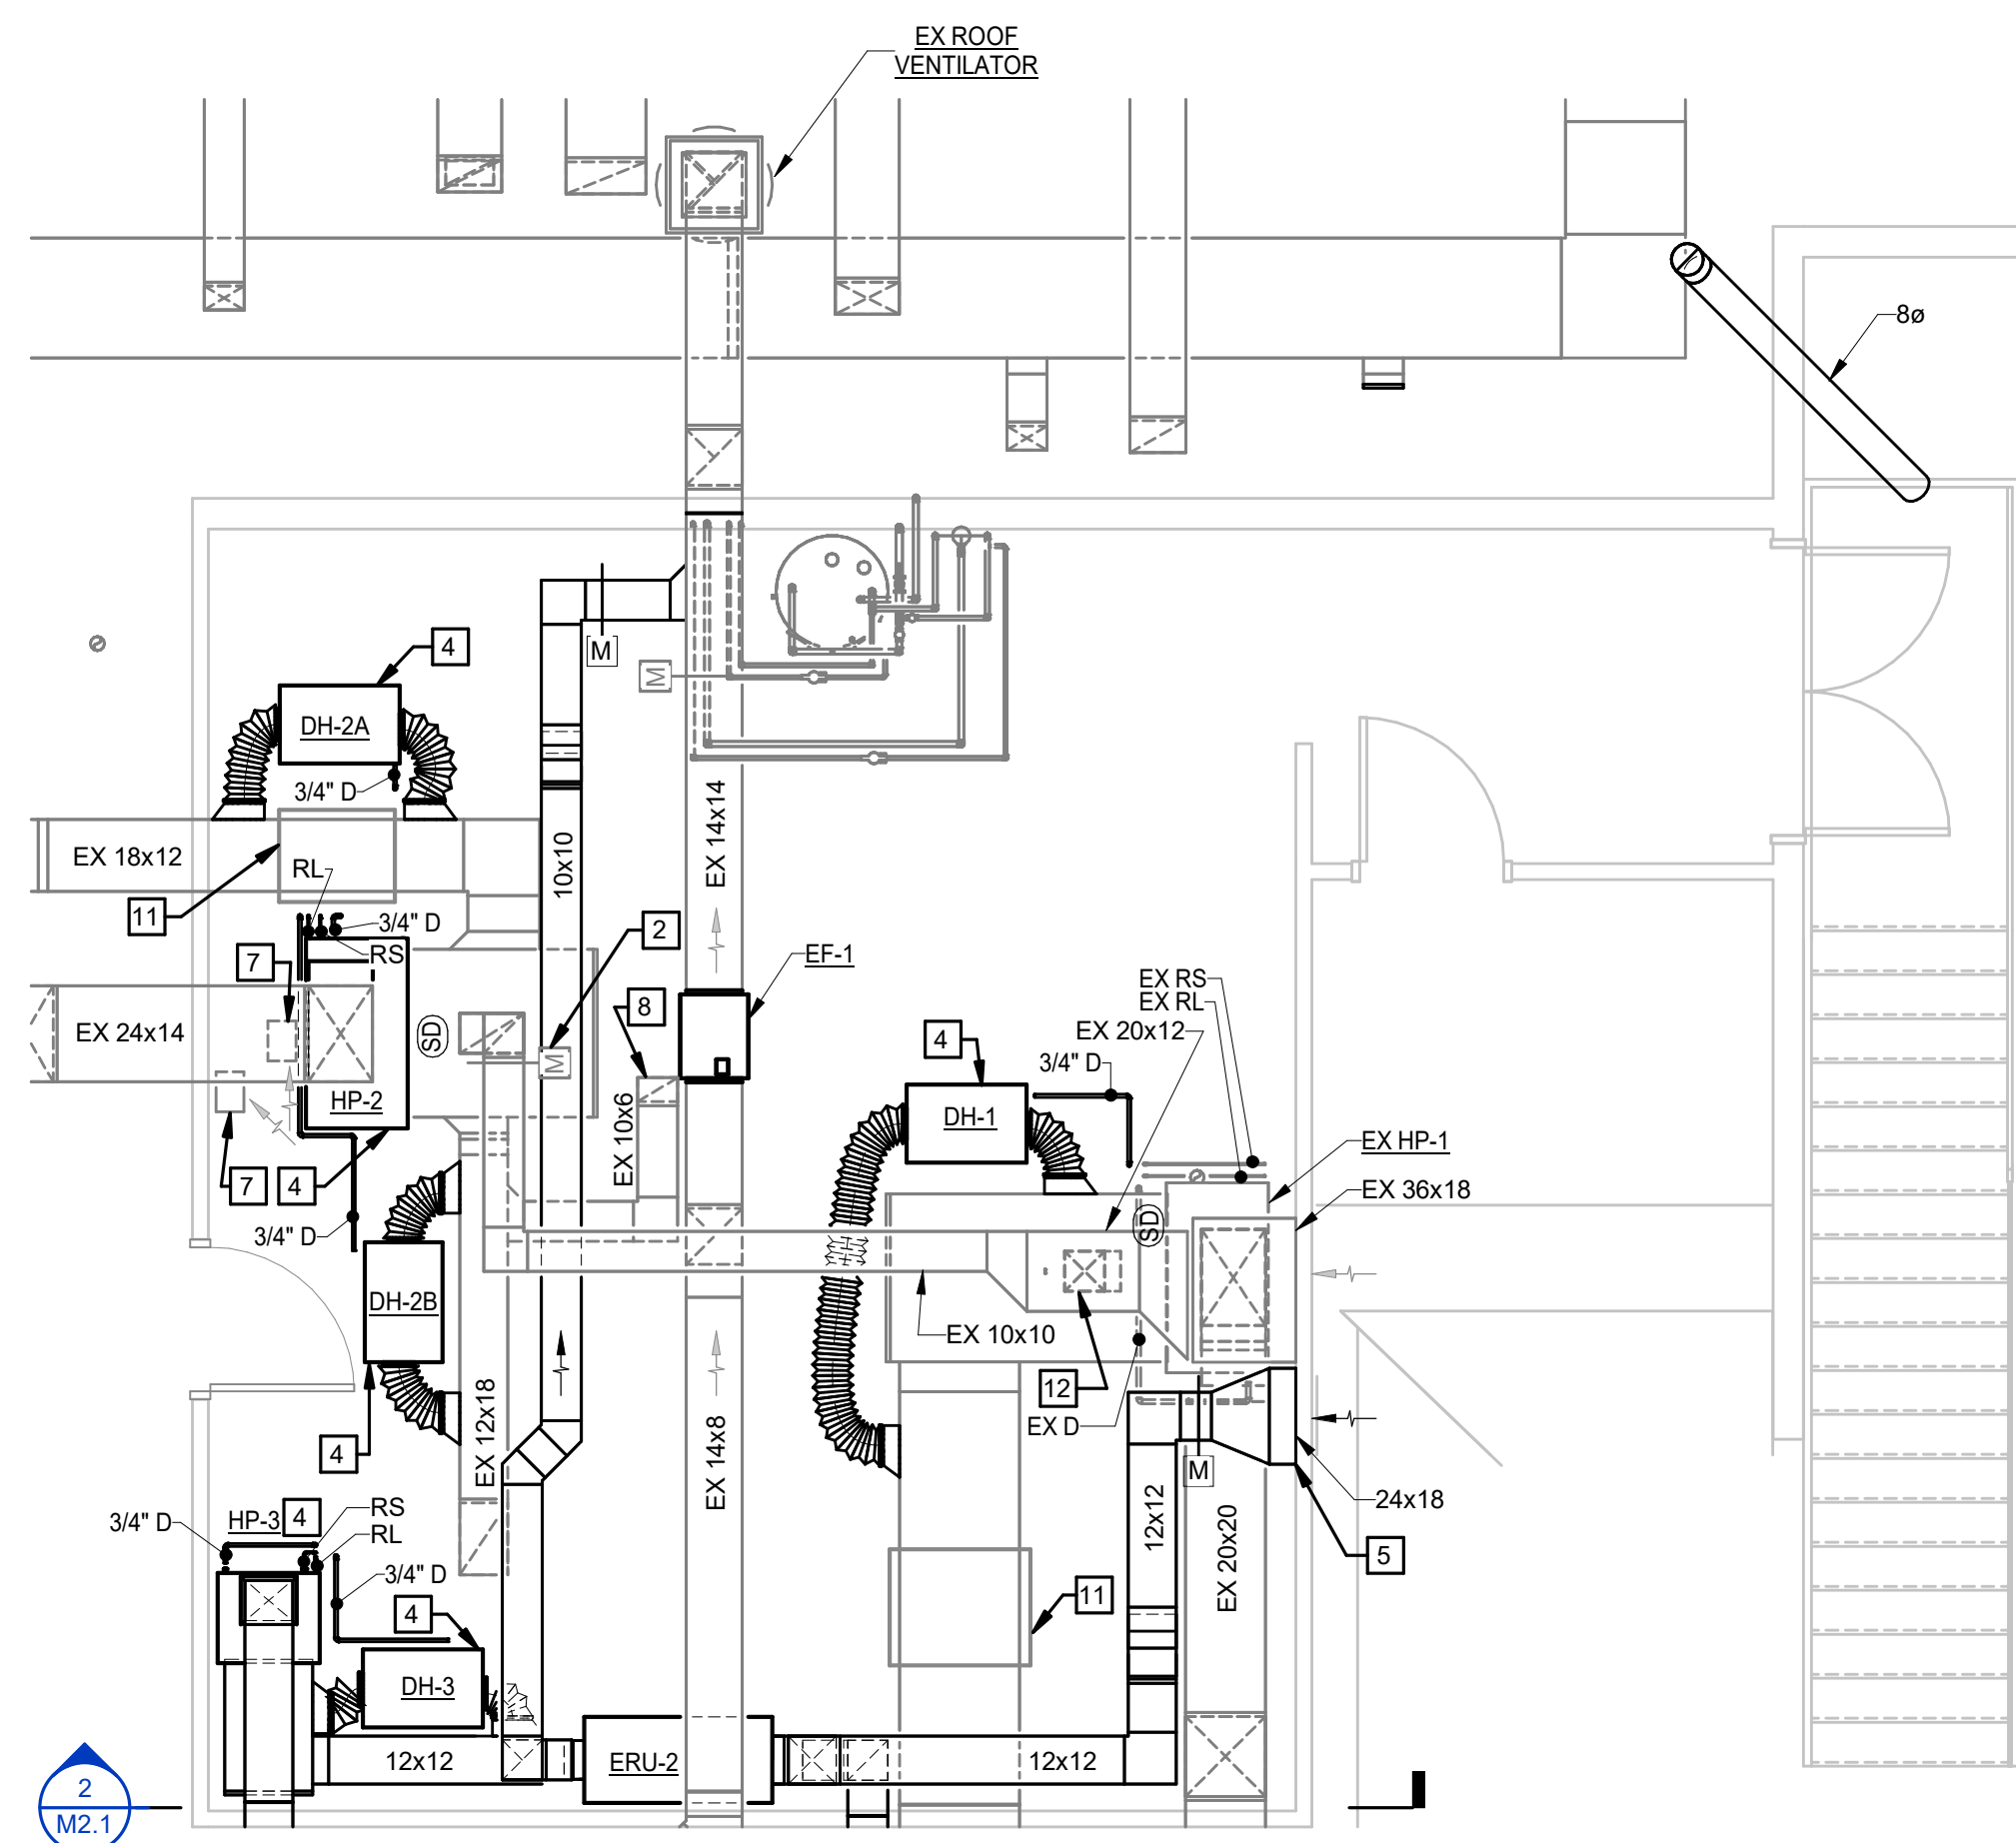

KEYNOTES


APPLIES TO THIS DRAWING

- 1 REBALANCE AIR TERMINAL TO SPECIFIED CFM.
- 2 REPLACE ACTUATOR ON EXISTING-TO-REMAIN MOTORIZED DAMPER AND ADJUST MAXIMUM LIMIT STOP TO BALANCE OUTSIDE AIR. WHERE EX HP-1 WILL BE 430 CFM AND HP-2 WILL BE 370 CFM.
- 3 CAP AND INSULATE DUCT TAP.
- 4 SET DEHUMIDIFIER / HEAT PUMP ON CMU BLOCKS AND PROVIDE AUXILIARY DRAIN PAN UNDERNEATH UNIT WITH CONDENSATE MOISTURE SENSOR INTERLOCKED WITH UNIT.
- 5 CONNECT 24X18 EQUIVALENT FREE AREA TO TRIANGULAR PORTION OF EXISTING OUTDOOR AIR LOUVER.
- 6 PROVIDE UNIT THAT MATCHES EXISTING DUCT CONNECTIONS.
- 7 EXISTING 10X3 MAKEUP AIR DUCT DOWN TO DRYER ROOM.
- 8 EXISTING 10X6 DUCT DOWN TO 114-LAUNDRY.
- 9 EXISTING 14X14 DUCT UP TO MECHANICAL MEZZANINE.
- 10 EXISTING 10X3 MAKEUP AIR DUCT UP TO MECHANICAL MEZZANINE.
- 11 EXISTING TABLE EXTENDING OVER DUCTWORK FOR MAINTENANCE ACCESS.
- 12 REPLACE ACTUATOR ON EXISTING-TO-REMAIN MOTORIZED DAMPER IN THE VERTICAL.
- 13 PROVIDE RISER UNDERNEATH CONDENSING UNIT TO RAISE BY 2.5 INCHES.

KEYNOTES


APPLIES TO THIS DRAWING

- 14 MOUNT DIFFUSER CENTERLINE AT ELEVATION 1'-6" AFF.
- 15 PROVIDE FLUE VENT AND ROUTE THROUGH ROOF LIKE EXISTING. PORTIONS OF FLUE VENT MAY BE REUSED IF SUITABLE BY CUSTOMER. ERU-1 MANUFACTURER AND ANY NEW FLUE VENT PIECES SHALL MATCH SAME MANUFACTURER AS EXISTING FLUE FOR LISTED ASSEMBLY. COORDINATE FLUE VENTING WITH ERU-1 MANUFACTURER.
- 16 REFRIGERANT PIPING UP TO MECHANICAL MEZZANINE.
- 17 CONDENSATE PIPING UP TO MECHANICAL MEZZANINE.
- 18 ROUTE CONDENSATE DRAIN PIPING TO TERMINATE IN MOP SINK IN 122-JANITOR CLOSET.
- 19 EXISTING 10X6 DUCT UP TO MECHANICAL MEZZANINE.
- 20 EXISTING 14X5 DUCT DOWN TO EXISTING WALL-MOUNTED RETURN DIFFUSER IN 117-FERAL CATS.
- 21 EXISTING 14X14 DUCT ROUTED INTO THE MECHANICAL MEZZANINE.
- 22 ERU-1 SHALL CANTILEVER FROM EXISTING CONCRETE HOUSING PAD.
- 23 MANUAL BALANCING DAMPER IN THE VERTICAL.
- 24 TERMINATE TO GOOSENECK ON ROOF.

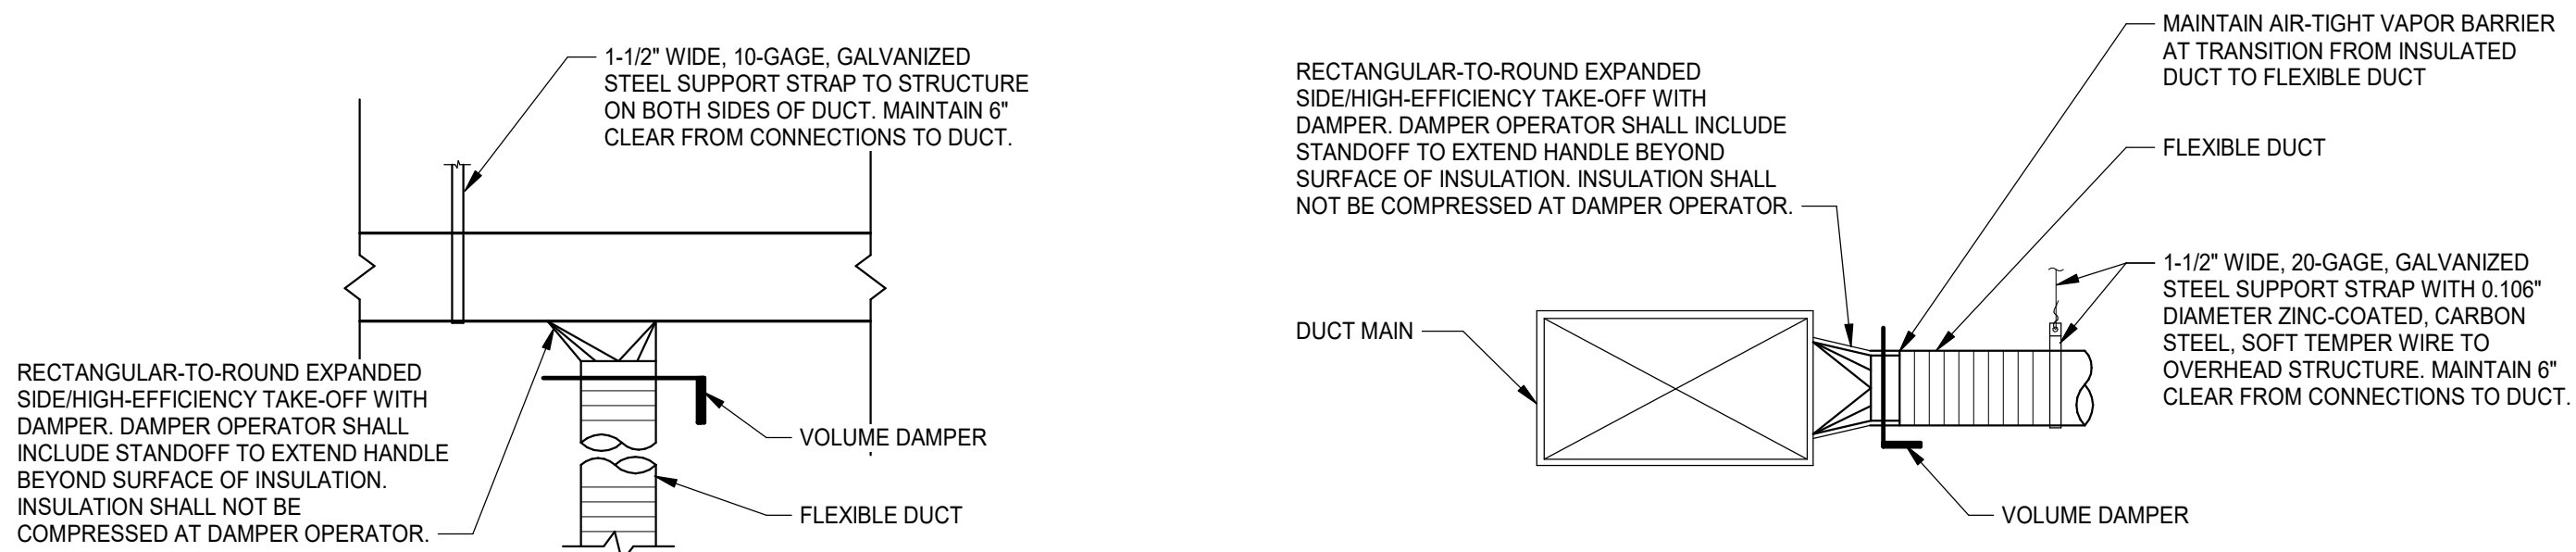


NOTES:
1. FLEXIBLE DUCT SHALL BE INSTALLED OVER METAL DUCT (BEAD/LIP ON METAL DUCT) AND ANCHORED WITH NYLON MECHANICAL BANDS OR PANDUIT STRAP.
2. IN EXPOSED AREAS, PROVIDE RIGID GALVANIZED STEEL BRANCH DUCT TO DIFFUSERS IN LIEU OF FLEXIBLE DUCT UNLESS INDICATED OTHERWISE. SUPPORT IN ACCORDANCE WITH REQUIREMENTS SPECIFIED FOR METAL DUCTS.

BRANCH CONNECTION TO DIFFUSER DETAILS

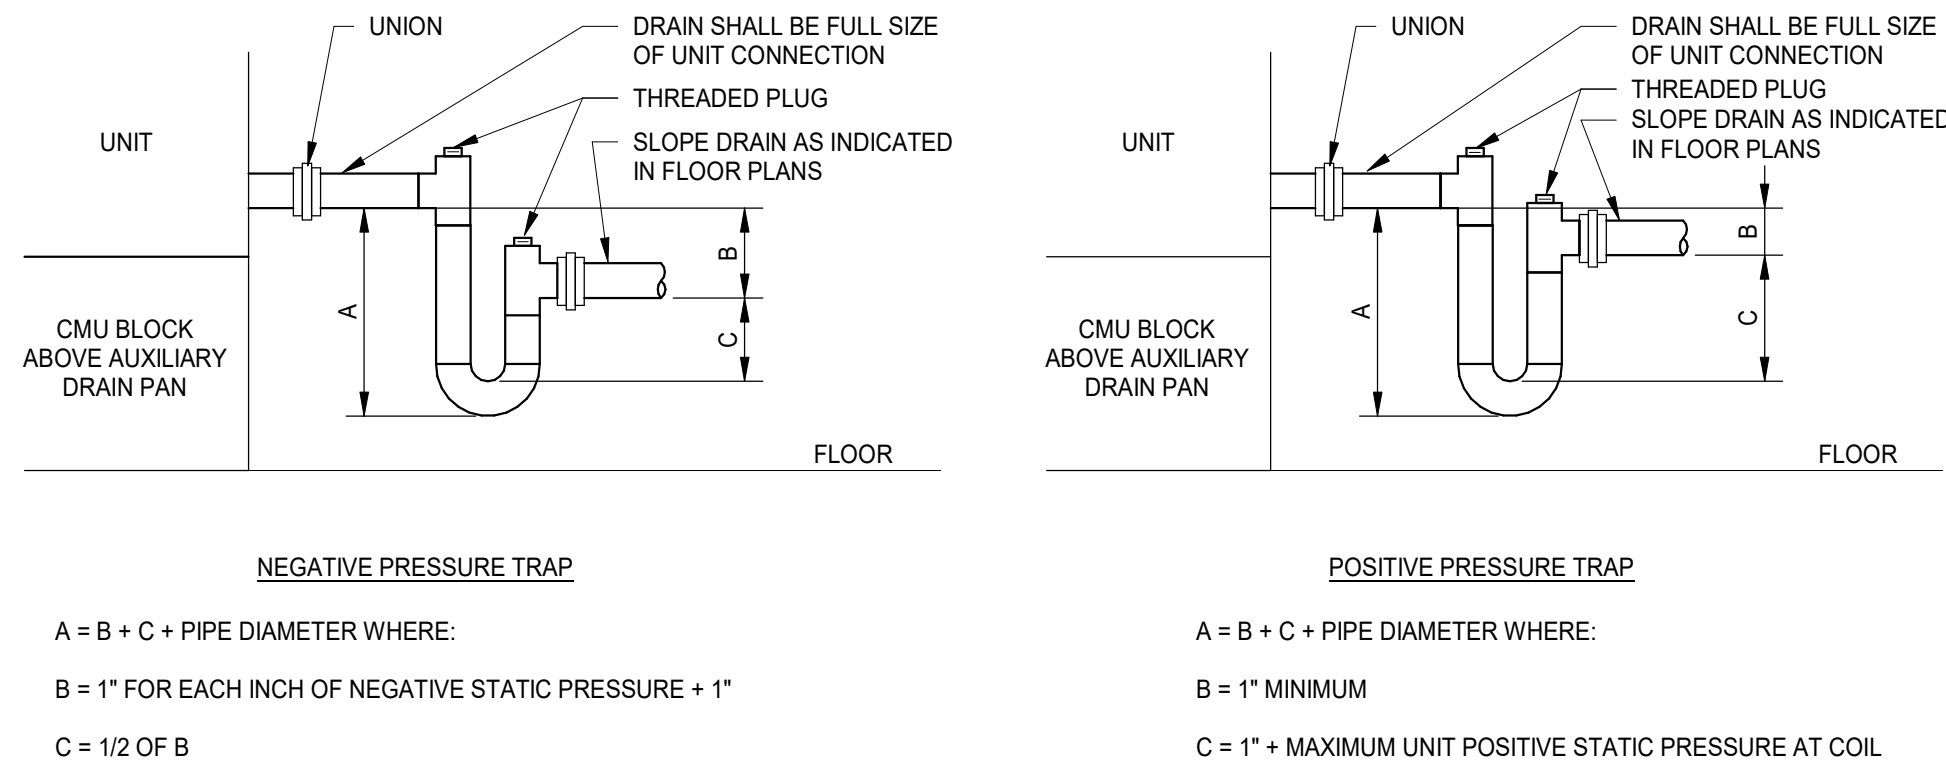


CONDENSATE DRAIN PIPING DETAIL

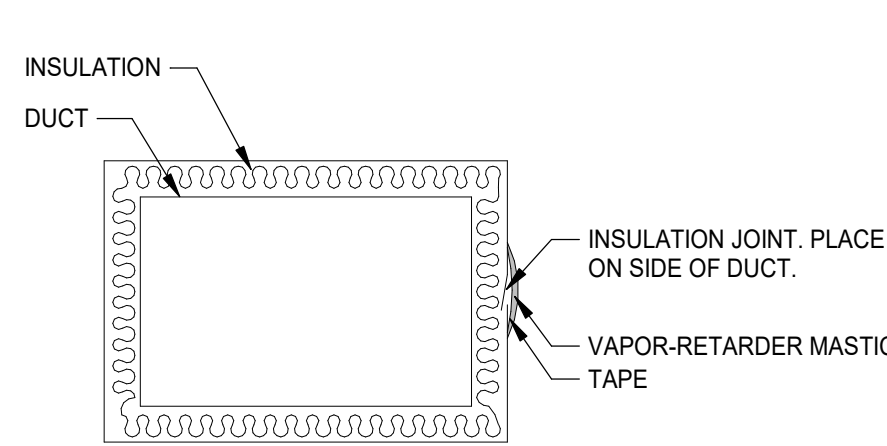


REFER TO SPECIFICATION SECTION 230700 FOR ADDITIONAL INFORMATION.

DUCT INSULATION JOINT DETAIL

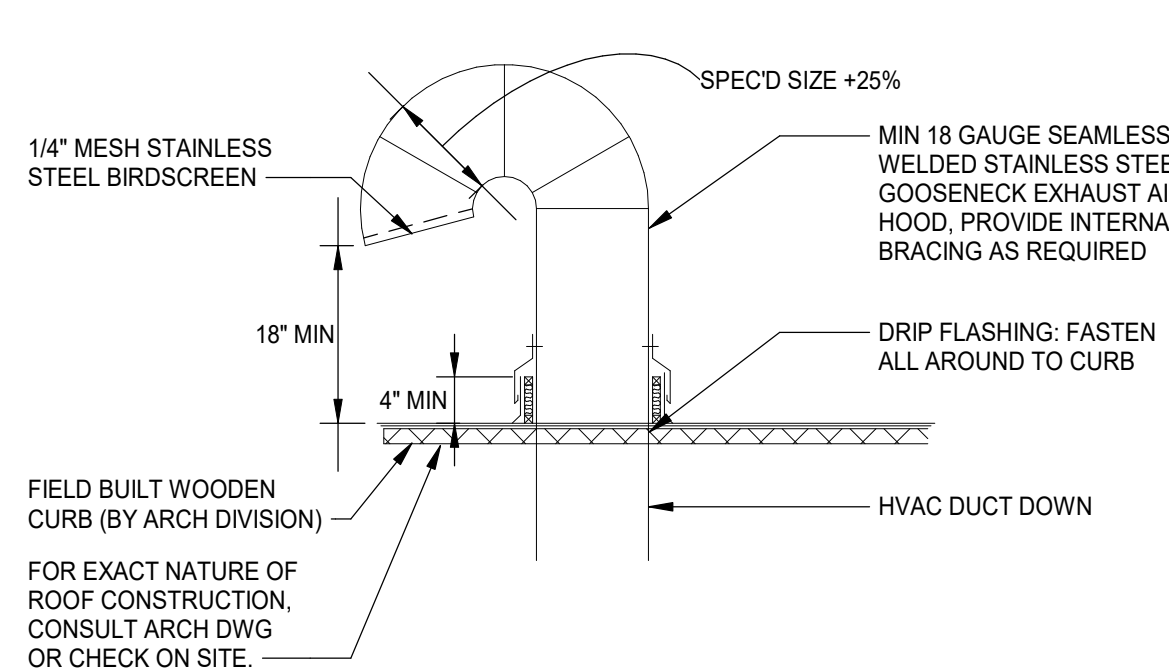


GOOSENECK DETAIL

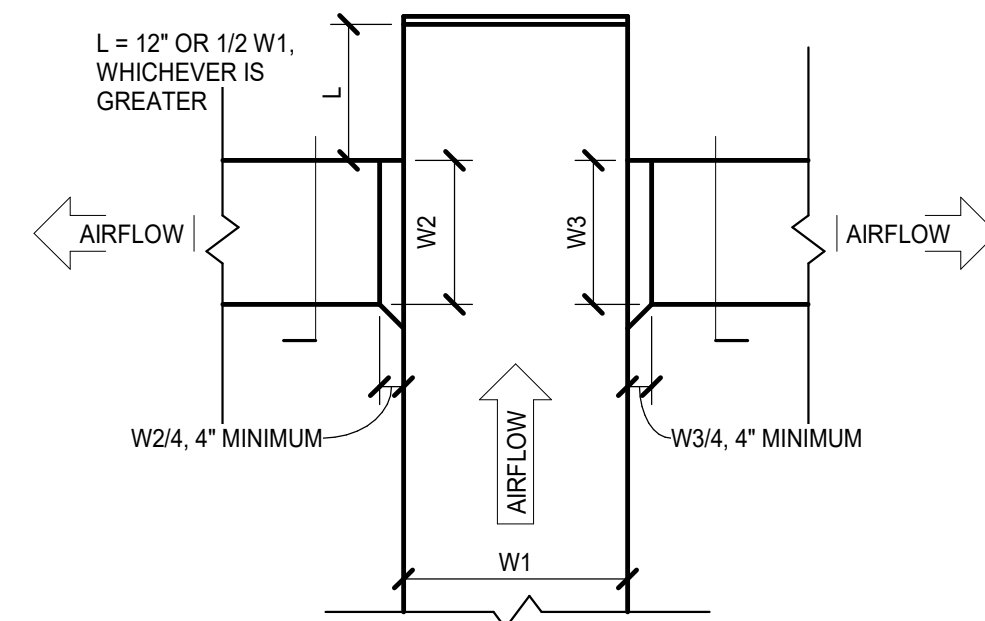


NOTE:
1. REFER TO BRANCH CONNECTION TO DIFFUSER DETAILS FOR BRANCH TAKE-OFF REQUIREMENTS.

END OF DUCT MAIN DETAIL

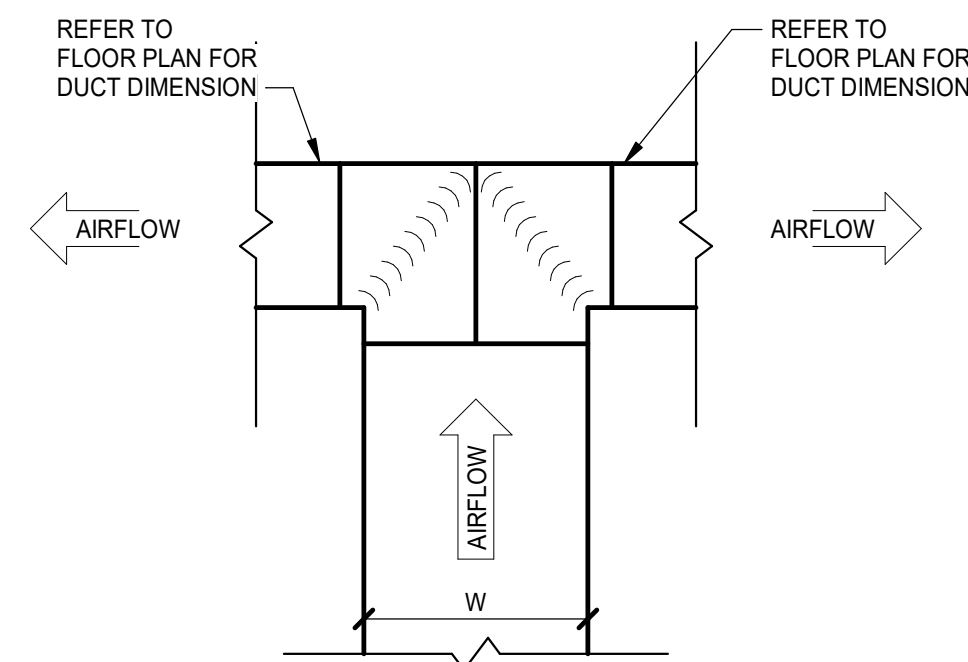


NOTES:
1. APPLIES WHERE "W" EXCEEDS 24" OR WHEN AIRFLOW EXCEEDS 1,500 CFM.


DIVIDED FLOW BRANCH DETAILS

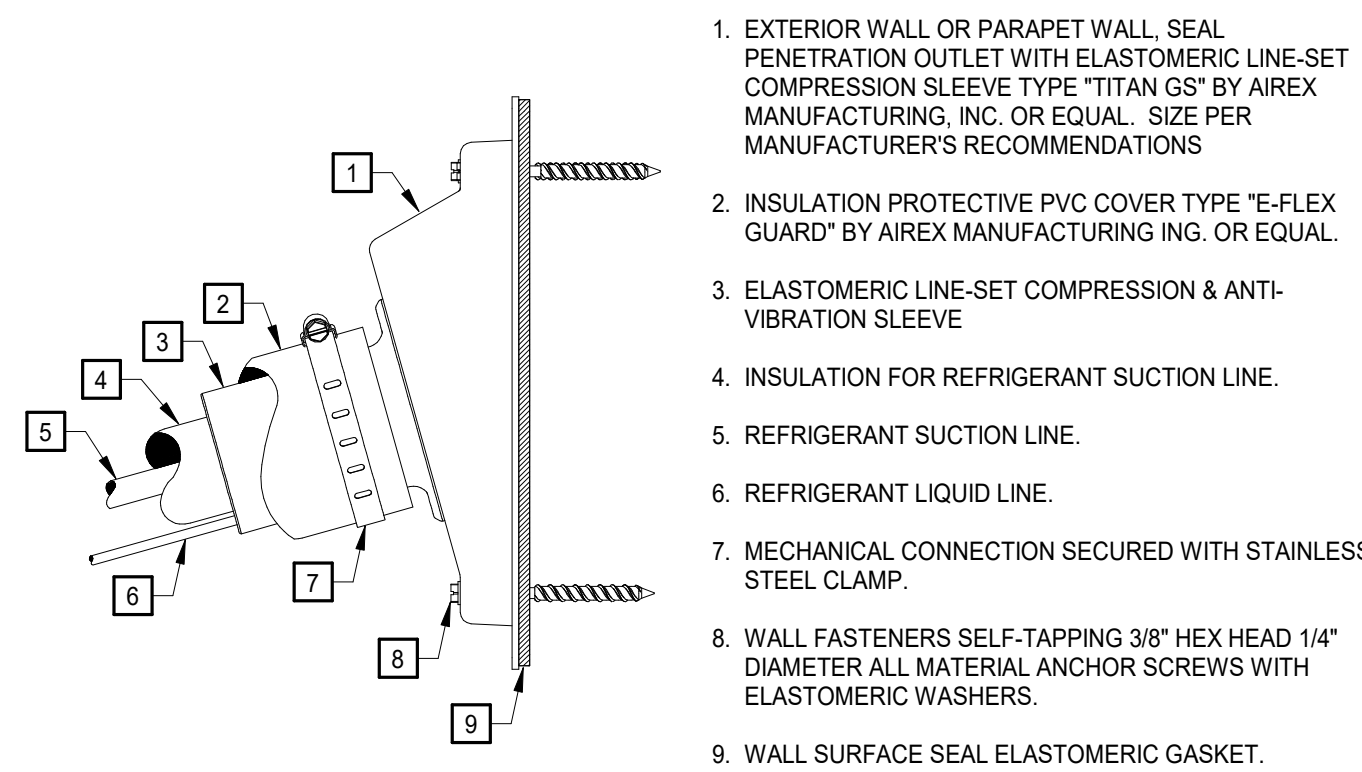

REFRIGERANT PIPE PENETRATION DETAIL - WALL

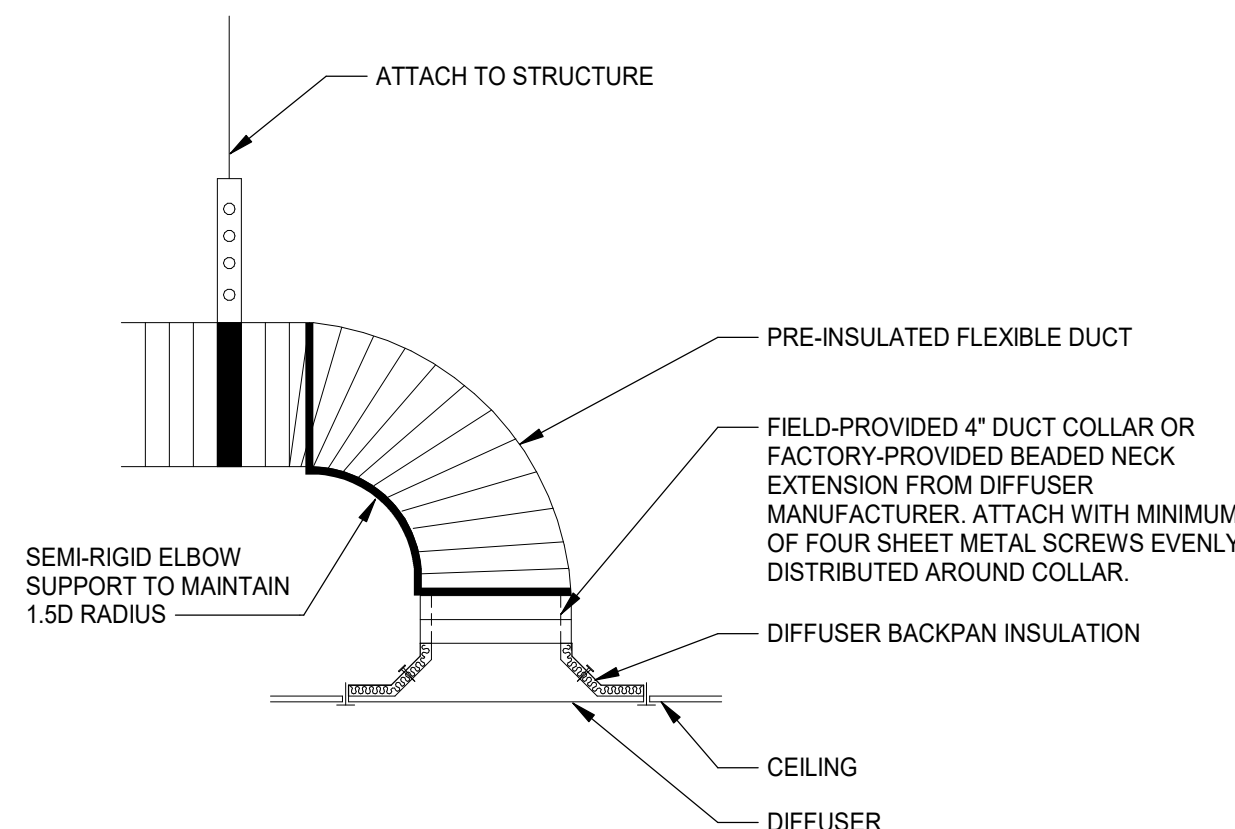

FLEXIBLE DUCT TO DIFFUSER CONNECTION DETAIL

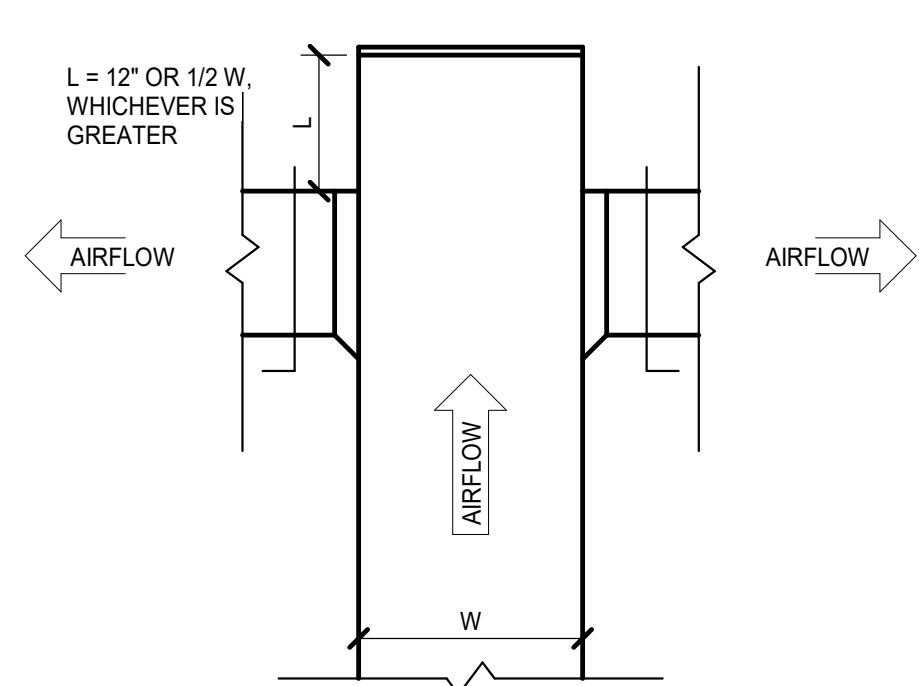


NOTES:
1. REFER TO BRANCH CONNECTION TO DIFFUSER DETAILS FOR BRANCH TAKE-OFF REQUIREMENTS.
2. APPLIES TO:
A. WHERE "W" IS LESS THAN 24"
B. ROUND DUCT BRANCHES TO DIFFUSERS
C. WHEN AIRFLOW IS EQUAL TO OR LESS THAN 1,500 CFM.

HENRICO ANIMAL SHELTER

10421 WOODMAN ROAD, GLEN ALLEN, VA 23060
HENRICO COUNTY, VA
615225

PROJECT NO: 615225
DATE: AUGUST 18, 2025
REVISIONS
DATE DESCRIPTION

DETAILS

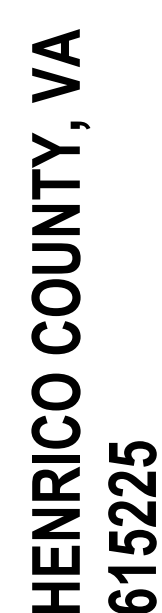



10421 WOODMAN ROAD, GLEN ALLEN, VA 23060

**HENRICO COUNTY, VA
615225**


DETAILS



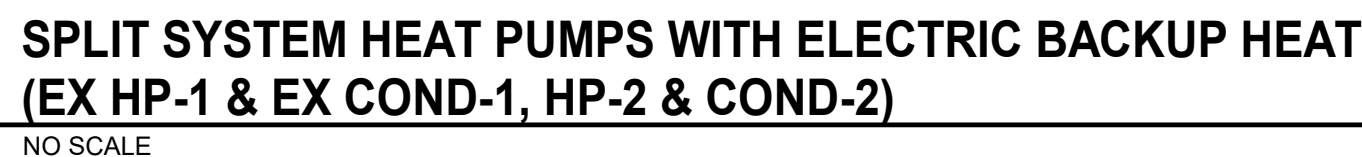


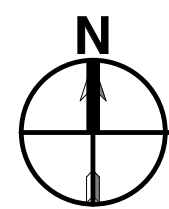

FLOOR PLAN - DEMOLITION
1/8" = 1'-0"

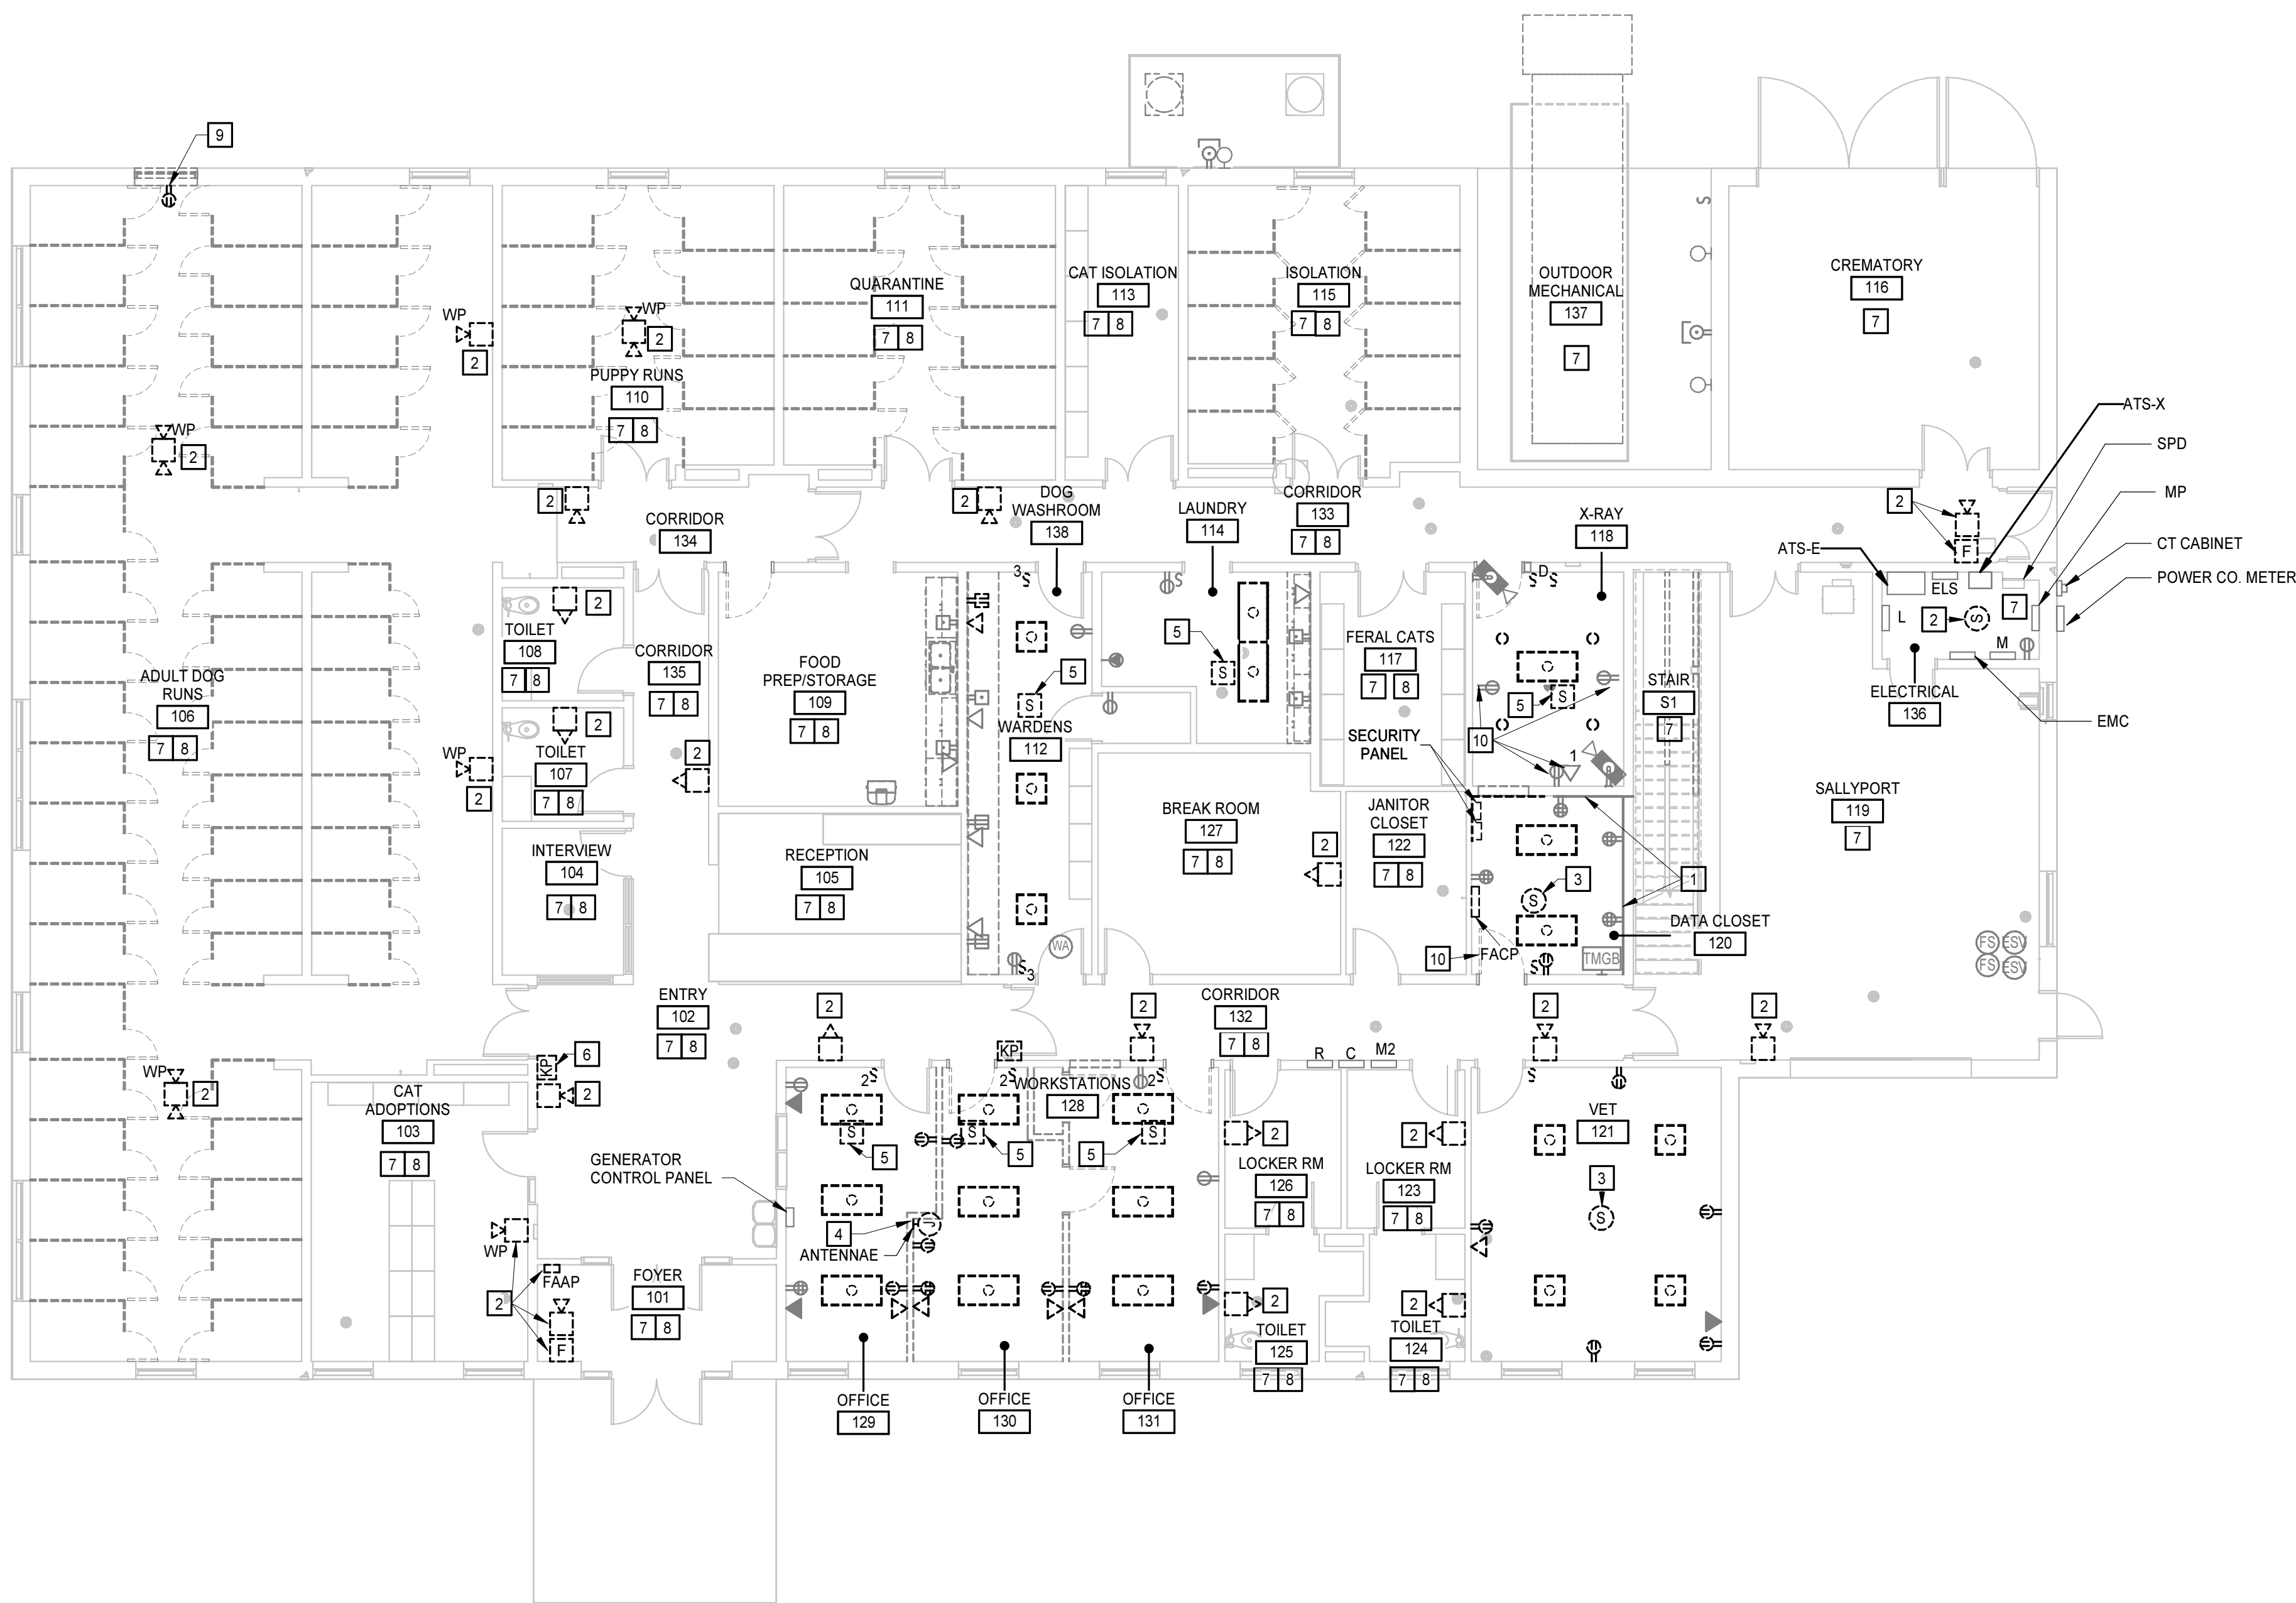

MEZZANINE PLAN - DEMOLITION
1/8" = 1'-0"

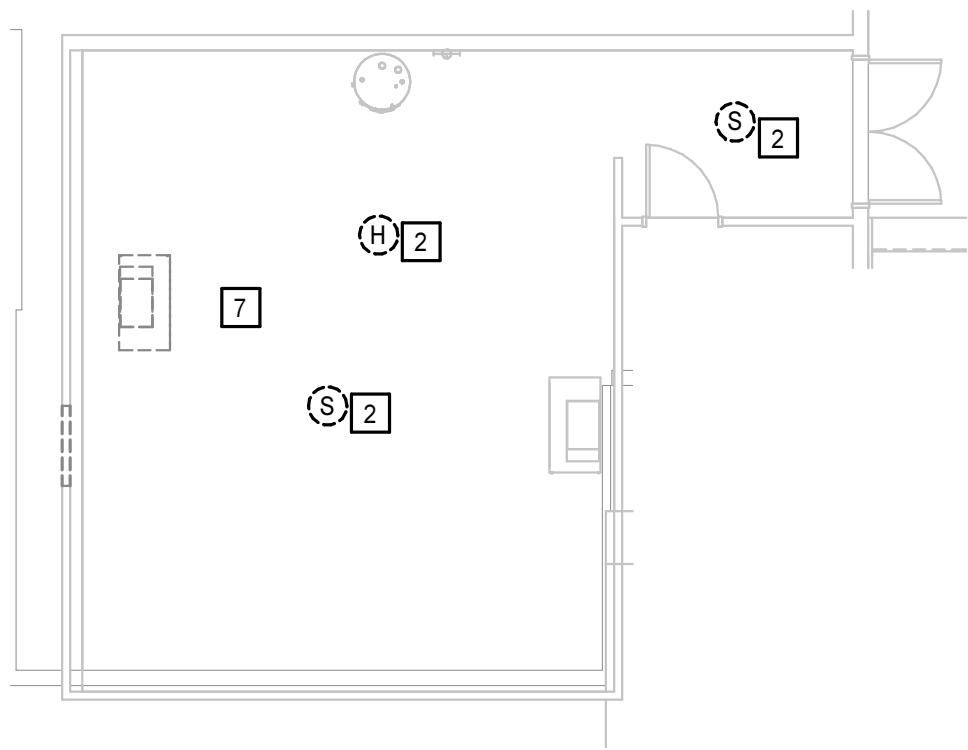

GENERAL NOTES

- A. ALL EXISTING FIRE ALARM DEVICES SHALL REMAIN UNO AND RECONNECT TO NEW FIRE ALARM SYSTEM.
- B. EXISTING INFORMATION INDICATED ON THIS SHEET PER FIELD OBSERVATION AND AS-BUILT DRAWINGS. VERIFY THE INFORMATION IN FIELD.
- C. REFER TO ARCHITECTURAL, MECHANICAL, AND PLUMBING PLANS FOR ADDITIONAL INFORMATION.
- D. ALL SYMBOLS WITH DASH LINE TO BE REMOVED UNO.
- E. ALL SYMBOLS WITH LIGHT LINE TO REMAIN UNO.
- F. MAINTAIN ANY CIRCUITS INCLUDING LOW VOLTAGE SYSTEMS TO ANY EQUIPMENT/DEVICES REQUIRED TO SERVE EXISTING-TO-REMAIN SPACES.
- G. ALL EXISTING MECHANICAL CIRCUITS SHALL REMAIN AND BE REUSED FOR NEW EQUIPMENT. REWORK AND EXTEND EXISTING FEEDERS AS REQUIRED TO CONNECT TO THE NEW EQUIPMENT. REFER TO DWG E2.1.4 & E2.2 FOR ADDITIONAL INFORMATION.

KEYNOTES

APPLIES TO DRAWINGS E1.2
REPRESENTED BY [A]

1. ALL EXISTING EQUIPMENT/DEVICES /CONDUITS /CABLES/PLYWOOD ON THE WALL SHALL REMAIN.
2. EXISTING FIRE ALARM DEVICE/EQUIPMENT SHALL BE REPLACED WITH NEW FIRE ALARM DEVICE/EQUIPMENT. REFER TO DWG E2.1.3 FOR ADDITIONAL INFORMATION.
3. EXISTING FIRE ALARM DEVICE SHALL BE REMOVED.
4. EXISTING ANTENNAE SYSTEM SHALL BE RELOCATED PER OWNER'S DIRECTION.
5. EXISTING SPEAKER SHALL BE REMOVED AND RE-INSTALL AFTER CEILING COMPLETE. REFER TO E2.1.3 FOR LOCATION.
6. NOT USED.
7. ALL EXISTING ELECTRICAL SYSTEMS (INCLUDING ALL LOW VOLTAGE SYSTEMS) IN THE ROOM SHALL REMAIN UNO.
8. REMOVE ALL EXISTING CEILING MOUNTED ELECTRICAL DEVICES INCLUDING LIGHT FIXTURES IN THE ROOM, THEN RE-INSTALL BACK AFTER CEILING COMPLETE.
9. RELOCATE THE EXISTING RECEPTACLE. REFER TO E2.1.2 FOR NEW LOCATION.
10. EXISTING RECEPTACLE AND DATA OUTLET SHALL BE REMOVED AND RE-INSTALL AFTER SHIELDING COMPLETE IN X-RAY ROOM.



GENERAL NOTES:

- ALL FIXTURES SHALL BE CAPABLE OF 120V INPUT, UNO.
- REFER TO LIGHTING PLANS AND SPECIFICATIONS FOR ADDITIONAL FIXTURE INFORMATION.
- ALL LENS SHALL BE A MINIMUM 0.125" THICKNESS, UNO.
- PROVIDE NUMBER OF FACES AND DIRECTIONAL CHEVRONS FOR EXIT SIGNS AS INDICATED ON DWGS.



A. REFER TO ARCHITECTURAL OR INTERIOR PLANS FOR ADDITIONAL INFORMATION

APPLIES TO DRAWINGS E2.1.1
REPRESENTED BY n

- MOSELEY**ARCHITECTS





10421 WOODMAN ROAD, GLEN ALLEN, VA 23060
HENRICO COUNTY, VA
615225

FLOOR PLAN LIGHTING

E2.1.1

8/15/2025 12:28:21 PM

J
I
H
G
F
E
D
C
B
A

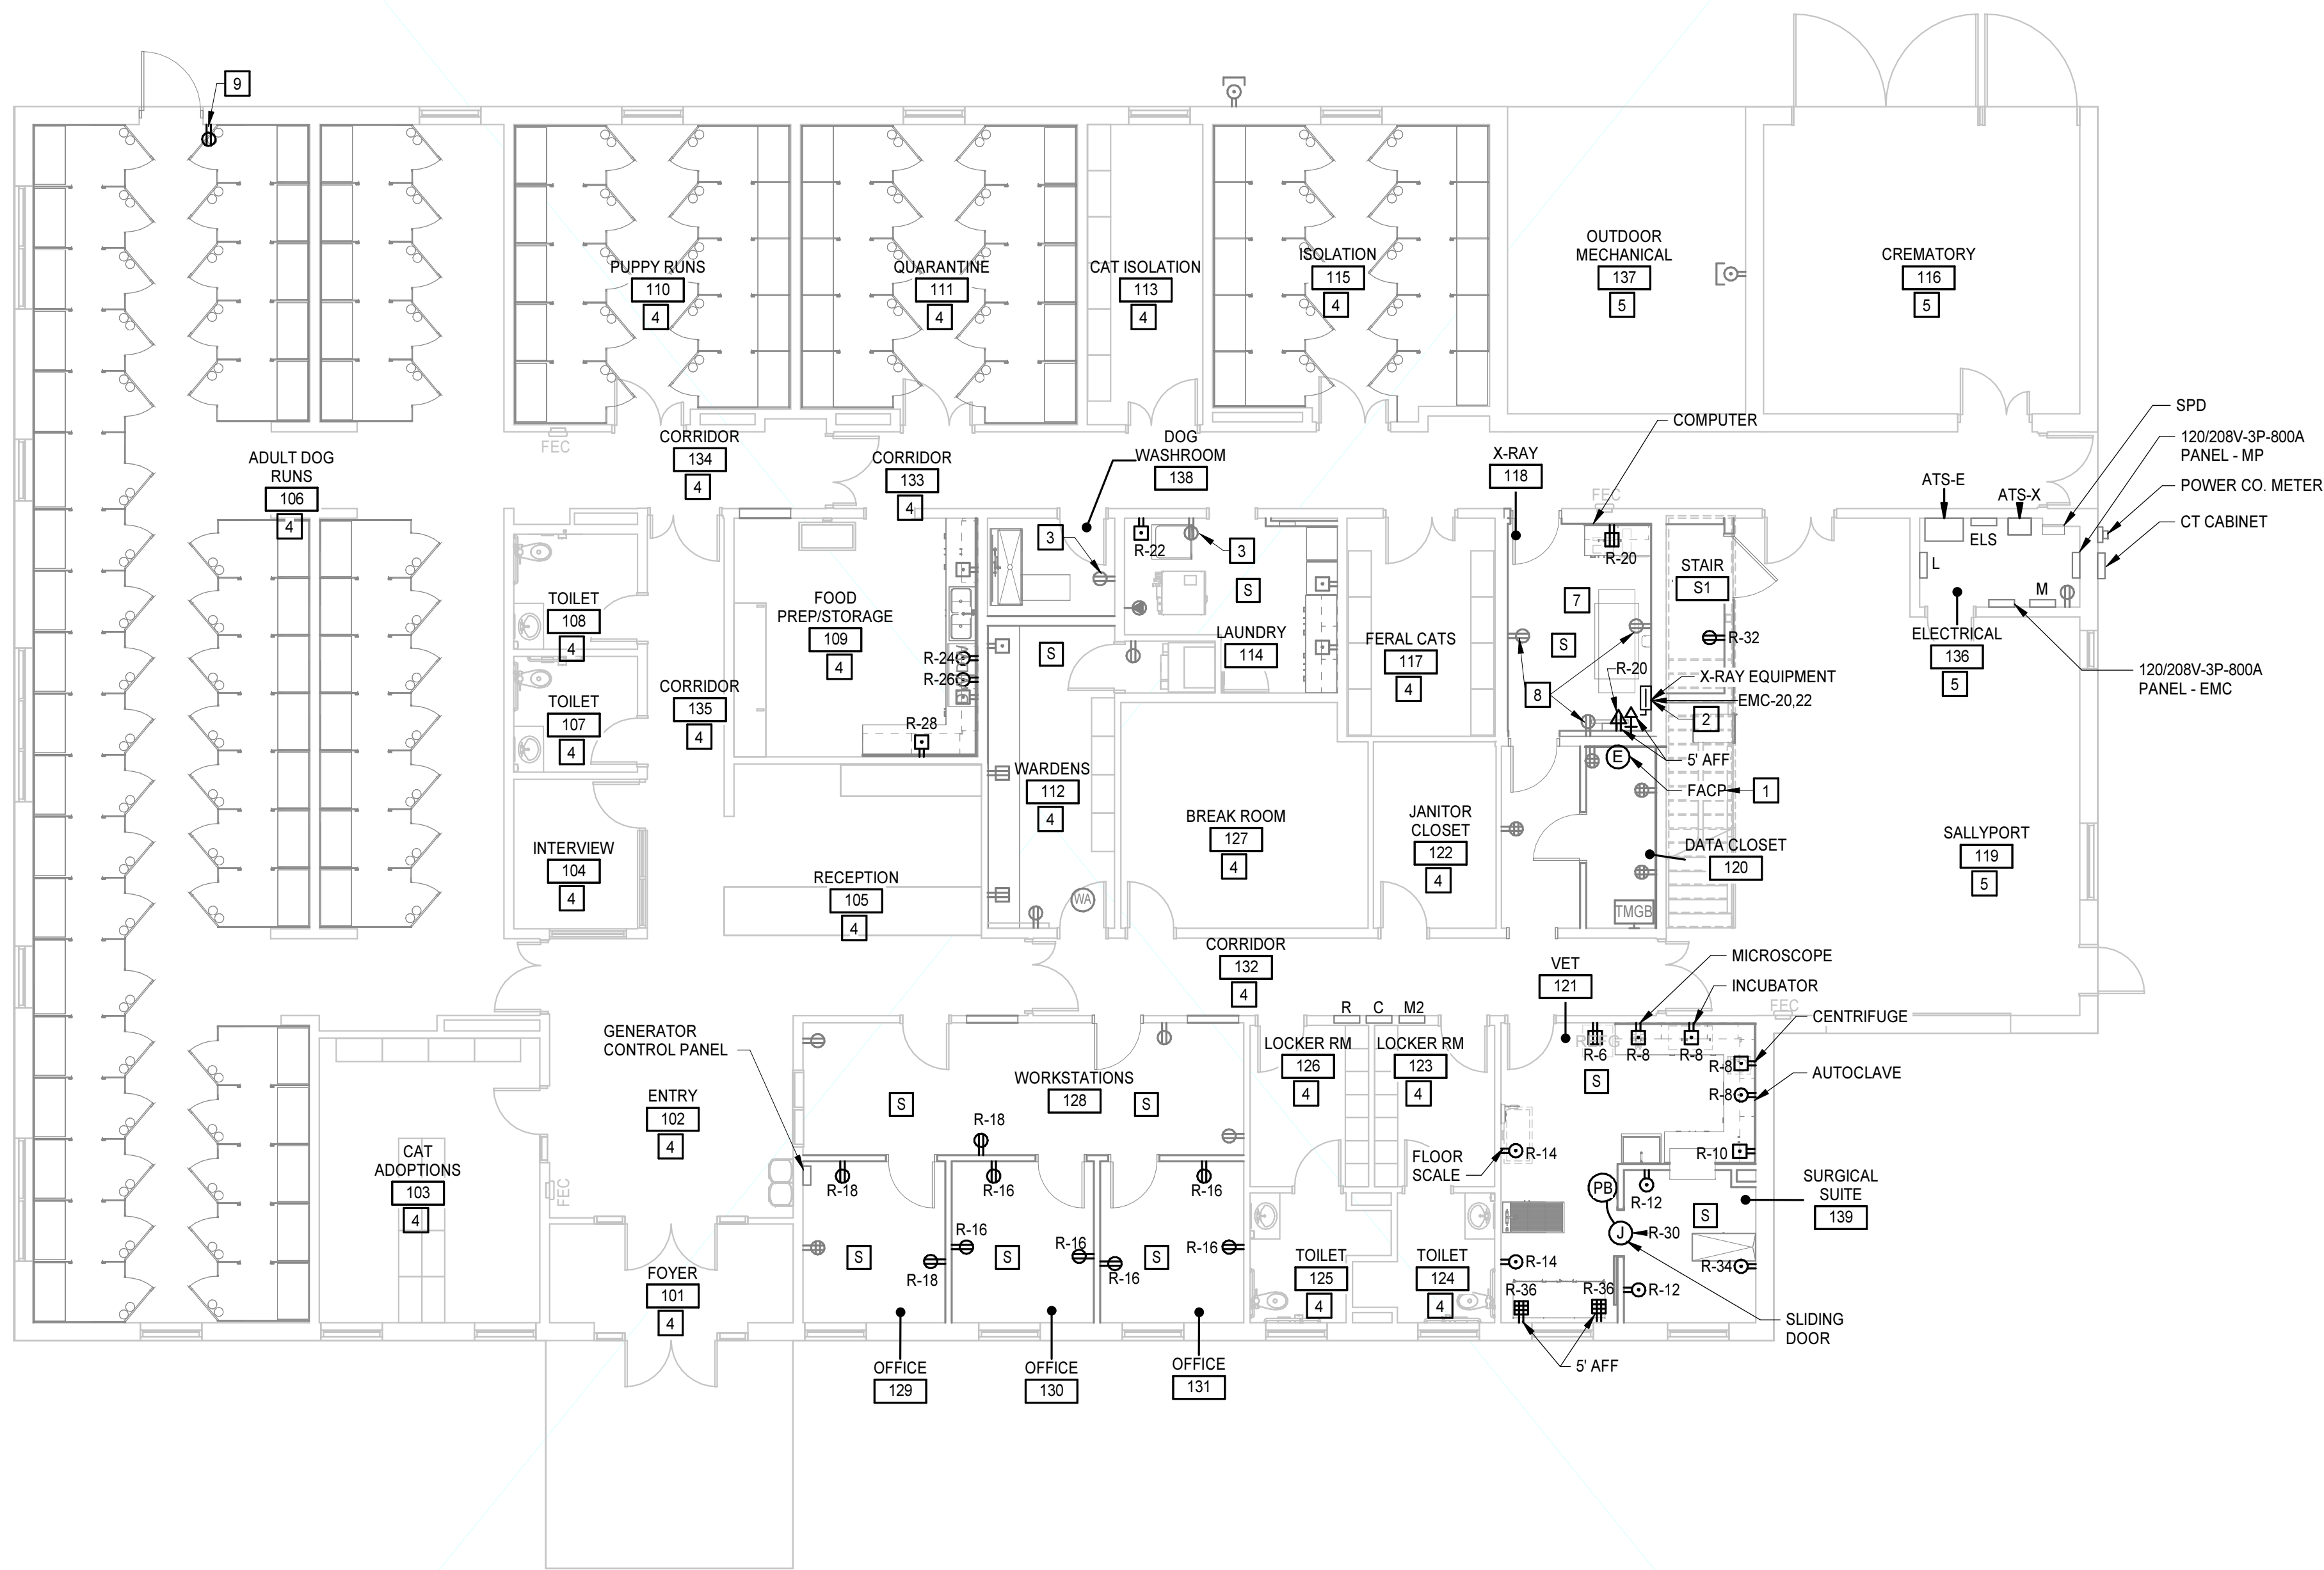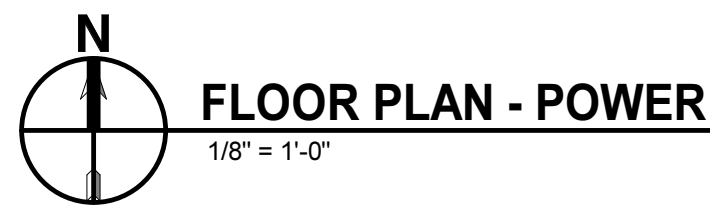


GENERAL NOTES

- A. REFER TO ARCHITECTURAL OR INTERIOR PLANS FOR ADDITIONAL INFORMATION INCLUDING LOCATIONS AND HEIGHTS OF OUTLETS, JUNCTION BOXES.
- B. ALL RECEPTACLE COVERS SHALL BE STAINLESS STEEL.

KEYNOTES

APPLIES TO DRAWINGS E2.1.2
REPRESENTED BY A

1. REUSE EXISTING FACP CIRCUIT ELS-13.
2. PROVIDE A NEMA 3R, 208V/1P, 200A 115A-FUSE DISCONNECT. COORDINATE THIS WITH MANUFACTURER. LOCATION CAN BE FIELD ADJUSTED. PROVIDE 3/8\"

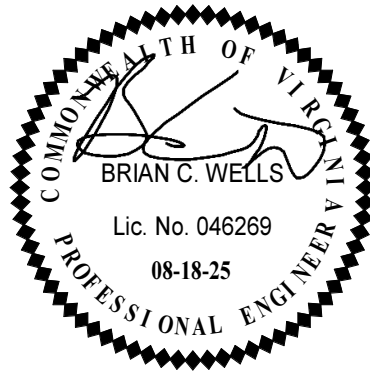

HENRICO ANIMAL SHELTER

10421 WOODMAN ROAD, GLEN ALLEN, VA 23060
HENRICO COUNTY, VA
615225


PROJECT NO:	615225
DATE:	AUGUST 18, 2025
REVISIONS	
DATE	DESCRIPTION

FLOOR PLAN - POWER

E2.1.2


MOSELEYARCHITECTS

5200 NORFOLK STREET, RICHMOND, VA 23230
PHONE (804) 784-7555 FAX (804) 355-5690
MOSELEYARCHITECTS.COM

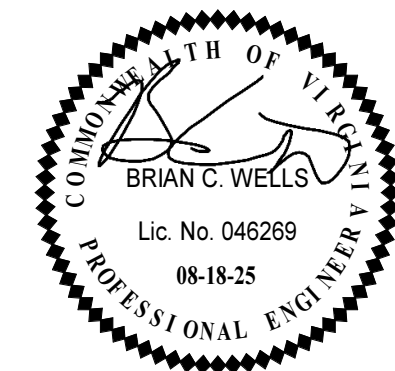


10421 WOODMAN ROAD, GLEN ALLEN, VA 23060
HENRICO COUNTY, VA
615225

PROJECT NO: 615225	
DATE: AUGUST 18, 2025	
REVISIONS	
DATE	DESCRIPTION

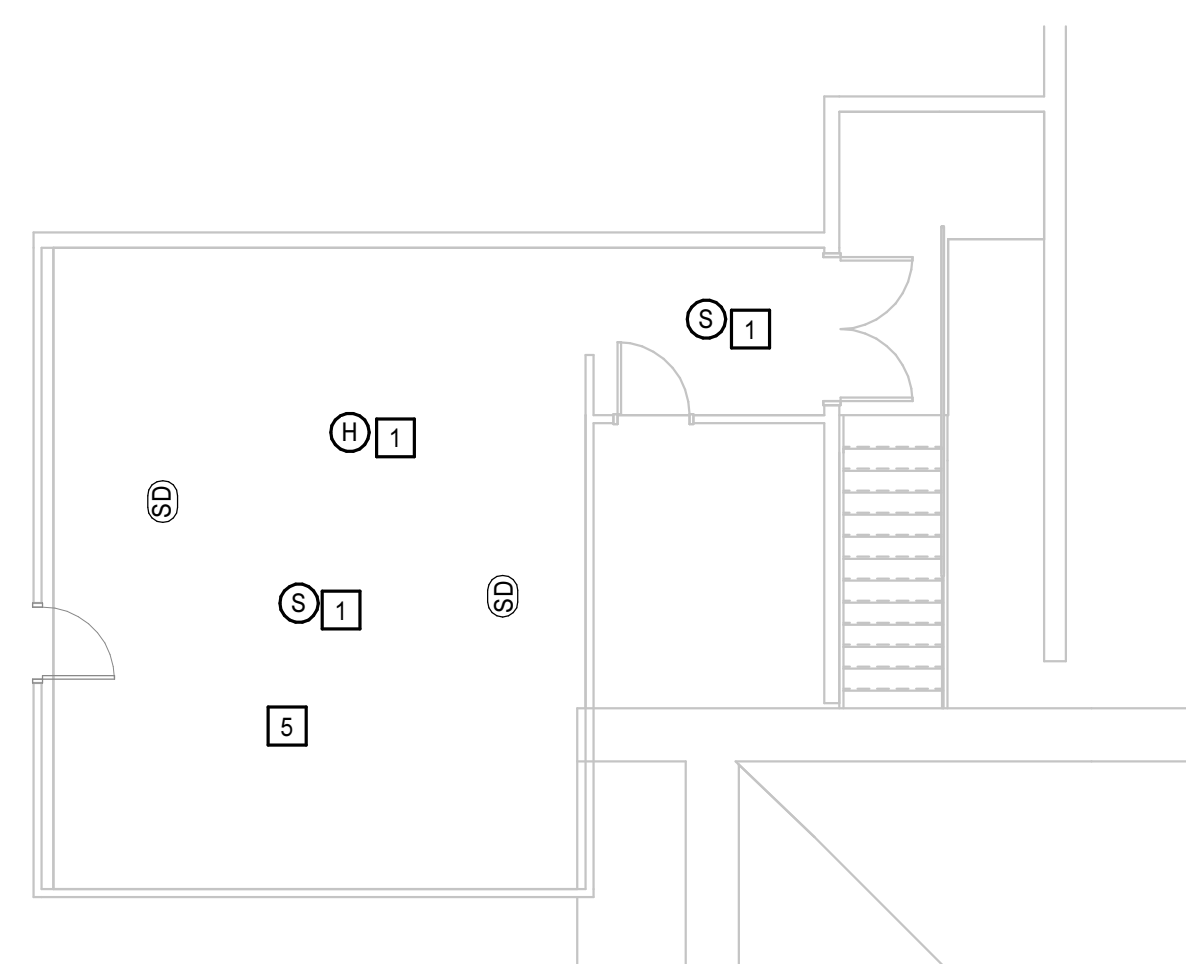

MEZZANINE PLAN - COMMUNICATIONS
1/8" = 1'-0"

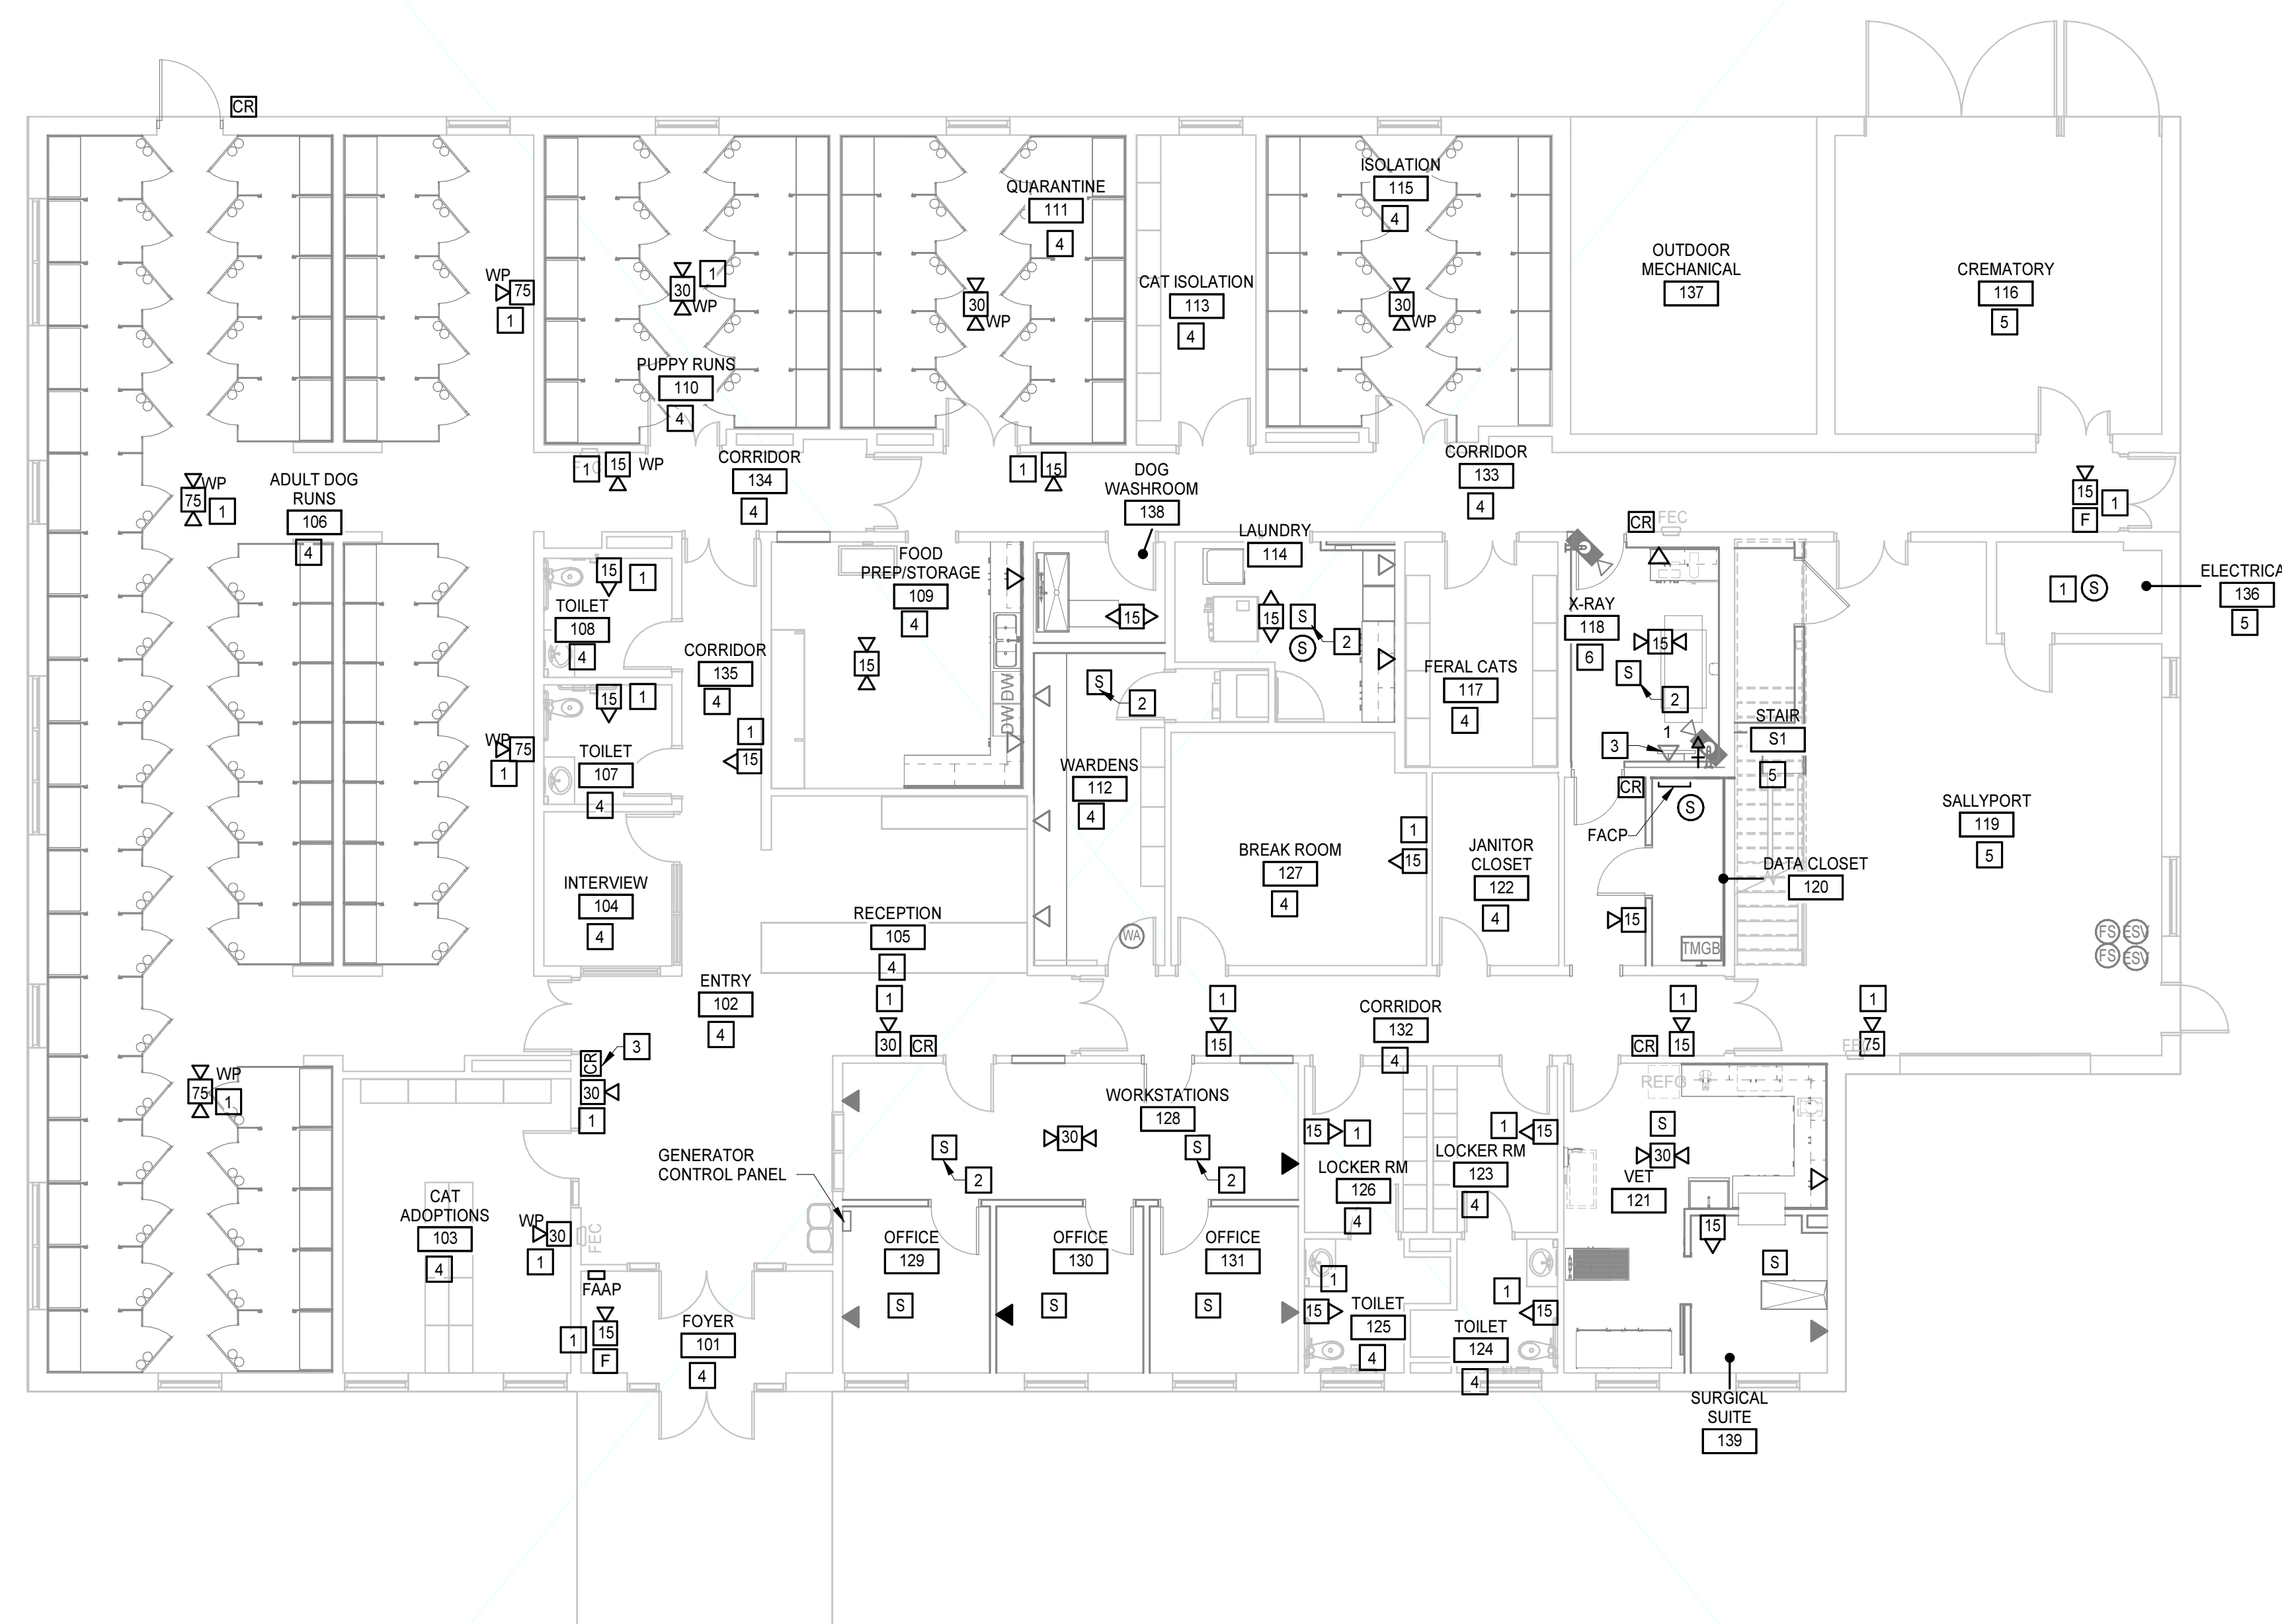

FLOOR PLAN - COMMUNICATIONS

A. SOLID GRAY AREAS ARE NOT IN CONTRACT UNO.

 
B. REFER TO ARCHITECTURAL PLANS FOR ADDITIONAL INFORMATION.

C. ALL EXISTING DEVICES/EQUIPMENT, WHICH WERE CONNECTED TO EXISTING FACP, SHALL BE DISCONNECTED FROM THE EX FACP AND RECONNECTED TO THE FACP LOCATED IN DATA CLOSET/H20.


D. ALL DATA/TELE OUTLET COVERS SHALL BE STAINLESS STEEL.

APPLIES TO DRAWINGS E2.1.3
REPRESENTED BY n

1. REFER TO KEYNOTE#2 ON DWG E1.2 FOR ADDITIONAL INFORMATION
2. REFER TO KEYNOTE#5 ON DWG E1.2 FOR ADDITIONAL INFORMATION.
3. REFER TO KEYNOTE# 10 ON DEMO DRAWING E1.2.
4. REFER TO KEYNOTE# 7 & #8 ON DEMO DRAWING E1.2.
5. EXITING LOW VOLTAGE SYSTEM IN THE ROOM SHALL REMAIN UNO.
6. ALL JUNCTION BOXES AND OTHER PENETRATIONS IN WALLS IN X-RAY ROOM MUST BE COVERED WITH EQUIVALENT THICKNESS OF SHIELDING WITH OVERLAPPING EDGES (NO GAPS IN SHIELDING)



 REMARKS/NOTES:
1. REUSE EX CKT OF THE PREVIOUS EQUIPMENT (TO BE REMOVED)



GENERAL NOTES

A. COORDINATE LOCATION OF ALL DISCONNECTS, CONTROL PANELS, & ELECTRICAL CONNECTIONS WITH MECHANICAL AND PLUMBING.

B. REFER TO KEYNOTE# 7 & #9 ON DEMO DRAWING E1.2.


A. COORDINATE LOCATION OF ALL DISCONNECTS, CONTROL PANELS, & ELECTRICAL CONNECTIONS WITH MECHANICAL AND PLUMBING.

B. REFER TO KEYNOTE# 7 & #8 ON DEMO DRAWING E1.2.

B. REFER TO KEYNOTE# 7 & #8 ON DEMO DRAWING E1.2




NO SCALE

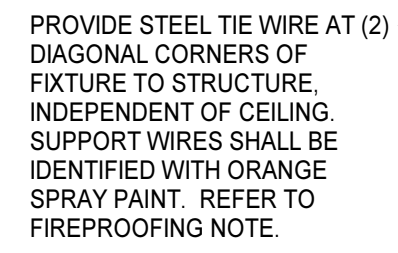

NO SCALE



NO SCALE

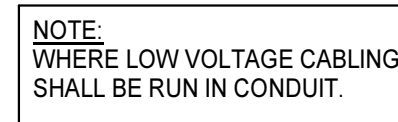


NO SCALE



NO SCALE




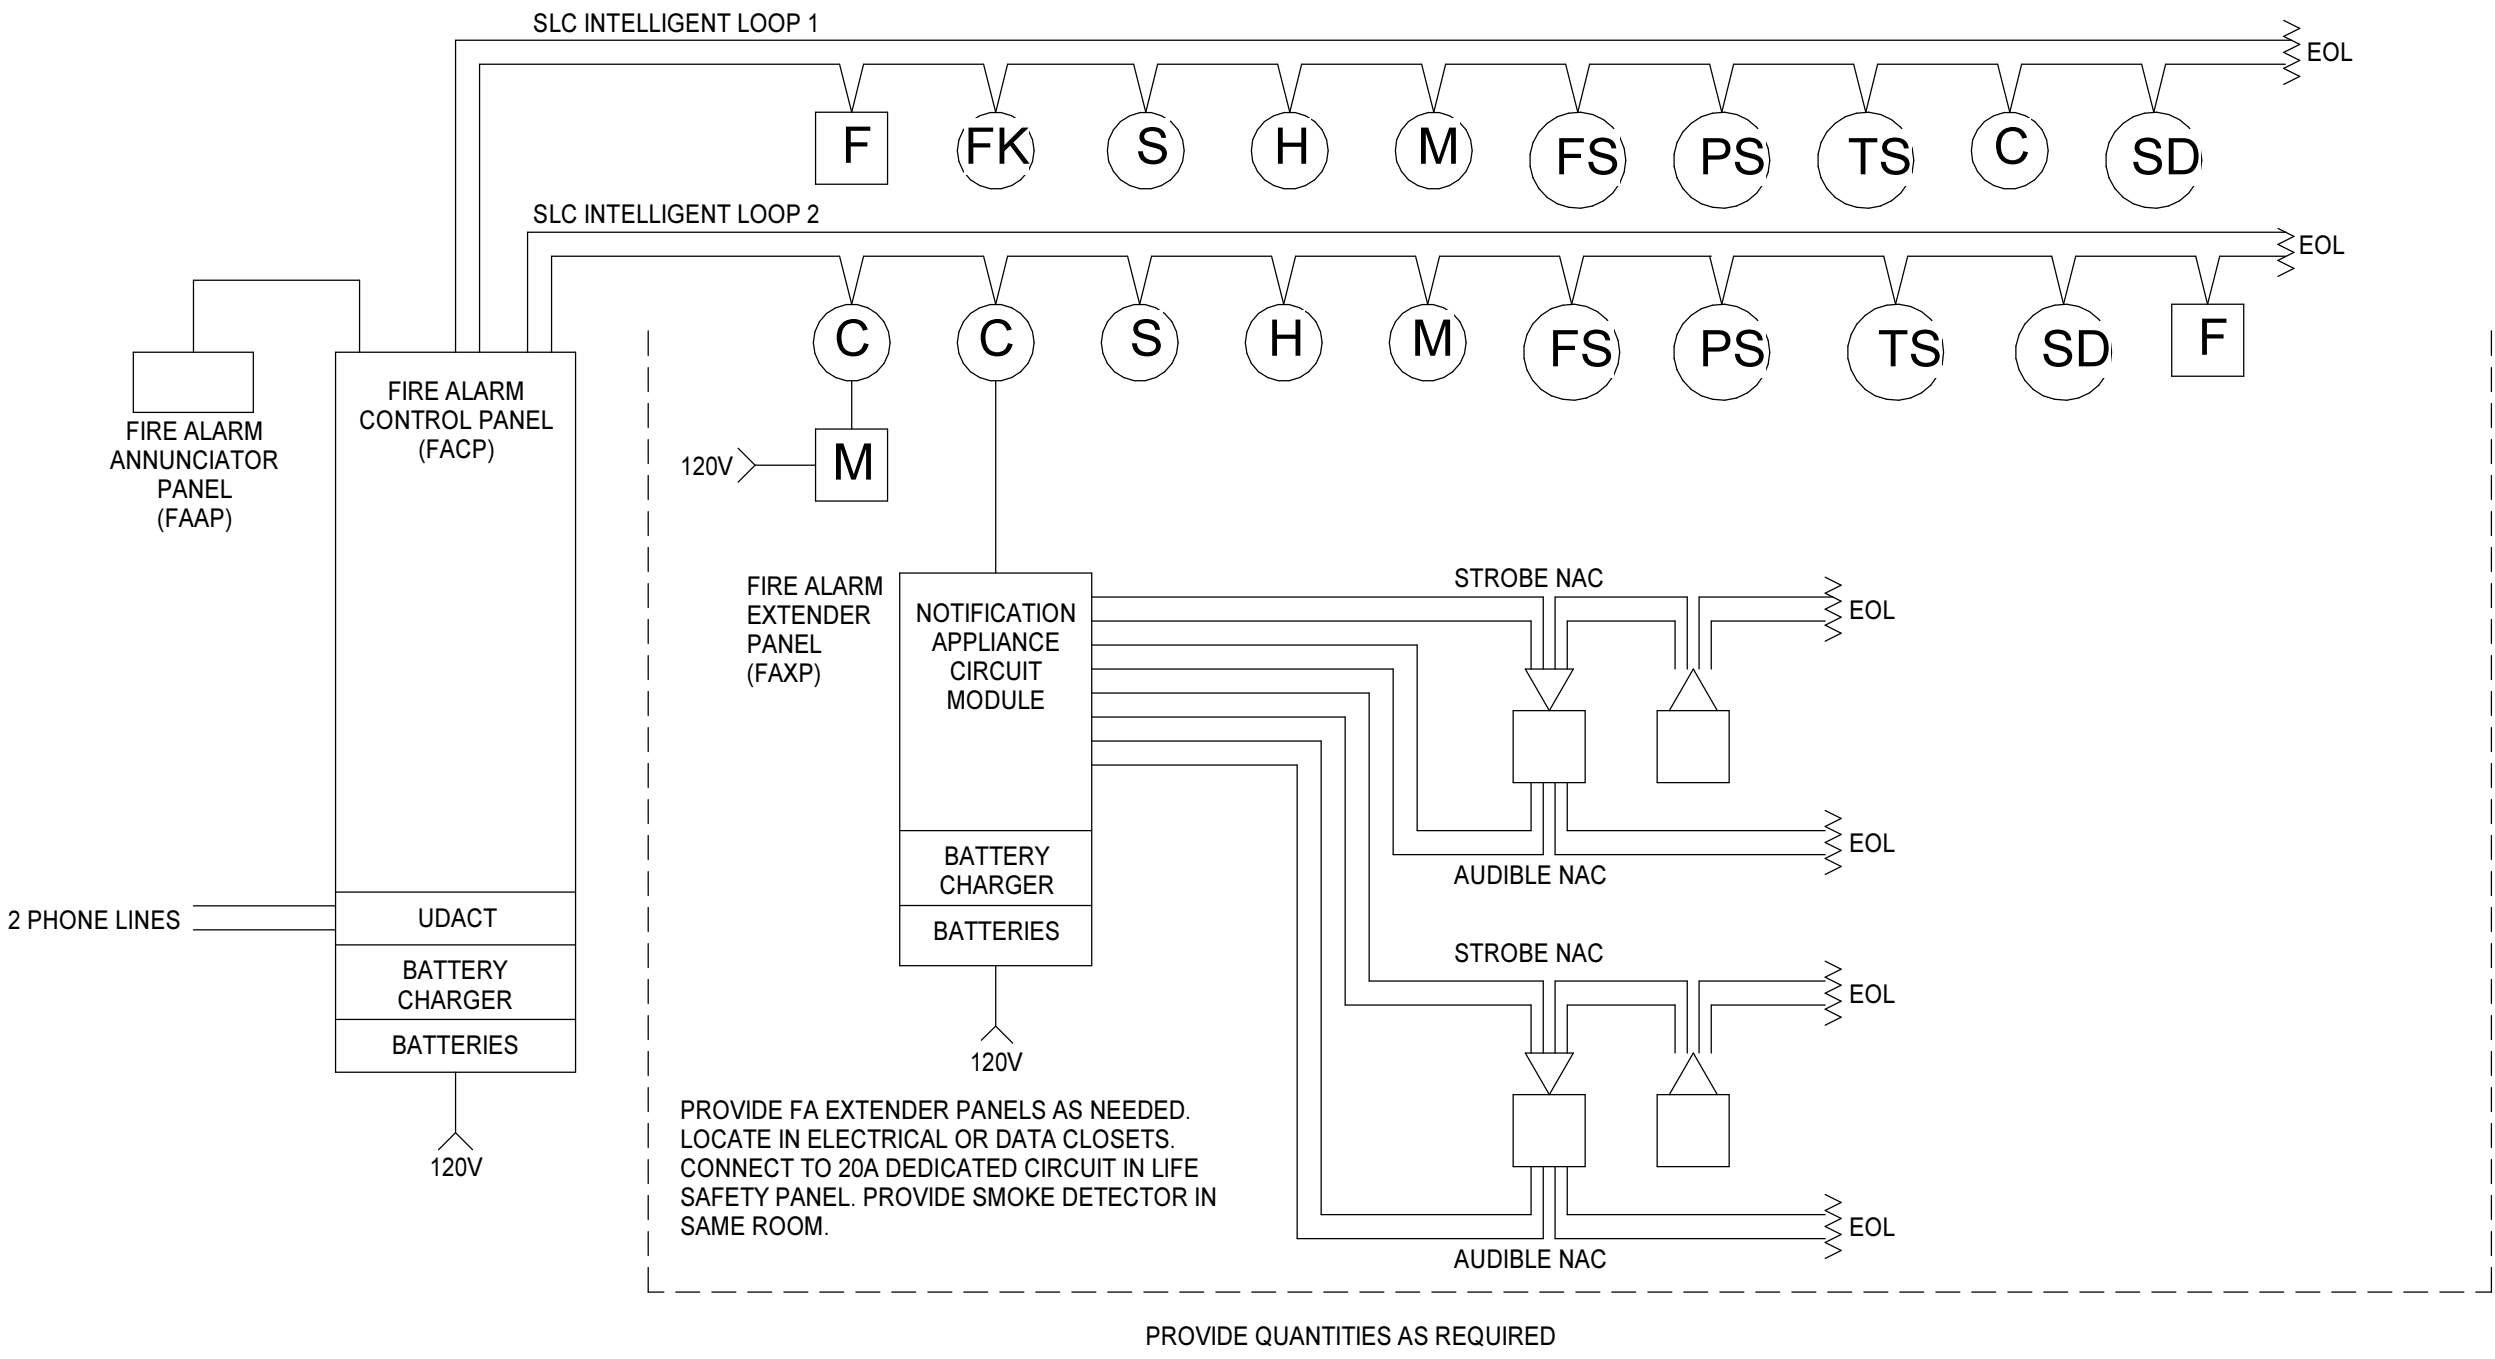

FIRE ALARM RISER DIAGRAM


NO SCALE

		CONTROL UNIT ANNUNCIATION							NOTIFICATION / ACTION						
		A	B	C	D	E	F	G	H	I	J	K	L	M	N
1	MANUAL PULL STATION	X	X	X					X	X		X	X		
2	SMOKE DETECTOR	X	X	X					X	X		X	X		
3	DUCT SMOKE DETECTOR	X	X	X					X	X		X	X		
4	HEAT DETECTOR	X	X	X					X	X		X	X		
5	KITCHEN HOOD FIRE SUPPRESSION SYSTEM MONITOR	X	X	X					X	X	X	X	X		
6	SPRINKLER SYSTEM WATERFLOW	X	X	X					X	X	X	X	X		
7	SPRINKLER VALVE TAMPER SWITCH				X	X			X		X	X		X	
8	MONITOR MODULE - GENERATOR FAILURE				X	X			X		X	X		X	
9	MONITOR MODULE - GENERATOR RUN								X		X			X	
10	FIRE ALARM AC POWER FAILURE						X	X	X		X				X
11	FIRE ALARM SYSTEM LOW BATTERY						X	X	X		X			X	
12	FIRE ALARM OPEN CIRCUIT						X	X	X		X			X	
13	FIRE ALARM GROUND FAULT						X	X	X		X			X	
14	FIRE ALARM NOTIFICATION APPLIANCE CIRCUIT SHORT						X	X	X		X			X	

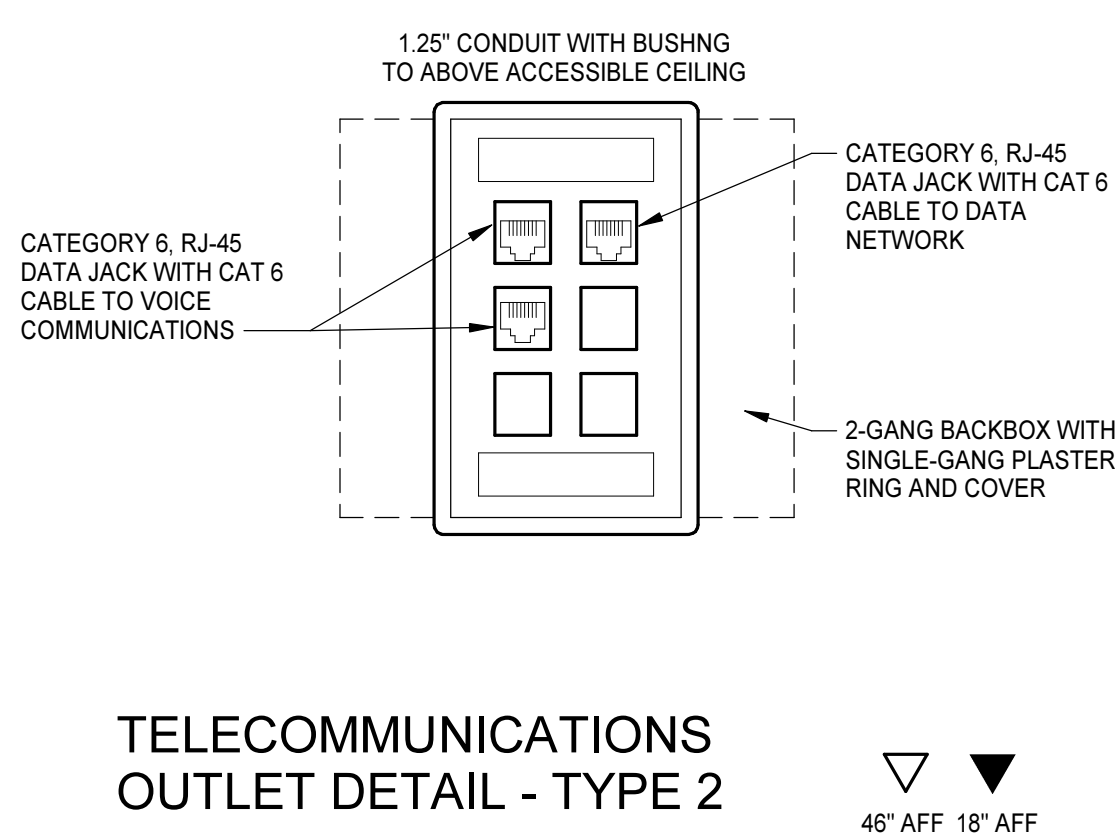


TELECOMMUNICATIONS OUTLET DETAIL - TYPE 2

NO SCALE

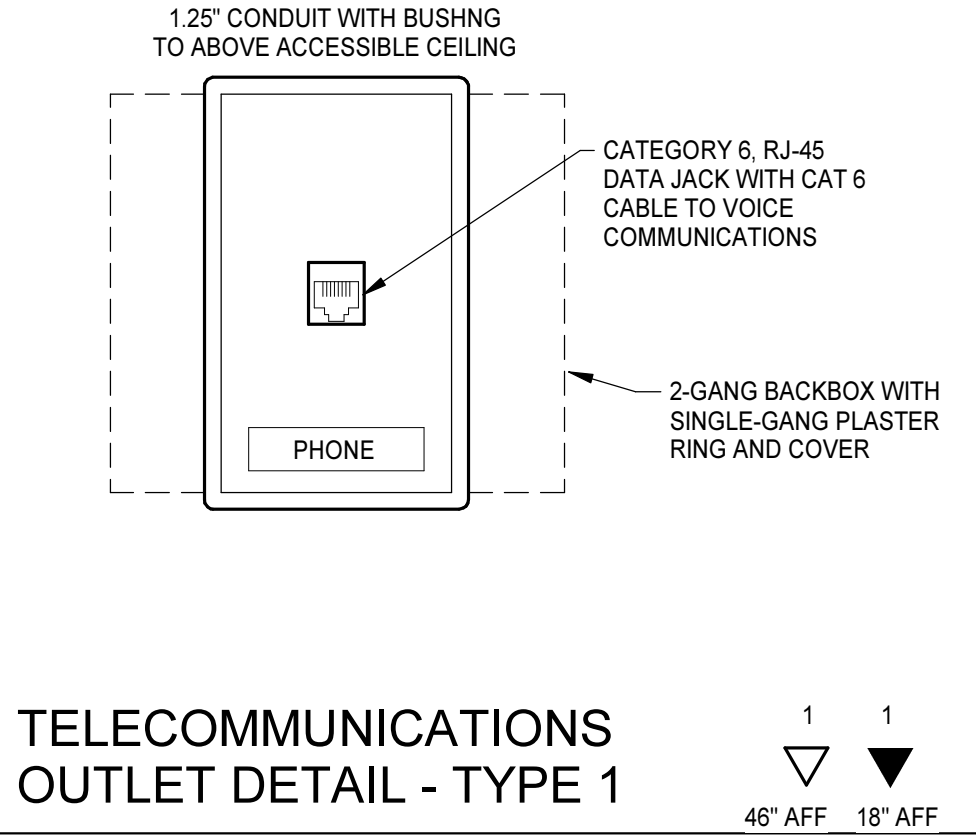


TELECOMMUNICATIONS OUTLET DETAIL - TYPE 1

NO SCALE

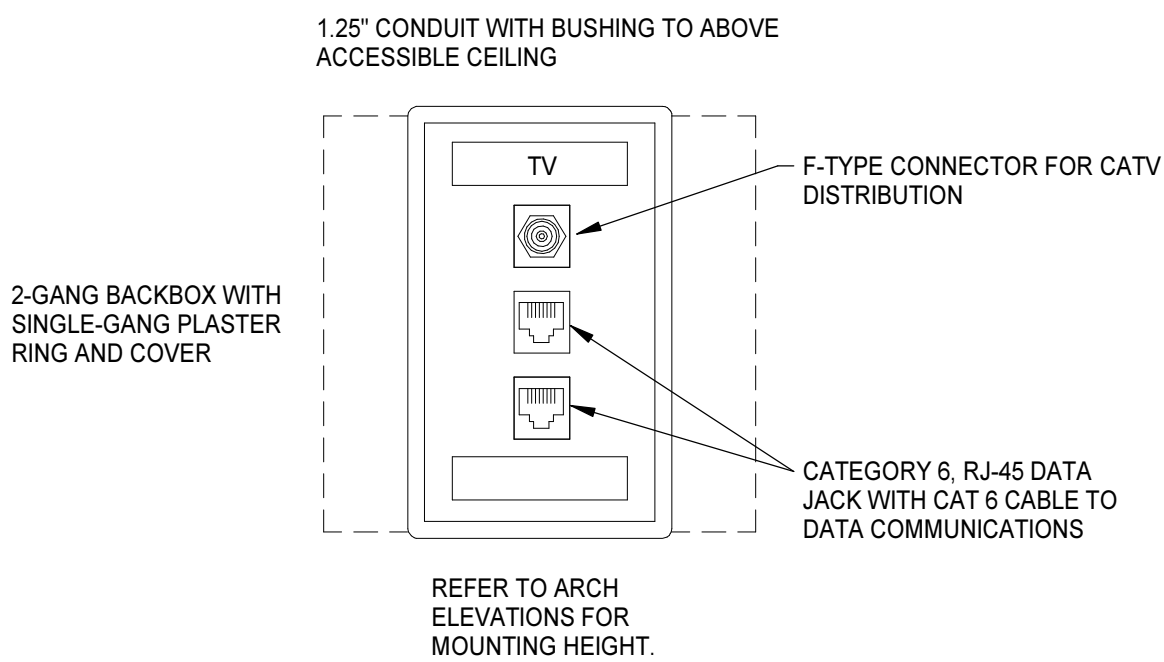

CATV OUTLET DETAIL - TYPE 1

NO SCALE

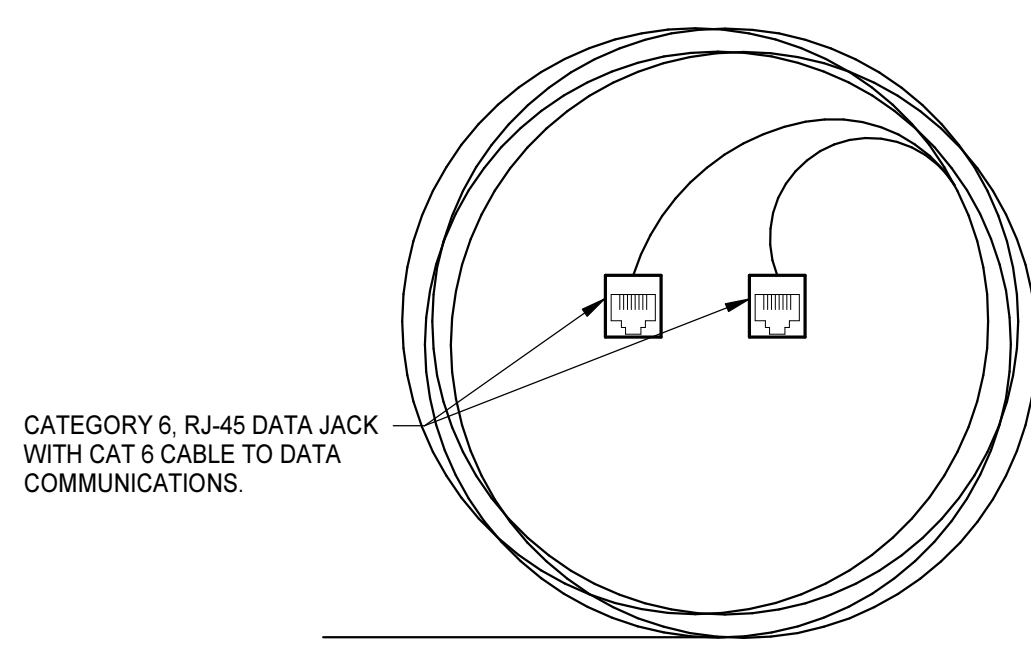


WIRELESS ACCESS POINT DETAIL

NO SCALE

TELECOMMUNICATION OUTLET DETAILS

NO SCALE

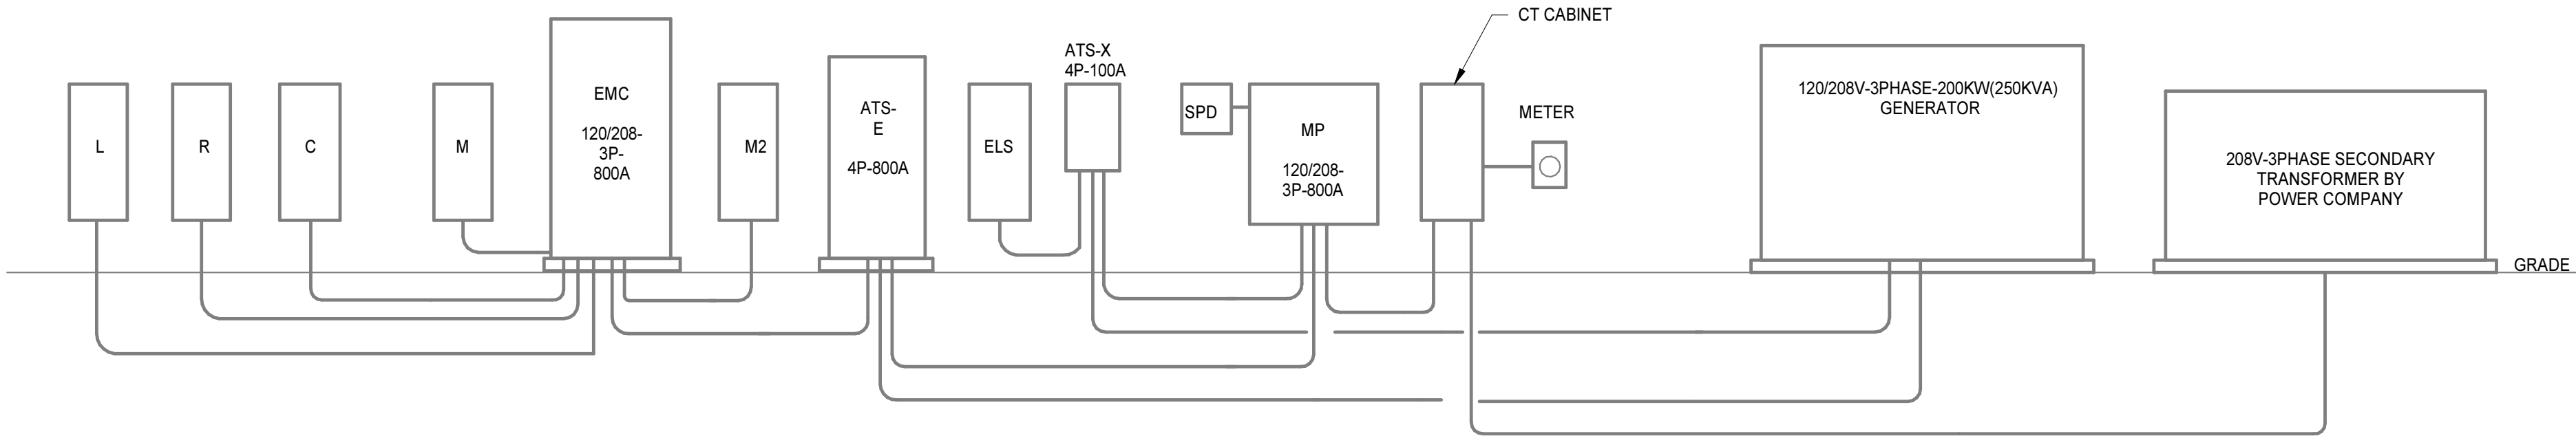

EXISTING ELECTRICAL ONE-LINE DIAGRAM
NO SCALE

GENERAL NOTES

A. EXISTING ONE-LINE DIAGRAM AND PANEL SCHEDULE PER FIELD OBSERVATION AND THE INFORMATION SHOWN ON EXISTING DRAWINGS.

B. VERIFY INFORMATION SHOWN ON EXISTING ONE-LINE DIAGRAM AND PANEL SCHEDULE IN FIELD.

COPPER FEEDER SCHEDULE									
FEEDER ID	# OF SETS	BUILDING WIRE QUANTITY & SIZE TYPE THHN - DRY TYPE THWN - WET		MINIMUM CONDUIT SIZE	FEEDER ID	# OF SETS	BUILDING WIRE QUANTITY & SIZE TYPE THHN - DRY TYPE THWN - WET		MINIMUM CONDUIT SIZE
30	1	3#10,#10 G		3/4"	30Y	1	4#10,#10 G		3/4"
35	1	3#8,#10 G		3/4"	35Y	1	4#8,#10 G		3/4"
40	1	3#8,#10 G		3/4"	40Y	1	4#8,#10 G		3/4"
45	1	3#6,#10 G		1"	45Y	1	4#6,#10 G		1"
50	1	3#6,#10 G		1"	50Y	1	4#6,#10 G		1"
60	1	3#4,#10 G		1"	60Y	1	4#4,#10 G		1"
70	1	3#4,#8 G		1 1/4"	70Y	1	4#4,#8 G		1 1/4"
80	1	3#3,#8 G		1 1/4"	80Y	1	4#3,#8 G		1 1/4"
90	1	3#2,#8 G		1 1/4"	90Y	1	4#2,#8 G		1 1/4"
100	1	3#1,#8 G		1 1/4"	100Y	1	4#2,#8 G		1 1/2"
110	1	3#2,#6 G		1 1/2"	110Y	1	4#2,#6 G		1 1/2"
125	1	3#1,#6 G		1 1/2"	125Y	1	4#1,#6 G		1 1/2"
150	1	3#1/0,#6 G		2"	150Y	1	4#1/0,#6 G		2"
175	1	3#2/0,#6 G		2"	175Y	1	4#2/0,#6 G		2"
200	1	3#3/0,#6 G		2"	200Y	1	4#3/0,#6 G		2"
225	1	3#4/0,#4 G		2 1/2"	225Y	1	4#4/0,#4 G		2 1/2"
250	1	3-250KCM,#4 G		2 1/2"	250Y	1	4-250KCM,#4 G		2 1/2"
300	1	3-350KCM,#4 G		2 1/2"	300Y	1	4-350KCM,#4 G		2 1/2"
350	2	3#2/0,#3 G		3"	350Y	2	4#2/0,#3 G		3"
400	2	3#3/0,#3 G		2"	400Y	2	4#3/0,#3 G		2"
450	2	3#4/0,#2 G		2 1/2"	450Y	2	4#4/0,#2 G		2 1/2"
500	2	3-250KCM,#2 G		2 1/2"	500Y	2	4-250KCM,#2 G		2 1/2"
600	2	3-350KCM,#1 G		3"	600Y	2	4-350KCM,#1 G		3"
700	2	3-500KCM,#1/0 G		4"	700Y	2	4-500KCM,#1/0 G		4"
800	3	3-350KCM,#1/0 G		3"	800Y	3	4-350KCM,#1/0 G		3"
1000	3	3-500KCM,#2/0 G		4"	1000Y	3	4-500KCM,#2/0 G		4"
1200	4	3-350KCM,#3/0 G		3"	1200Y	4	4-350KCM,#3/0 G		3"
1600	5	3-500KCM,#4/0 G		4"	1600Y	5	4-500KCM,#4/0 G		4"
2000	6	3-500KCM,#250 G		4"	2000Y	6	4-500KCM,#250 G		4"
2500	7	3-500KCM,#350 G		4"	2500Y	7	4-500KCM,#350 G		4"

NOTES:

1. ELECTRICAL CONTRACTOR TO VERIFY CONDUIT SIZE REQUIRED IF WIRE TYPES OTHER THAN THOSE LISTED ABOVE ARE USED.

2. FEEDER SIZES BASED ON TABLE 310.15(B)(16), 75° C.

3. SIZES ADJUSTED PER NEC 110.14.



PROJECT NO:	615225
DATE:	AUGUST 18, 2025
REVISIONS	
DATE	DESCRIPTION

EXSITING PANEL SCHEDULE									
EMC			LOCATION: ELECTRICAL 136			FED FROM: ATS-E			
800 AMP MCB			120/208 Wye			3 PH 4 W			
			MOUNT: SURFACE			PANEL ASSEMBLY RATED (KAIC): 42 KAIC			
CKT	BRKR	POLE	LOAD			A	B	C	LOAD
1	200 A	3	ERU-1			0.0	0.0		PANEL L
3							0.0	0.0	
5						4.5	2.4	0.0	1.1
7	225 A	3	PANEL M2				8.0	2.8	PANEL R
11								4.7	4.1
13						0.0	0.0		
15	225 A	3	PANEL C				0.0	0.0	SPARE
17								0.0	0.0
19	--	3	SPACE ONLY			--	15.0	--	X-RAY - RM 118 (PB)
21							--	15.0	
23							--	--	SPACE ONLY
25						1.4	--		
27	350 A	3	PANEL M				0.9	--	N/A
29								1.8	--
31						0.0	--		
33	800 A	3	MAIN				0.0	--	N/A
35							--		0.0
37	--	3	SPACE ONLY			--	--	--	
39							--	--	SPACE ONLY
41							--	--	
						23 kVA	28 kVA	12 kVA	
						206 A	235 A	97 A	

(GE) = PROVIDE GFCI BREAKER FOR EQUIPMENT, 6-50mA PER NEC 427.22. PROVIDE DED. NEUTRAL
(GP) = PROVIDE GFCI BREAKER FOR PERSONNEL, 4-8mA PER NEC 210.8. PROVIDE DED. NEUTRAL
(L) = PROVIDE LOCKOUT BREAKER TO PREVENT UNAUTHORIZED SWITCHING
(LO) = ROUTE TO LOAD VIA LIGHTING CONTACTOR
(ML) = PROVIDE BREAKER WITH MAINTENANCE LOCKOUT, LOCKABLE
(EB) = EXISTING BREAKER
(RB) = REPLACE BREAKER WITH SIZE INDICATED
(PB) = PROVIDE BREAKER IN EXISTING SPACE

Load Classification	Connected Load	Demand Factor	Estimated Demand	Panel Totals
INTERIOR LIGHTING	1094 VA	125.00%	1367 VA	Total Conn. Load: 61.1 kVA Total Est. Demand: 61.3 kVA Total Conn. Current: 169 A Total Est. Demand Current: 170 A
EXTERIOR LIGHTING	0 VA	0.00%	0 VA	
RECEPTACLES	4140 VA	100.00%	4140 VA	
AC / HEAT PUMP	17647 VA	100.00%	17647 VA	
ELECTRIC HEAT	0 VA	0.00%	0 VA	
KITCHEN	0 VA	0.00%	0 VA	
MISCELLANEOUS	36710 VA	100.00%	36710 VA	
EXISTING LOAD @ 125%	0 VA	0.00%	0 VA	

EXISTING PANEL SCHEDULE									
M2			LOCATION: CORRIDOR 132			FED FROM: EMC			
225 AMP MCB			120/208 Wye			3 PH 4 W			
			MOUNT: RECESSED			PANEL ASSEMBLY RATED (KAIC): 10 KAIC			
CKT	BRKR	POLE	LOAD			A	B	C	LOAD
1	20 A	1	UNKNOWN			0.0	0.0		UNKNOWN
3							0.0	0.0	
5	15 A	2	UNKNOWN				0.0	0.0	UNKNOWN
7	15 A	2	UNKNOWN			0.0	0.0		UNKNOWN
9							0.0	0.0	SPARE
11	20 A	1	EXHAUST FAN					0.0	0.0
13	20 A	1	EXHAUST FAN			0.0	0.0		SPARE
15	20 A	1	EXHAUST FAN				0.0	0.0	SPARE
17	20 A	1	EXHAUST FAN					0.0	0.0
19						0.0	0.0		SPARE
21	50 A	2	UNKNOWN				0.0	0.0	SPARE
23							0.0	0.0	SPARE
25	40 A	2	UNKNOWN			0.0	0.9		ERU-2 (RB)
27	20 A	1	UNKNOWN				0.0	0.9	
29	20 A	1	SPARE					0.0	0.5
31						0.0	0.5		CENTRAL SYSTEM WAGD
33	15 A	3	LAUNDRY 114 WATER				0.0	4.2	
35								0.0	4.2
37						0.0	3.3		COND-3 (PB)
39	20 A	3	UNKNOWN				0.0	3.3	HP-3 (PB)
41							0.0	--	SPACE ONLY
						5 kVA	8 kVA	5 kVA	
						38 A	67 A	39 A	

(GE) = PROVIDE GFCI BREAKER FOR EQUIPMENT, 6-50mA PER NEC 427.22. PROVIDE DED. NEUTRAL
(GP) = PROVIDE GFCI BREAKER FOR PERSONNEL, 4-8mA PER NEC 210.8. PROVIDE DED. NEUTRAL
(L) = PROVIDE LOCKOUT BREAKER TO PREVENT UNAUTHORIZED SWITCHING
(LO) = ROUTE TO LOAD VIA LIGHTING CONTACTOR
(ML) = PROVIDE BREAKER WITH MAINTENANCE LOCKOUT, LOCKABLE
(EB) = EXISTING BREAKER
(RB) = REPLACE BREAKER WITH SIZE INDICATED
(PB) = PROVIDE BREAKER IN EXISTING SPACE

Load Classification	Connected Load	Demand Factor	Estimated Demand	Panel Totals
INTERIOR LIGHTING	0 VA	0.00%	0 VA	Total Conn. Load: 16.9 kVA Total Est. Demand: 16.9 kVA Total Conn. Current: 47 A Total Est. Demand Current: 47 A
EXTERIOR LIGHTING	0 VA	0.00%	0 VA	
RECEPTACLES	0 VA	0.00%	0 VA	
AC / HEAT PUMP	14217 VA	100.00%	14217 VA	
ELECTRIC HEAT	0 VA	0.00%	0 VA	
KITCHEN	0 VA	0.00%	0 VA	
MISCELLANEOUS	1000 VA	100.00%	1000 VA	
EXISTING LOAD @ 125%	0 VA	0.00%	0 VA	

EXISTING PANEL SCHEDULE									
M			LOCATION: ELECTRICAL 136			FED FROM: EMC			
225 AMP MCB			120/208 Wye			3 PH 4 W			
			MOUNT: SURFACE			PANEL ASSEMBLY RATED (KAIC): 10 KAIC			
CKT	BRKR	POLE	LOAD			A	B	C	LOAD
1	20 A	1	REC CORR. 132			0.0	0.0		REC CORR. 133, 135
3	20 A	1	REC EXT. FRONT & SIDE				0.0	0.0	REC EXT. REAR
5	20 A	1	ENTRY 102 EWC				0.0	0.0	UNKNOWN
7	20 A	1	WATER HEATER CONTROLS			0.0	0.0		VF-2
9	20 A	1	HWCP-1				0.0	0.0	REC SALLYPORT 119 FREEZER
11	20 A	1	REC MECH RM 200					0.0	0.0
13	20 A	1	MOTORIZED GATE			0.0	0.0		VF-1
15	20 A	1	HWCP-2				0.0	0.0	UNKNOWN
17	20 A	1	DH-1					0.9	0.0
19	20 A	1	DH-2A			0.9	0.0		PIT SPRINKLER SUMP PUMP
21	20 A	1	DH-3B				0.9	0.0	
23	20 A	1	DH-3					0.9	0.0
25	20 A	1	OXYGEN MASTER CONTROL/ALARM PANEL			0.5	0.0		
27	20 A	1	SPARE				0.0	0.0	OVERHEAT DOOR SALLYPORT 119
29	20 A	1	SPARE					0.0	0.0
31						0.0	0.0		
33	50 A	3	HP-1				0.0	0.0	COND-1
35							0.0	0.0	
37						0.0	0.0		
39	50 A	3	HP-2				0.0	0.0	COND-2
41							0.0	0.0	
						1 kVA	1 kVA	2 kVA	
						12 A	7 A	15 A	

(GE) = PROVIDE GFCI BREAKER FOR EQUIPMENT, 6-50mA PER NEC 427.22. PROVIDE DED. NEUTRAL
(GP) = PROVIDE GFCI BREAKER FOR PERSONNEL, 4-8mA PER NEC 210.8. PROVIDE DED. NEUTRAL
(L) = PROVIDE LOCKOUT BREAKER TO PREVENT UNAUTHORIZED SWITCHING
(LO) = ROUTE TO LOAD VIA LIGHTING CONTACTOR
(ML) = PROVIDE BREAKER WITH MAINTENANCE LOCKOUT, LOCKABLE
(EB) = EXISTING BREAKER
(RB) = REPLACE BREAKER WITH SIZE INDICATED
(PB) = PROVIDE BREAKER IN EXISTING SPACE

Load Classification	Connected Load	Demand Factor	Estimated Demand	Panel Totals
INTERIOR LIGHTING	0 VA	0.00%	0 VA	Total Conn. Load: 4.0 kVA Total Est. Demand: 4.0 kVA Total Conn. Current: 11 A Total Est. Demand Current: 11 A
EXTERIOR LIGHTING	0 VA	0.00%	0 VA	
RECEPTACLES	0 VA	0.00%	0 VA	
AC / HEAT PUMP	3544 VA	100.00%	3544 VA	
ELECTRIC HEAT	0 VA	0.00%	0 VA	
KITCHEN	0 VA	0.00%	0 VA	
MISCELLANEOUS	500 VA	100.00%	500 VA	
EXISTING LOAD @ 125%	0 VA	0.00%	0 VA	

EXISTING PANEL SCHEDULE									
L			LOCATION: ELECTRICAL 136			FED FROM: EMC			
225 AMP MCB			120/208 Wye			3 PH 4 W			
			MOUNT: SURFACE			PANEL ASSEMBLY RATED (KAIC): 10 KAIC			
CKT	BRKR	POLE	LOAD			A	B	C	LOAD
1	20 A	1	RECEPTION AREA LTS			0.0	0.0		EXT. BUILDING LIGHTS
3	20 A	1	ADULT DOG RUNS LTS				0.0	0.0	EXT. SERVICE LIGHTS
5	20 A	1	PUPPY QUARANTINE/ISOLATION LTS					0.0	0.0
7	20 A	1	FOOD PREP/WARDENS/LAUNDRY/BREAK ROOM LTS			0.0	0.0		PARKING LIGHTS
9	20 A	1	OFFICE AREA LTS				0.0	0.0	SIGN LIGHTS
11	20 A	1	LTS RM 118, 120, 120B, 121, 139					0.4	0.7
13	20 A	1	UNKNOWN						SPARE
15	20 A	1	FERRAL/ETHANASIA/JANITOR LTS			0.0	0.0		SPARE
17	20 A	1	SPARE					0.0	0.0
19	20 A	1	SPARE			0.0	0.0		SPARE
21	20 A	1	SPARE				0.0	0.0	SPARE
23	20 A	1	SPARE					0.0	0.0
25	20 A	1	SPARE			0.0	0.0		SPARE
27	20 A	1	SPARE				0.0	0.0	SPARE
29	20 A	1	SPARE					0.0	--
31	--	1	SPACE ONLY			--	--	--	SPACE ONLY
33	--	1	SPACE ONLY			--	--	--	SPACE ONLY
35	--	1	SPACE ONLY				--	--	SPACE ONLY
37	--	1	SPACE ONLY			--	--	--	SPACE ONLY
39	--	1	SPACE ONLY				--	--	SPACE ONLY
41	--	1	SPACE ONLY				--	--	SPACE ONLY
						0 kVA	0 kVA	1 kVA	
						0 A	0 A	9 A	

(GE) = PROVIDE GFCI BREAKER FOR EQUIPMENT, 6-50mA PER NEC 427.22. PROVIDE DED. NEUTRAL
(GP) = PROVIDE GFCI BREAKER FOR PERSONNEL, 4-8mA PER NEC 210.8. PROVIDE DED. NEUTRAL
(L) = PROVIDE LOCKOUT BREAKER TO PREVENT UNAUTHORIZED SWITCHING
(LO) = ROUTE TO LOAD VIA LIGHTING CONTACTOR
(ML) = PROVIDE BREAKER WITH MAINTENANCE LOCKOUT, LOCKABLE
(EB) = EXISTING BREAKER
(RB) = REPLACE BREAKER WITH SIZE INDICATED
(PB) = PROVIDE BREAKER IN EXISTING SPACE

Load Classification	Connected Load	Demand Factor	Estimated Demand	Panel Totals
INTERIOR LIGHTING	1094 VA	125.00%	1367 VA	Total Conn. Load: 1.1 kVA Total Est. Demand: 1.4 kVA Total Conn. Current: 3 A Total Est. Demand Current: 4 A
EXTERIOR LIGHTING	0 VA	0.00%	0 VA	
RECEPTACLES	0 VA	0.00%	0 VA	
AC / HEAT PUMP	0 VA	0.00%	0 VA	
ELECTRIC HEAT	0 VA	0.00%	0 VA	
KITCHEN	0 VA	0.00%	0 VA	
MISCELLANEOUS	0 VA	0.00%	0 VA	
EXISTING LOAD @ 125%	0 VA	0.00%	0 VA	

EXISTING PANEL SCHEDULE				R		LOCATION: CORRIDOR 132		FED FROM: EMC			
225 AMP MCB		120/208 Wye		3 PH 4 W		MOUNT: RECESSED		PANEL ASSEMBLY RATED (KAIC): 10 KAIC			
CKT	BRKR	POLE	LOAD	A	B	C	LOAD	POLE	BRKR	CKT	
1	20 A	1	REC. ADULT DOG 108	0.0	0.0		LIVESTOCK BLDG LIGHTS	1	20 A	2	
3	20 A	1	REC. PUPPY ISOL			0.0	0.0	1	20 A	4	
5	20 A	1	REC CAT ADOPT/ENTRY/FOYER	0.0	0.0		REFRIG- RM 121 (GP)	1	20 A	6	
7	20 A	1	REC SUPPORT TECH/SARG			0.0	0.0	1	20 A	8	
9	20 A	1	REC LOCKER ROOM/SINK	0.0	0.0		REC - RM 121	1	20 A	10	
11	20 A	1	REC FUTURE VET 121			0.0	0.0	1	20 A	12	
13	20 A	1	REC TOILETS 107/108	0.0	0.4		RECS- RM 121	1	20 A	14	
15	20 A	1	REC FOOD PREP 109			0.0	1.1	1	20 A	16	
17	20 A	1	REC FOOD PREP 105 COUNTER	0.0	0.0		RECS- RM 129, 128	1	20 A	18	
19	20 A	1	REC LAUNDRY 114			0.0	0.0	1	20 A	20	
21	20 A	1	REC BREAKROOM 127	0.0	0.0		SWASHER - RM 119	1	20 A	22	
23	20 A	1	REC COUNTER BREAKROOM 127	0.0	0.0		DISHWASHER - RM 109	1	20 A	24	
25	20 A	1	REC TV BREAKROOM 127	0.0	0.8		DISHWASHER - RM 109	1	20 A	26	
27	20 A	1	REC FERRAL CATS/SEUTHAN			0.0	0.2	REC - RM 109	1	20 A	28
29	20 A	1	REC JANITORIA/DUA DUXEL	0.0	0.0		SLIDING DOOR	1	20 A	30	
31	20 A	1	REC SALLY PORT 119			0.0	0.0	REC - UNDERSTAIR S1	1	20 A	32
33	20 A	1	UNKNOWN	0.0	0.0		SURGERY TABLE - RM 139	1	20 A	34	
35	20 A	1	REC SALLYPORT/ ELECTRICAL RM			0.0	0.0	RECS - RM 121 (GP)	1	20 A	36
37	20 A	1	UNKNOWN	0.0	0.0		SPARE	1	20 A	38	
39	20 A	1	REC RECEPTION 105 COPIER			0.0	0.0	SPARE	1	20 A	40
41	20 A	1	REC WARDENS 112	0.0	0.0		SPARE	1	20 A	42	
				2 KVA		3 KVA					